

# DO NOT SCALE



THE CONTRACTOR IS TO CHECK AND VERIFY ALL BUILDING AND SITE DIMENSIONS, LEVELS AND SEWER INVERT LEVELS AT CONNECTION POINTS BEFORE WORK STARTS.

THIS DRAWING IS TO BE READ AND CHECKED IN CONJUNCTION WITH ENGINEERS AND OTHER SPECIALIST DRAWINGS & SPECIFICATIONS.

THE DRAWING AND THE WORKS DEPICTED ARE THE COPYRIGHT OF PAWLK+WIEDMER LTD AND MAY NOT BE REPRODUCED EXCEPT BY WRITTEN PERMISSION.

## NOTES

 TO BE READ IN CONJUNCTION WITH DEMOLITION GA PLANS, SECTIONS, ELEVATIONS, FINISHES PLANS AND HERITAGE STATEMENT. REFER ALSO TO MEP ENGINEERS' STRIP OUT AND BUILDERSWORK INFORMATION AND LIGHTING LAYOUTS.

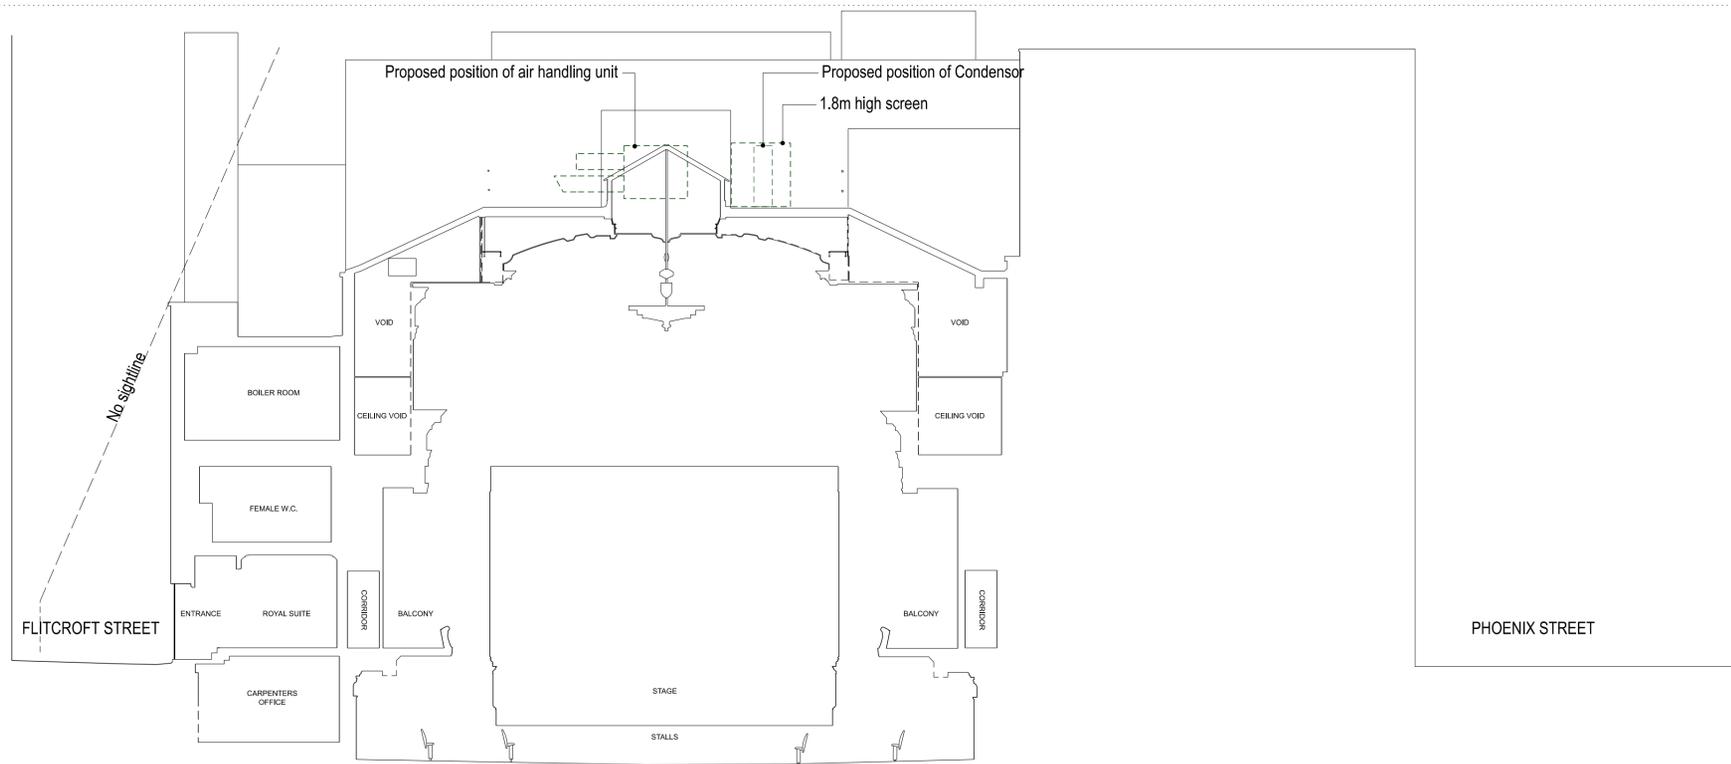



Datum 18.00m

Section 2

Rev	Date	Reason For Issue	CHK
-	-	-	-
-	-	-	-

## Key Plan

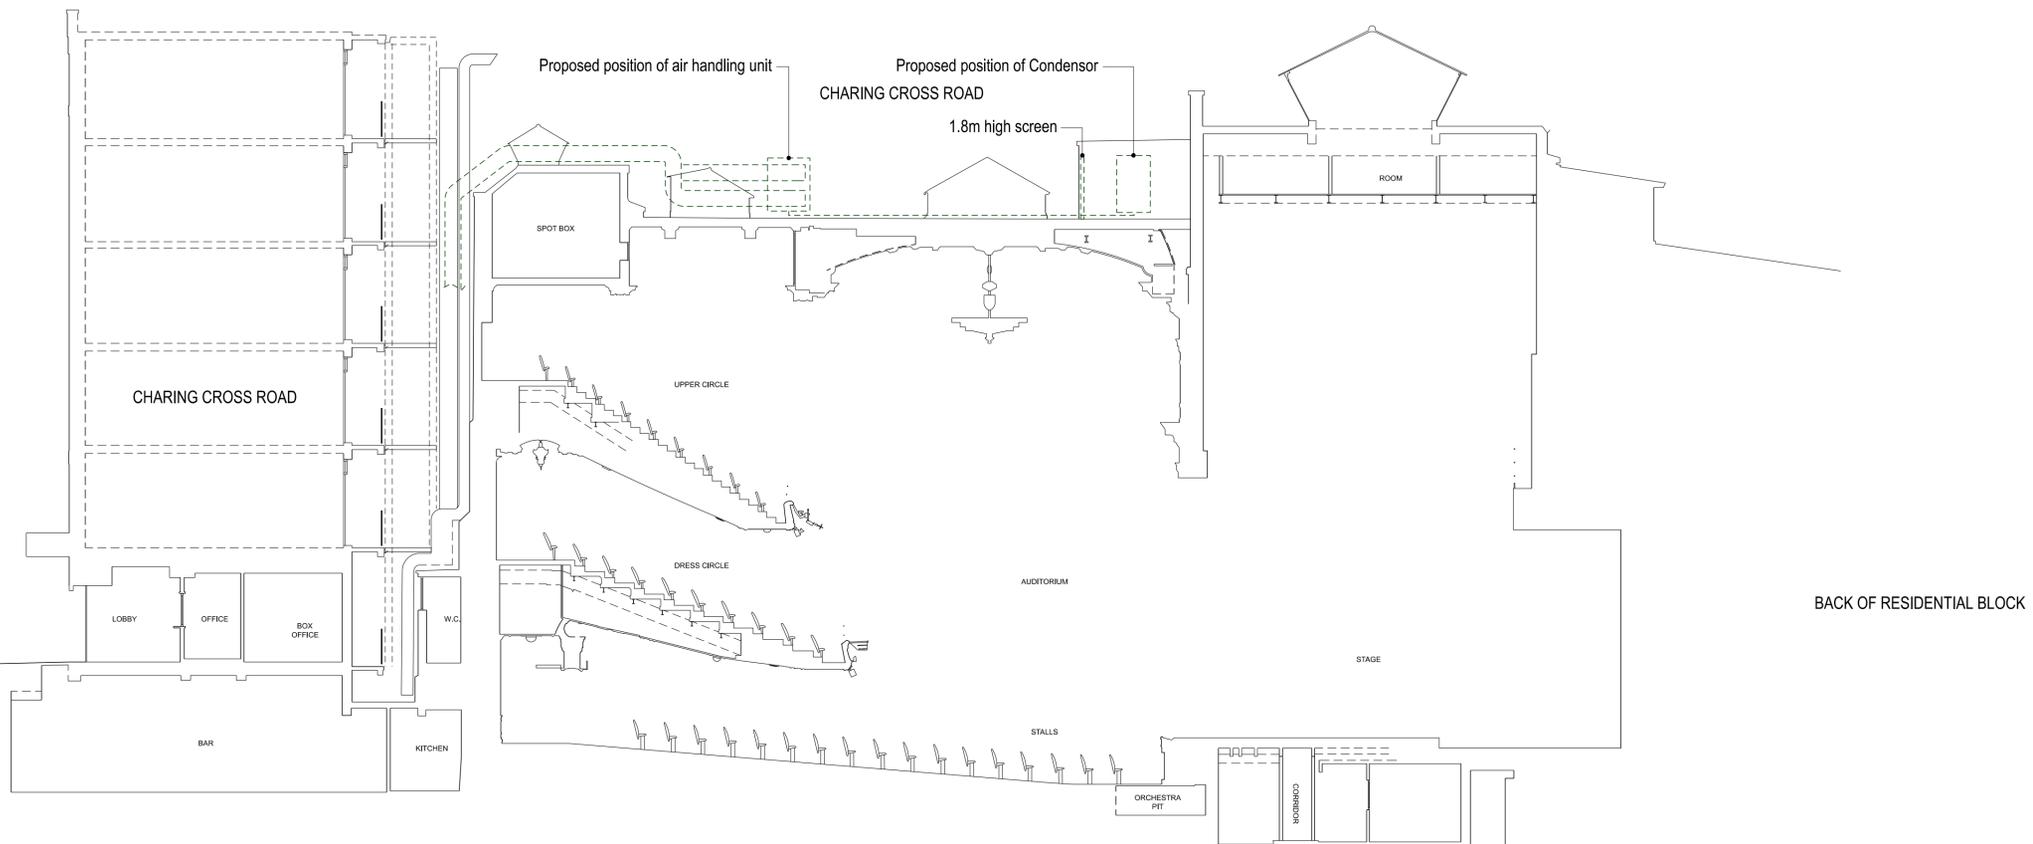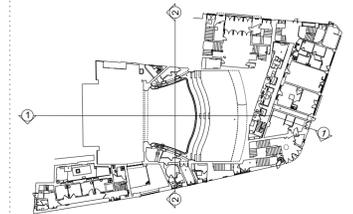

Datum 18.00m

Section 1

## pawlik + wiedmer

8-12 Creekside  
London  
SE8 3DX  
london@pawlikwiedmer.com  
Registered in England & Wales No: 8155464  
Registered Office: 27 Mortimer Street, W1T 3BL, UK

## Client

Phoenix Theatre  
Charing Cross Road  
Ambassador Theatre Group

## Project

Project Ash  
Phoenix Theatre  
Charing Cross Road

## Title

Whole Building  
Sections 1 & 2  
Through Theatre  
Existing

## Status

PLANNING

Project Number	Date	Checked By
559	May 2023	-
Revision	Scale @ ISO A1	Approved By
-	1:100@A1	-

Drawing Number  
559-PWL-ZZ-ZZ-DR-A-00\_210