



THIS DRAWING IS PROTECTED BY COPYRIGHT - FIGURED DIMENSIONS ONLY TO BE TAKEN FROM THIS DRAWING. DIMENSIONS TO BE CHECKED ON SITE AND ANY DISCREPANCIES REPORTED TO THE ARCHITECT IMMEDIATELY.

PURPOSE OF ISSUE: (I)Info/Comment (S)Sign Off (P)Planning (B)Building Control (T)Tender (C)Construction (F)Final Revision


Rev	Rev Date	Revision Description	Drawn/Checked	Purpose of Issue
/	10/07/2023	Issued for Planning	HP/FY	P

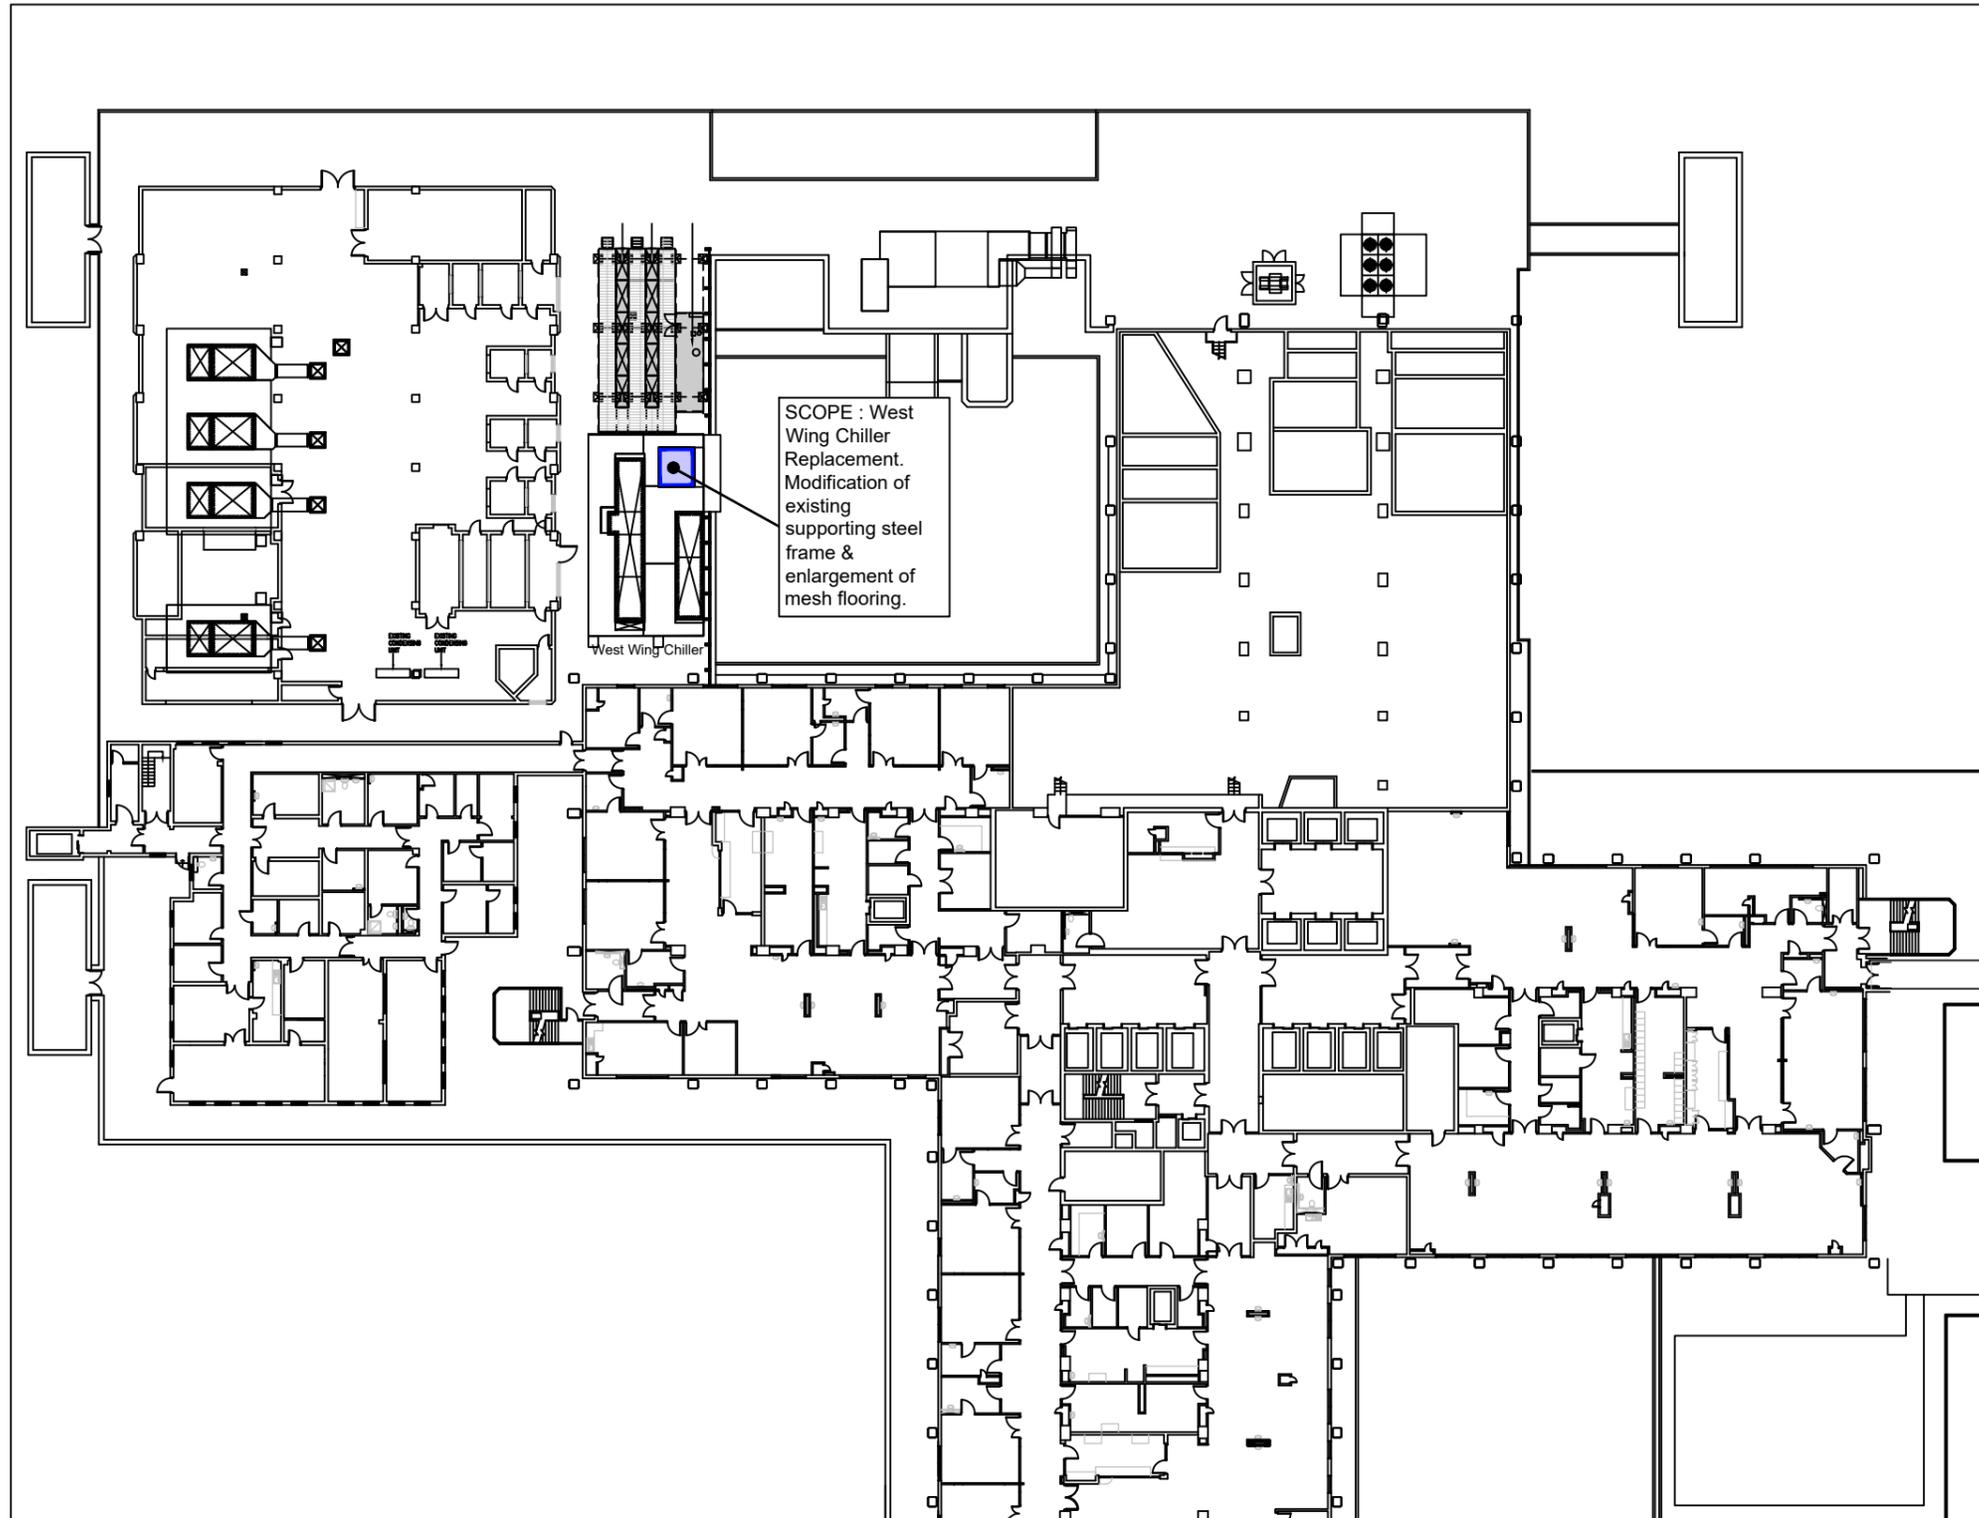

Site Plan

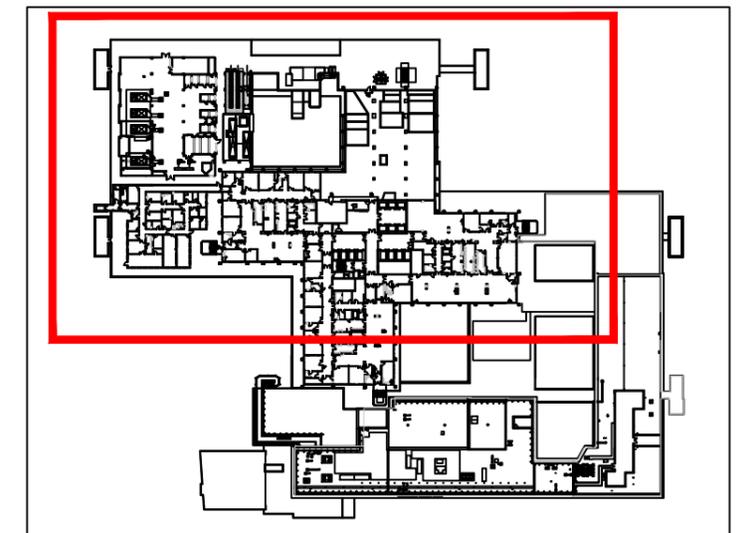

 01 Proposed Level 4 Plan-West wing Chiller
 (01)004 1:500 @ A3



FOR PLANNING

Proposed Level 4 Plan	23018 JOB NUMBER	(01)004 DRAWING NUMBER	/ REV
Royal Free Hospital NHS Foundation Trust ICU Chiller Replacement	May 2022 DATE	1:500 @A3 SCALE	

Ansell & Bailey Ltd Chartered Architects 99-101 Farringdon Road London EC1R 3BN 020 7387 0141 architects@ansellandbailey.com

ANSELL + BAILEY