

GENERAL NOTES

SETTING OUT - DO NOT SCALE from this drawing, use figured dimensions ONLY. If in doubt, ASK! Dimensions are shown to structural face generally, or to finished face of ducts and lining. All dimensions are shown in millimeters unless otherwise indicated. Angular dimensions are shown in decimal degrees to the nearest whole degree. Where items are to be fabricated off-site, site dimensions are to be used and confirmed prior to ordering or manufacturing.

STRUCTURAL - For design, detailing and setting out of structural elements refer to Structural Engineers drawings.

SERVICES - For design, detailing & setting out of services, including SVP's, Gas, Water, Electrics & Telecoms etc refer to M&E Engineers and Structural Engineers drawings. **FINISHES** - For external wall finishes & wall types refer to Series

21 External Wall Types & Detail drawings All information on this drawing must be read in conjuction with relevant series and specifications.

LEGEND

Type 4 El 30/15 Closed State Vertical Cavity Barrier (Compartment Wall)

Type 7 El 30/15 Closed State Horizontal Cavity Barrier (Compartment Floor)

Type 2 EI 30/15 Closed State Cavity Barrier Movement Joints within Masonry Horizontal movement joints to be co-ordinated with

masonry support. To be reviewed to conform with NHBC requirements Bat boxes within Masonry

Bat boxes within Masonry

Masonry Support

DPC

[] []

(B.I)

1560

NOTE: FIRE RATING TO FACADES PROVIDED BY SHAFT WALL ON INTERNAL SIDE Denotes 60 min Fire Resistant Facade

Denotes 90 min Fire Resistant Facade **F** 7 Denotes 120 min Fire Resistant Facade

Dry Riser Inlet

Dry Riser Inlet

Drawing to be read in conjunction with Setting Out Plans Cavity barriers will be included in any cavity where there is a

potential for unseen fire spread. The areas that require cavity barriers are as follows:

 At the junction between an external cavity wall and a compartment wall that separates buildings; and at the top of such an external cavity wall; At the junction between an external cavity wall and every

compartment floor and compartment wall; At the junction between a cavity wall and every compartment floor, compartment wall, or other wall or door assembly that forms a fire-resisting barrier;

Within the void behind the external face of rain screen cladding at every floor level and on the line of compartment walls abutting the external wall; At the edges of cavities (including around openings, i.e. windows).

All horizontal cavity barriers to be installed with a suitable cavity tray immediately above All vertical cavity barriers to be installed with a DPC extending a minimum of 25mm into the cavity either

FIRE STRATEGY NOTES

 
To be read in conjunction with Elementa (Introba) Fire Strategy, Facade Consultants' Specification & MTT Drawings & Specifications.

Refer to Elementa (Introba) Fire Strategy for full information on alarm & detection systems, fire suppression systems, fire doors & escape routes.

For specification, fire resistance and combustibility of fæade materials and components please refer to Façade Consultant's Specification.

Refer to relevant **PTAL / DDU** series, including: Series 21 - External Setting Out Plans Series 22 - Internal Setting Out Plans Series 35 - Reflected Ceiling Plans Series 32 - Doors Series 60 - Electrical Plans Series 67 - Fire Strategy Plans Series 70 - Apartment Plans Series 71 - Signage

Where DDU drawing issued, this should supersede equivalent PTAL drawing with the same number. Any issues please contact DDU immediately



design delivery

77 Endell Street London WC2H 9DZ T +44 (0)20 7240 7766 W designdeliveryunit.com

B_Level_00 _ \bigtriangledown

FFL 34800

St George North London Limited



Camden Goods Yard

Building B Setting Out Elevations Sheet17

As indicated @A0

20226

Practice Project No.

Client Project No. Originator Volume Level Type Role Number


CGYB0-DDU-B0-ZZ-DR-A-05217

Description

Previous Drawing Number CGYB0 - PTA - XXX - XX - DR - A - 05217

P1, Work in progress issue, 04.03.22

CONSTRUCTION © Design Delivery Unit Ltd retain copyright of this drawing. It may not be copied, altered or reproduced in any way without their written authority.

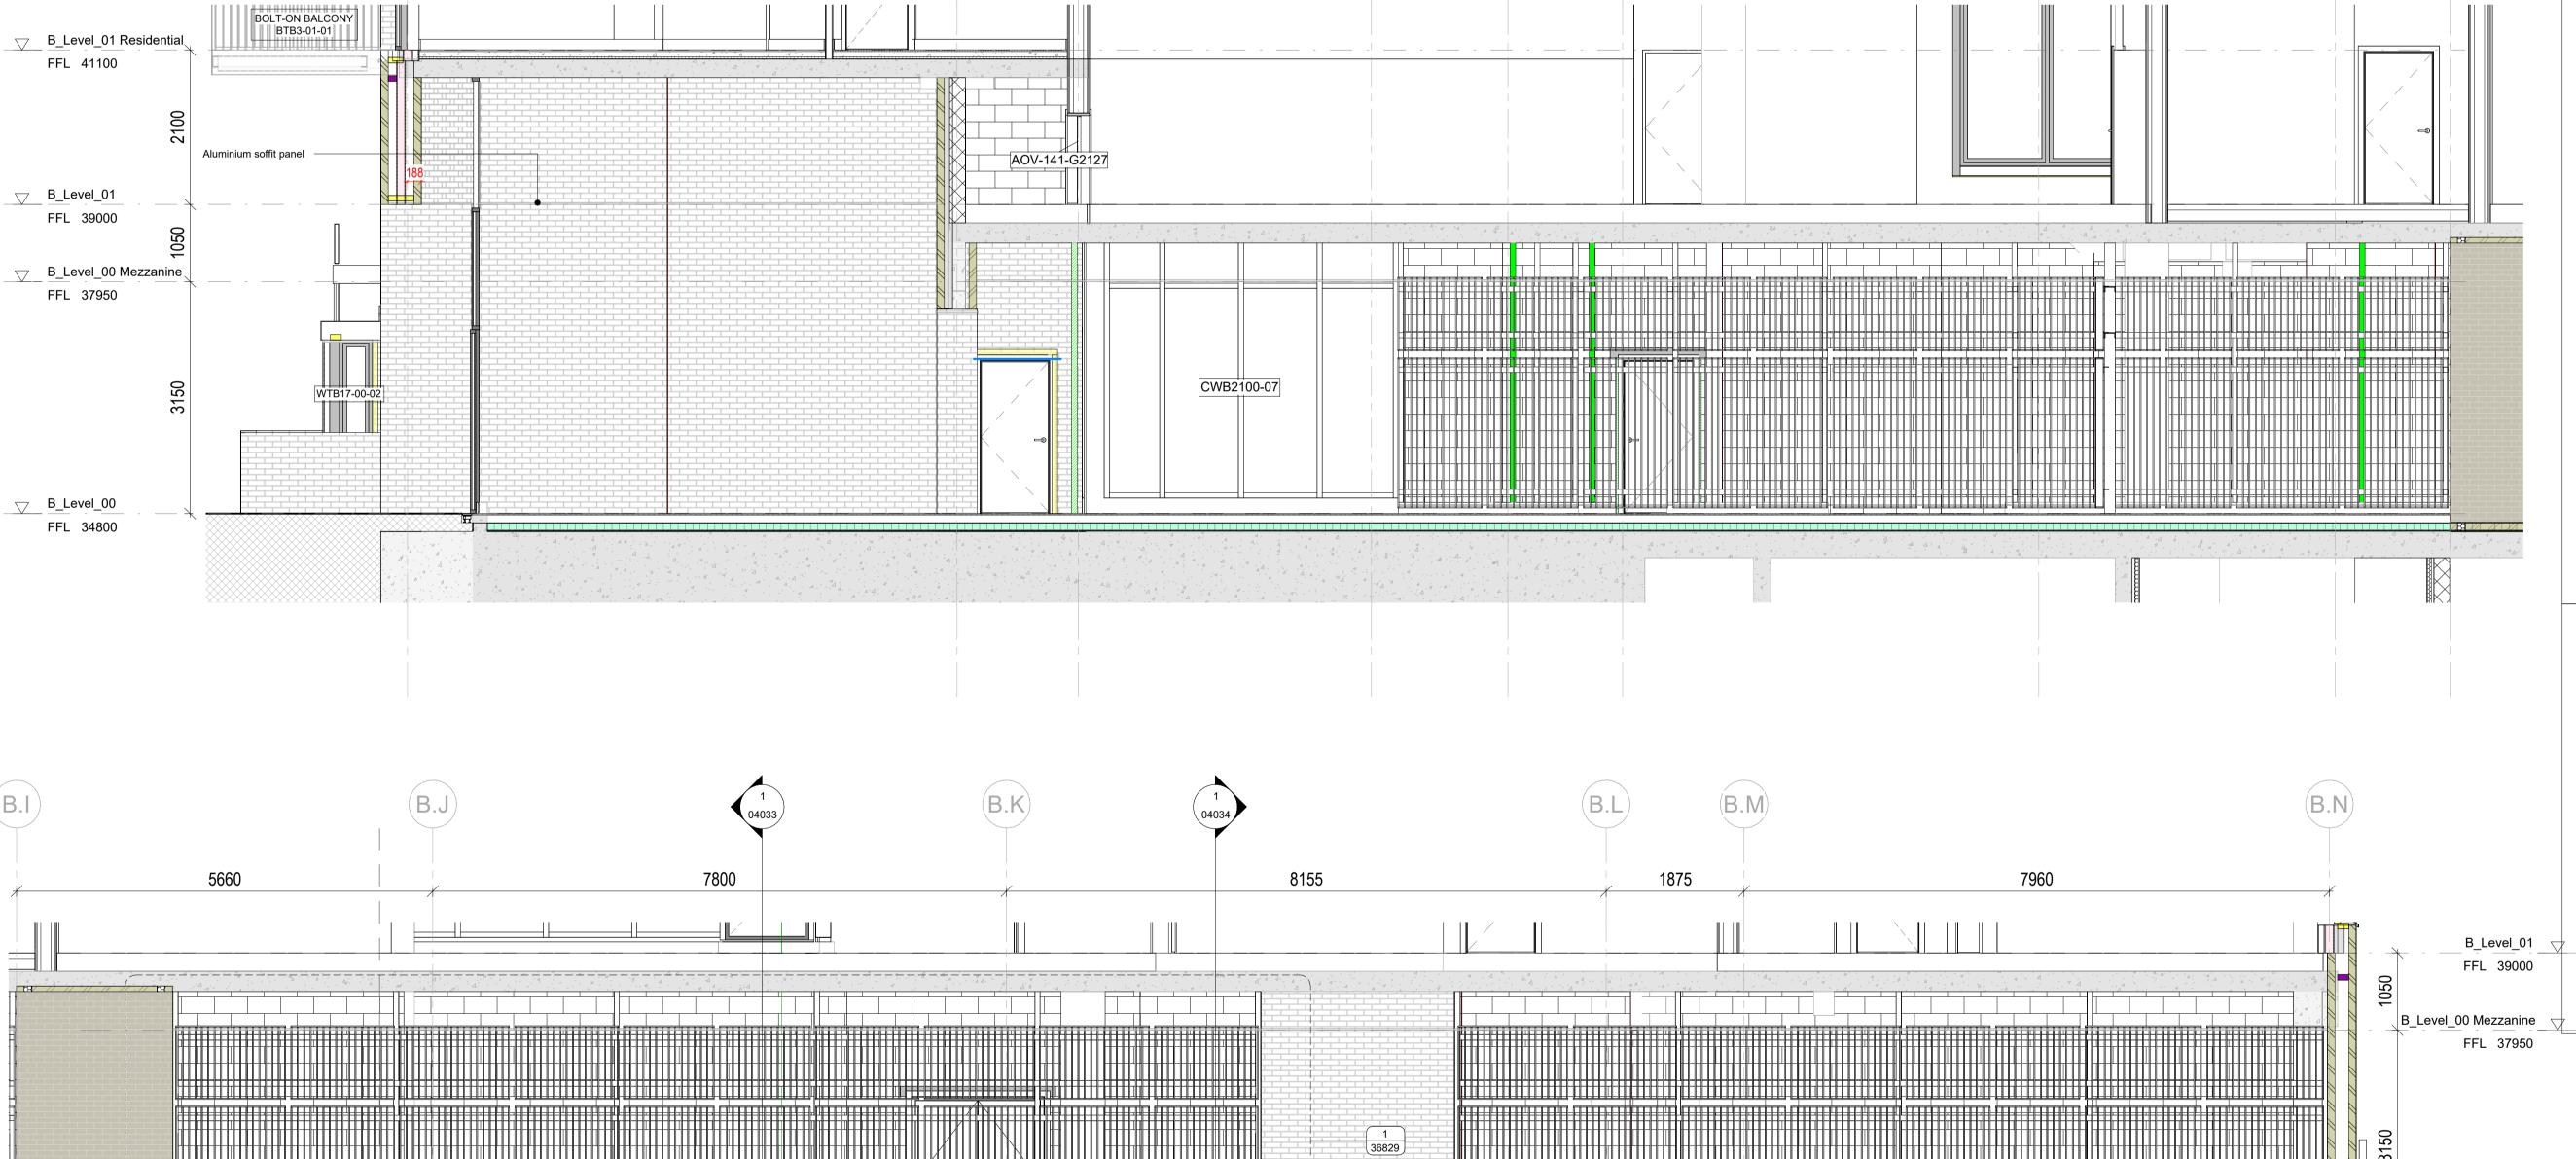

1855

5660

1650

B.A

7472