

B	UPDATED AS PER COMMENTS	14.10.2023
REV	DESCRIPTION	DATE
Purpose of Issue INFORMATION		
Drawn	-	Checked -
Date	27.06.23	
Scale	1:50	@A3
Project Number	Sheet Number	Rev
4033	DR-03-005	B


**PROJECT:**  
10 Thanet St. London WC1H 9QL

**DRAWING NAME:**  
Proposed Lower Ground Floor Plan

**NOTES:**  
Orientated to fit sheet size, 1:50@A3

© Copyright Once Printed and distributed this document is assumed uncontrolled.  
© All rights reserved. No part of this drawing may be reproduced or transmitted in any form by any means without the written permission of the copyright holder.



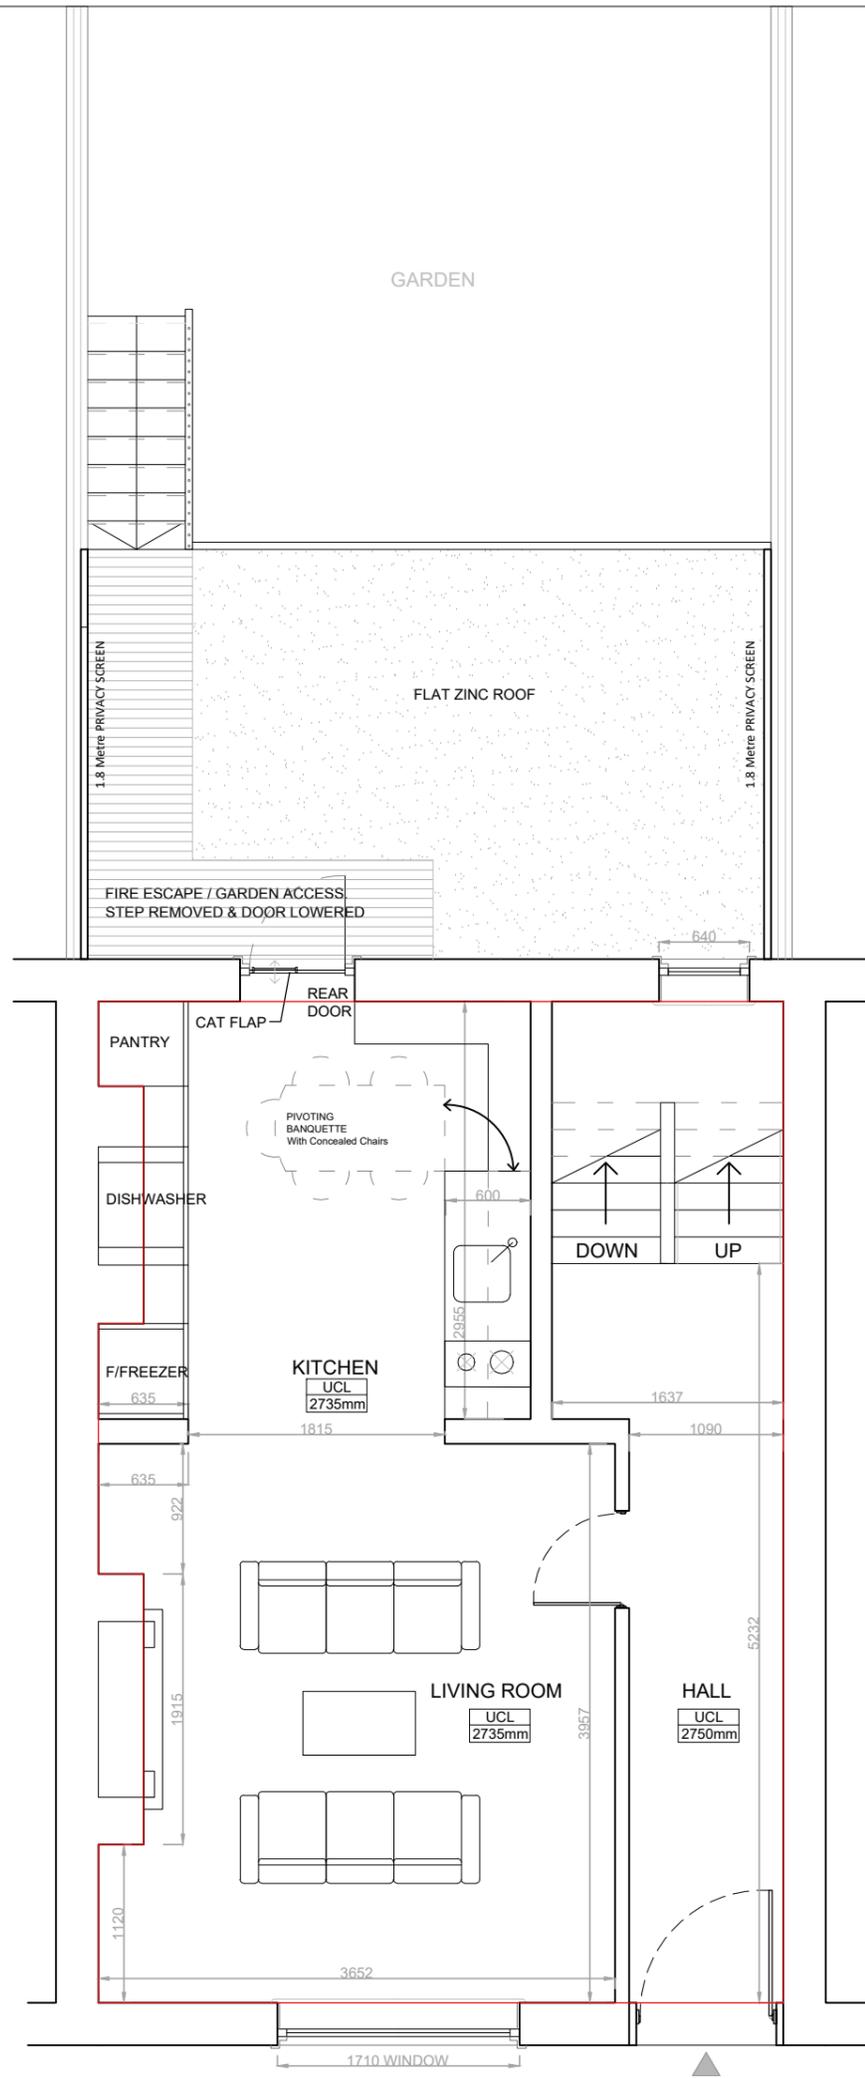

GROUND FLOOR PLAN

A	UPDATED AS PER COMMENTS	12.10.2023
REV	DESCRIPTION	DATE

Purpose of Issue			INFORMATION		
Drawn	-	Checked	-		
Date	27.06.23				
Scale	1:50	@A3			
Project Number	4033	Sheet Number	DR-03-006	Rev	A




**PROJECT:**  
10 Thanet St. London WC1H 9QL

**DRAWING NAME:**  
Proposed Ground Floor Plan

**NOTES:**  
Orientated to fit sheet size, 1:50@A3

© Copyright Once Printed and distributed this document is assumed uncontrolled.  
© All rights reserved. No part of this drawing may be reproduced or transmitted  
in any form by any means without the written permission of the copyright holder.

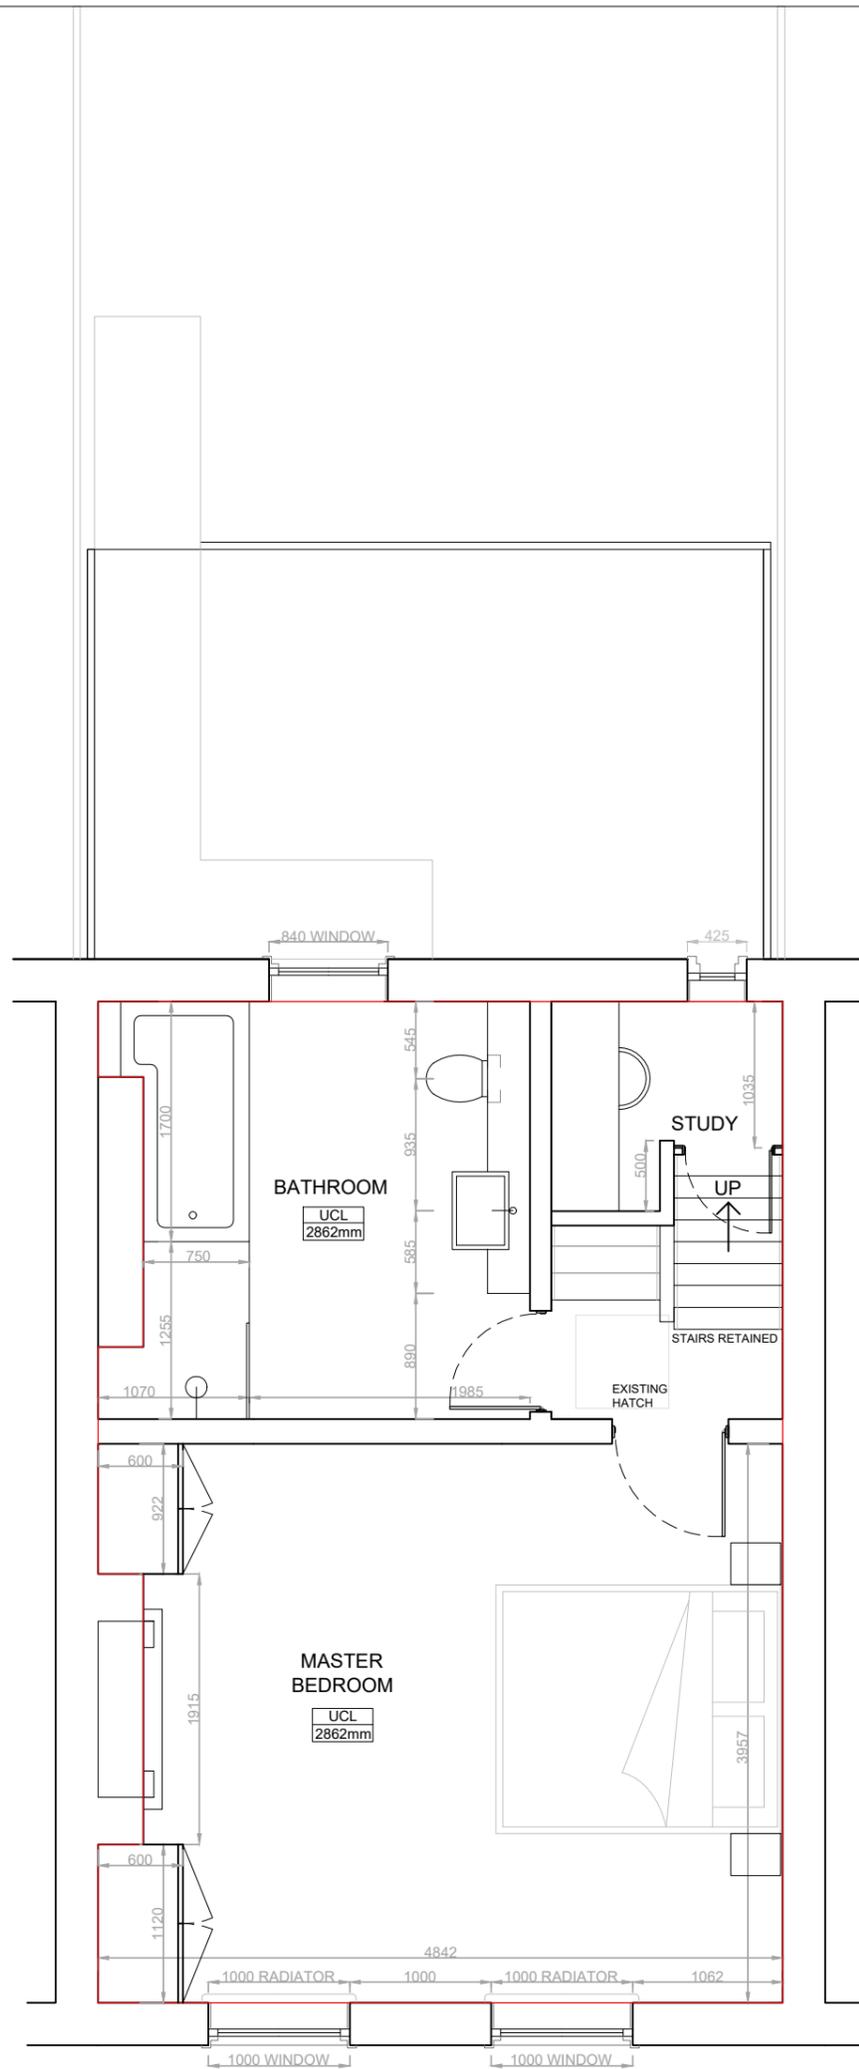

FIRST FLOOR PLAN

B	UPDATED AS PER COMMENTS	14.10.2023
REV	DESCRIPTION	DATE

Purpose of Issue			INFORMATION		
Drawn	-	Checked	-		
Date	27.06.23				
Scale	1:50	@A3			
Project Number	4033	Sheet Number	DR-03-007	Rev	B

**PROJECT:**  
10 Thanet St. London WC1H 9QL



**DRAWING NAME:**  
Proposed First Floor Plan

**NOTES:**  
Orientated to fit sheet size, 1:50@A3

© Copyright Once Printed and distributed this document is assumed uncontrolled.  
© All rights reserved. No part of this drawing may be reproduced or transmitted  
in any form by any means without the written permission of the copyright holder.





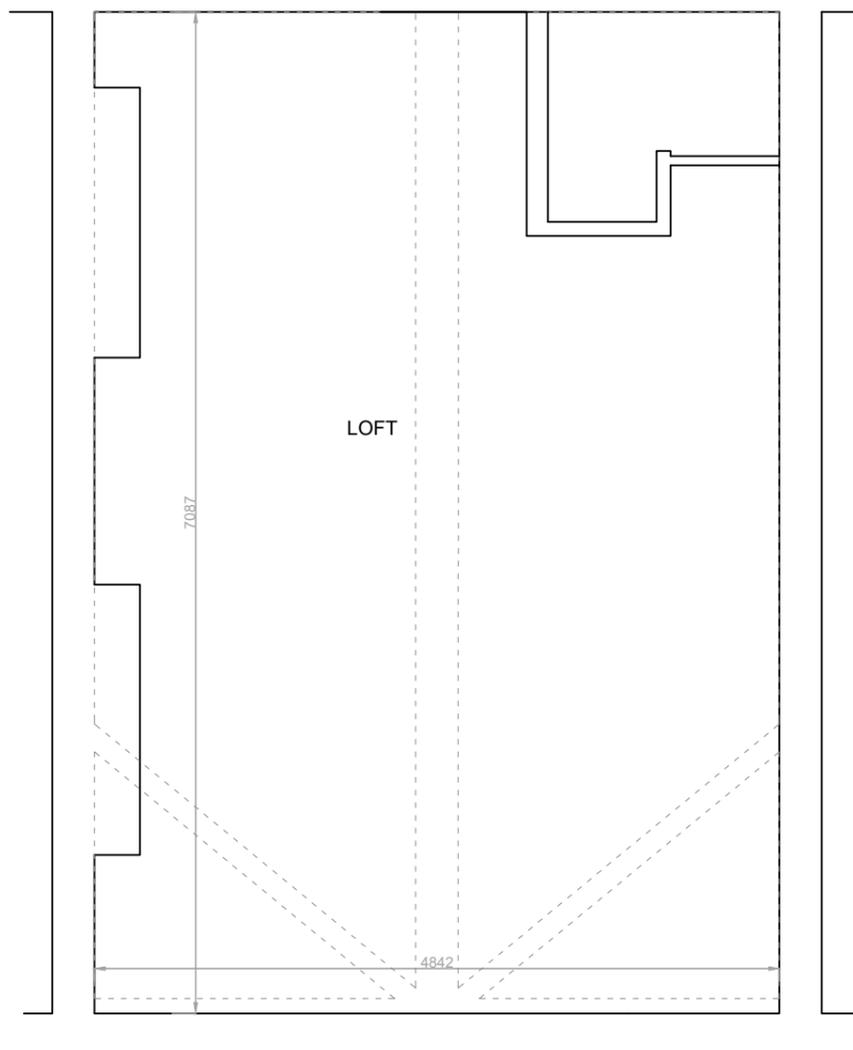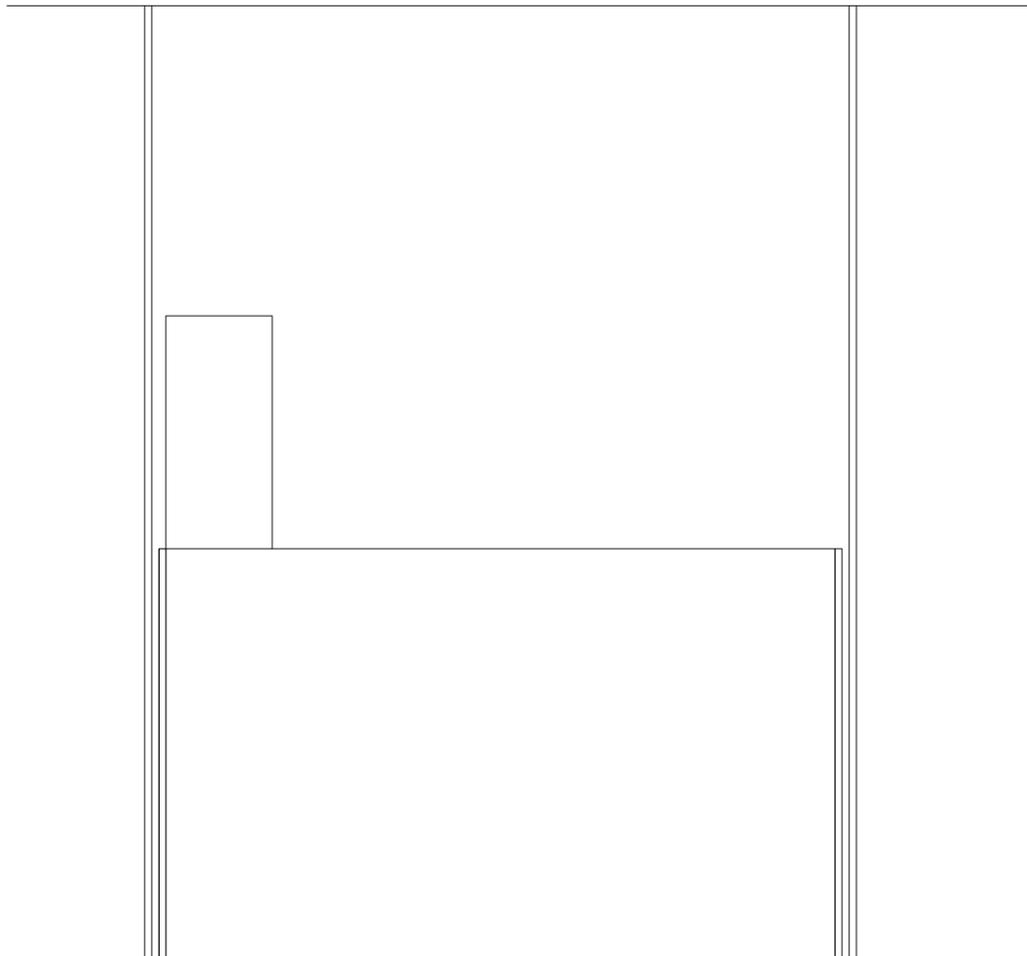

LOFT PLAN



insideout

**PROJECT:**  
10 Thanet St. London WC1H 9QL


**DRAWING NAME:**  
Proposed Loft Plan

**NOTES:**  
Orientated to fit sheet size, 1:50@A3

© Copyright Once Printed and distributed this document is assumed uncontrolled.  
© All rights reserved. No part of this drawing may be reproduced or transmitted  
in any form by any means without the written permission of the copyright holder.

Purpose of Issue INFORMATION		
Drawn	-	Checked -
Date	27.06.23	
Scale	1:50	@A3
Project Number	Sheet Number	Rev
4033	DR-03-009	-

Proposed Section - 1:50

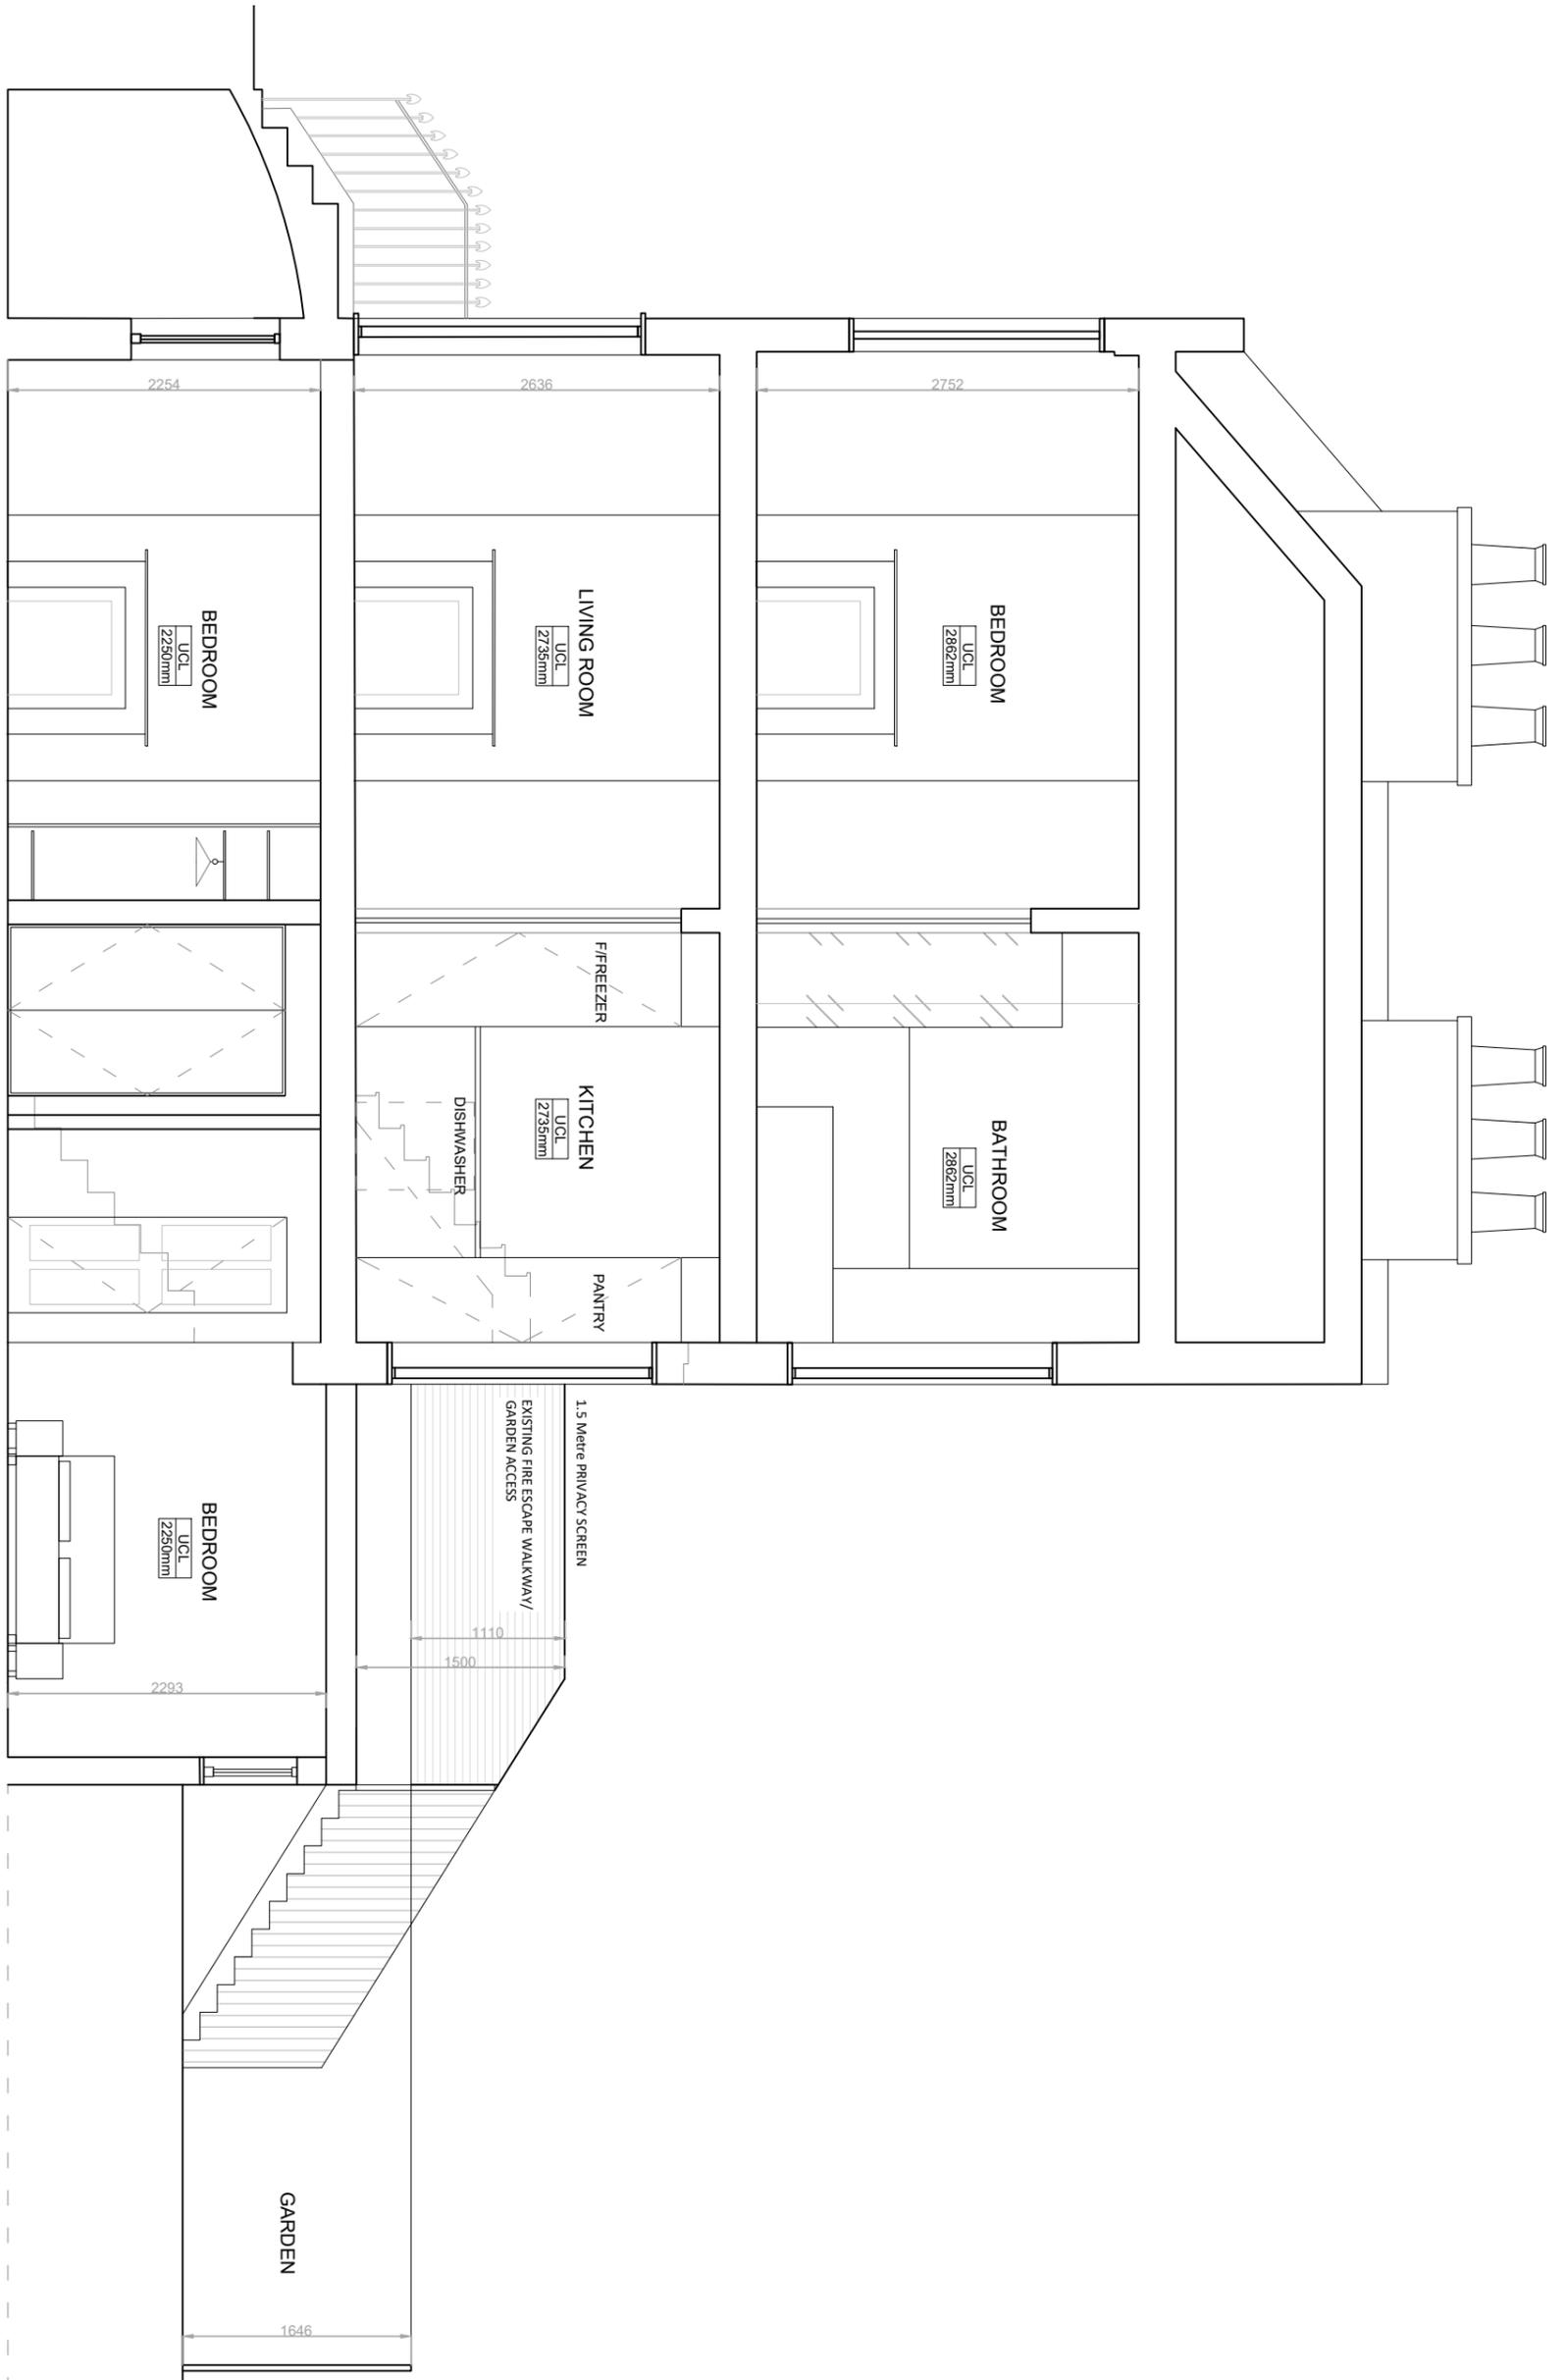

B	UPDATED AS PER COMMENTS	14.10.2023
REV	DESCRIPTION	DATE
Purpose of Issue INFORMATION		
Drawn	-	Checked -
Date	27.06.23	
Scale	1:50	@A3
Project Number	Sheet Number	Rev
4033	DR-04-002	B


**PROJECT:**  
10 Thanet St. London WC1H 9QL

**DRAWING NAME:**  
Proposed Section


**NOTES:**  
Orientated to fit sheet size, 1:50@A3

© Copyright Once Printed and distributed this document is assumed uncontrolled.  
© All rights reserved. No part of this drawing may be reproduced or transmitted in any form by any means without the written permission of the copyright holder.



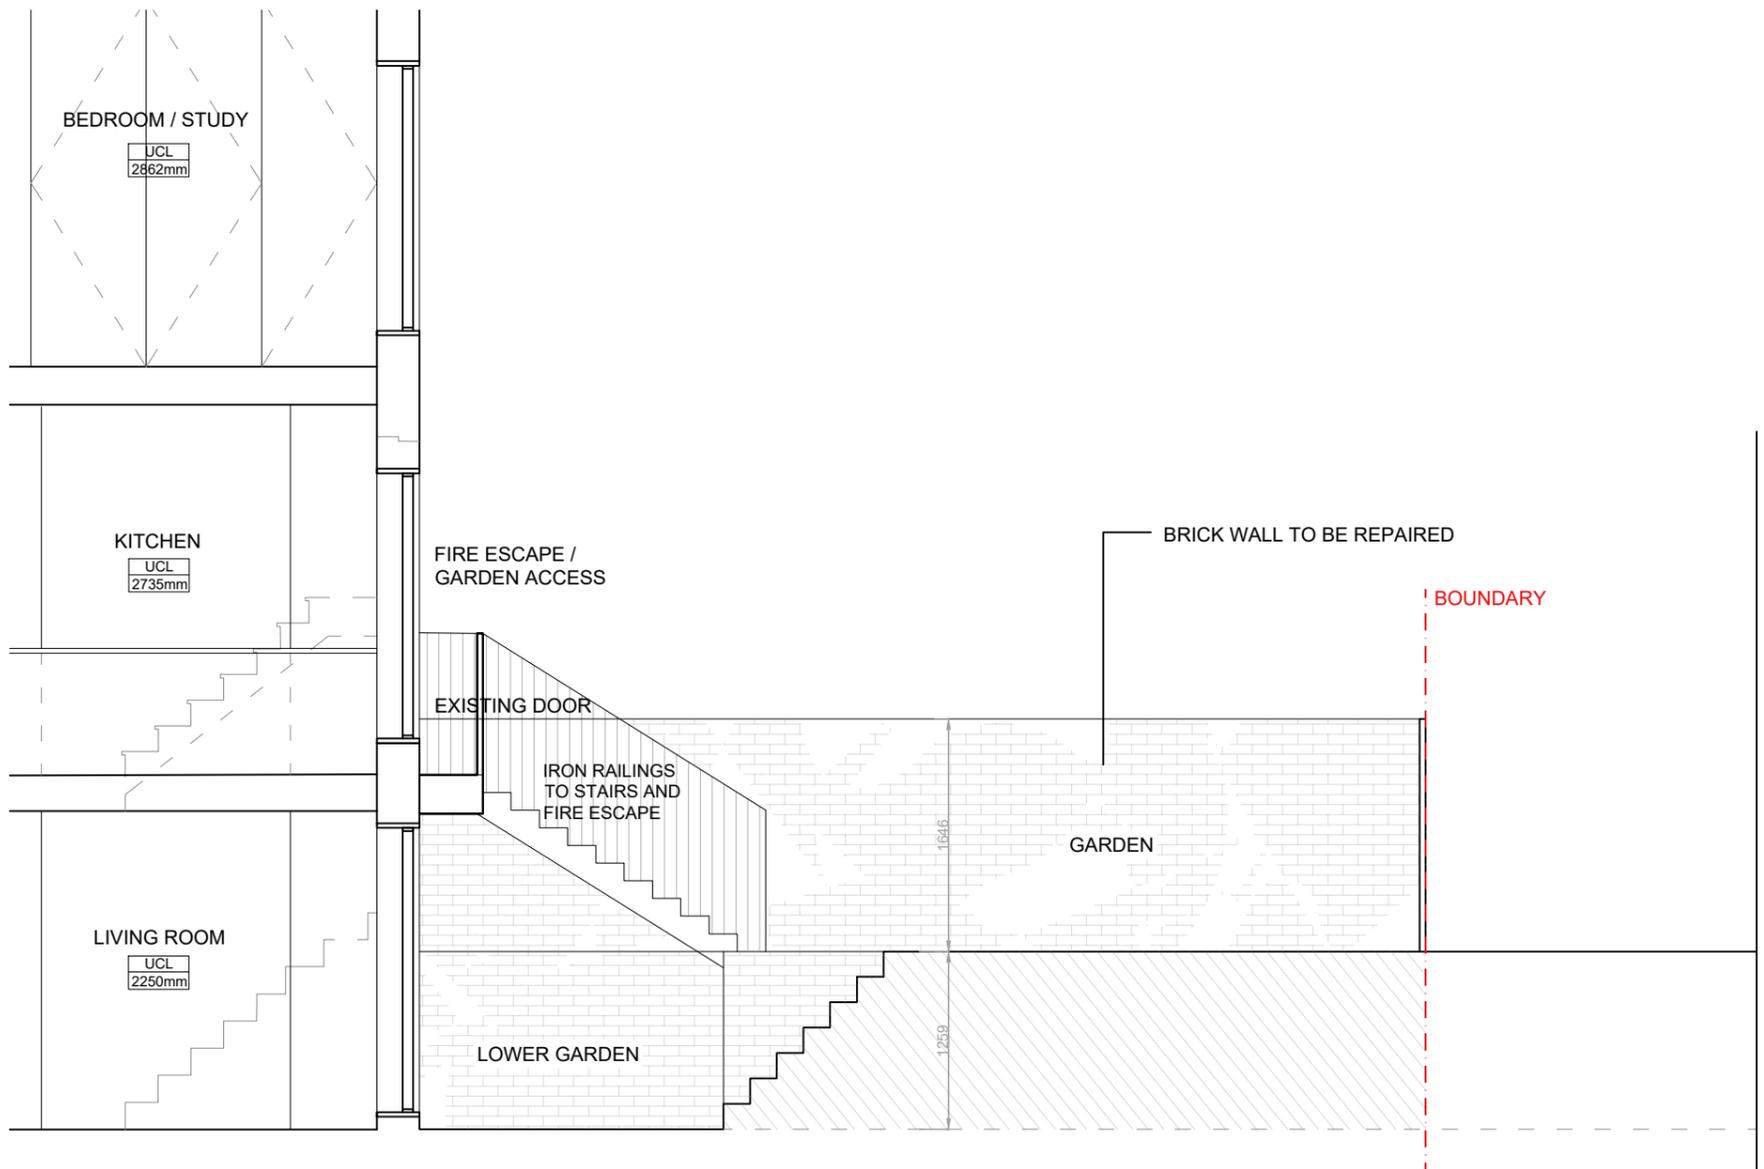

Existing Garden Wall Elevation - 1:50

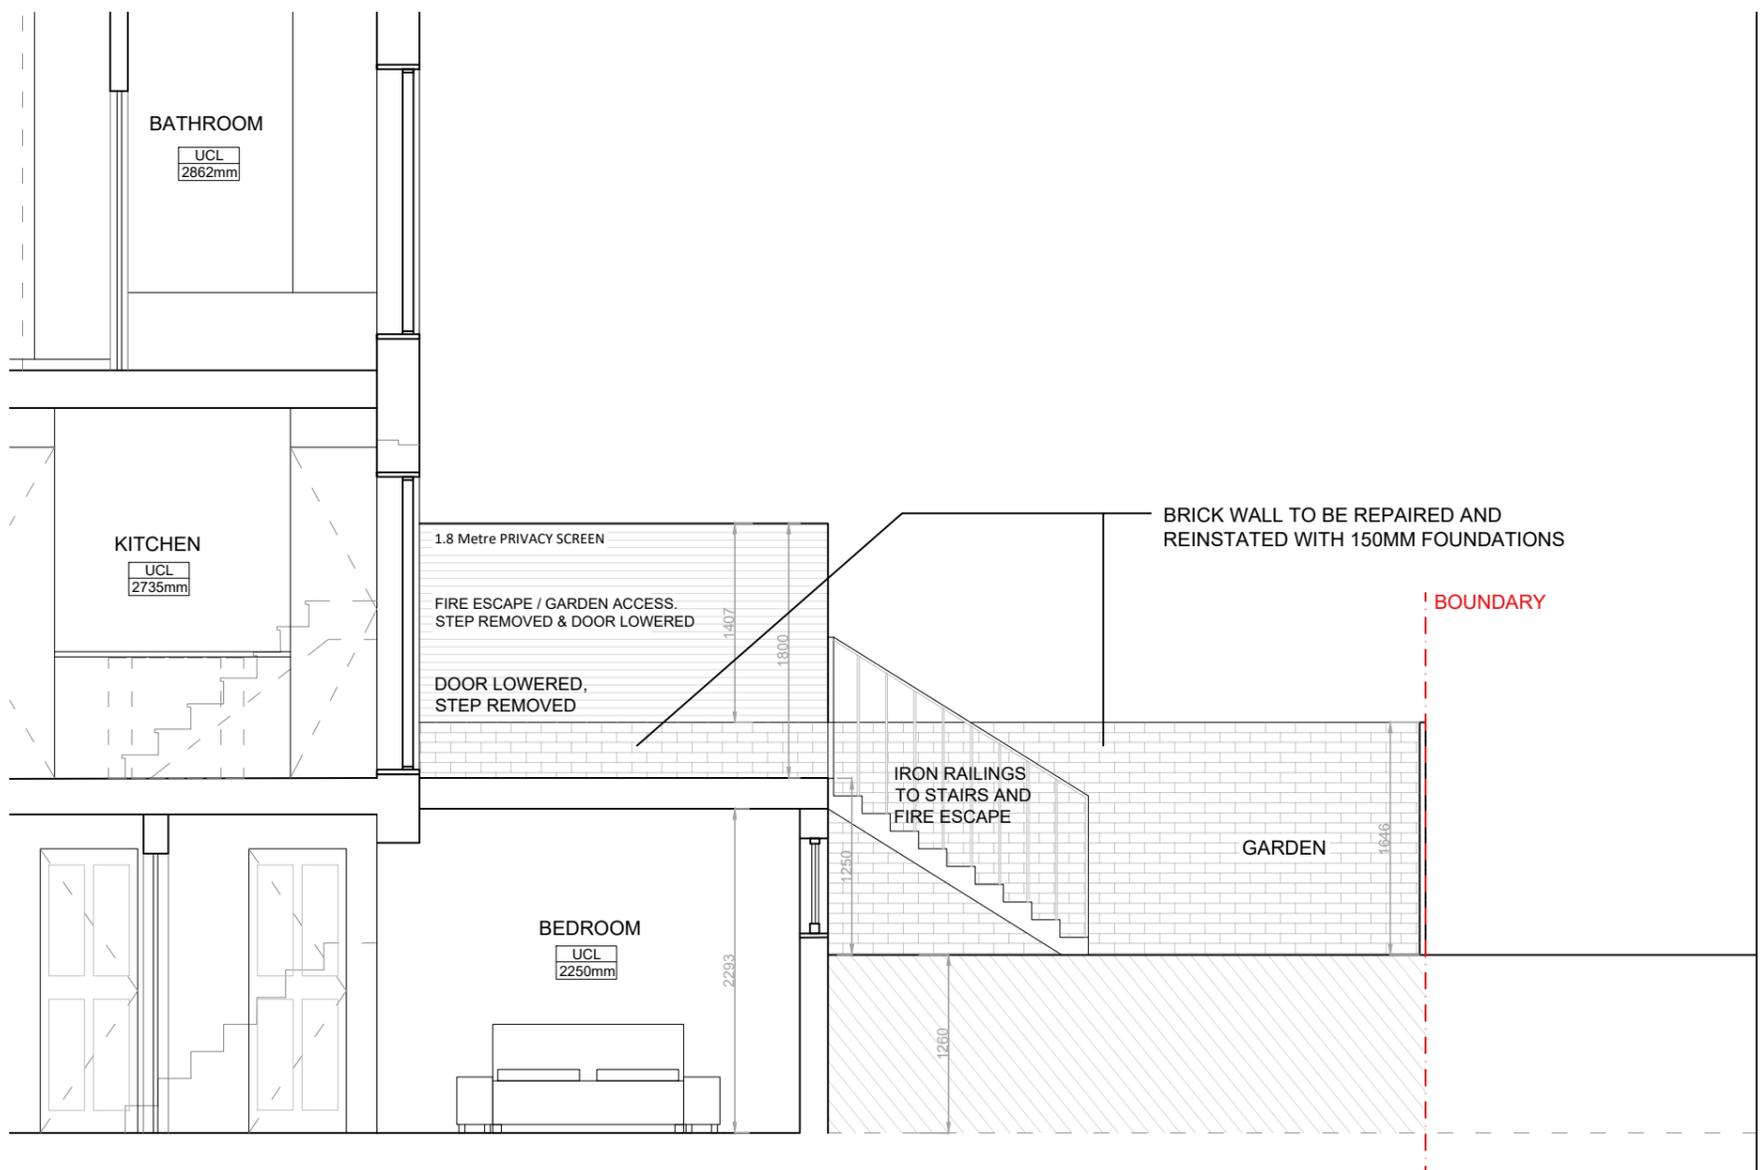

Proposed Garden Wall Elevation - 1:50




**PROJECT:**  
10 Thanet St. London WC1H 9QL  
**DRAWING NAME:**  
Existing and Proposed Garden Wall Elevations


**NOTES:**  
Orientated to fit sheet size, 1:50@A3

© Copyright Once Printed and distributed this document is assumed uncontrolled.  
© All rights reserved. No part of this drawing may be reproduced or transmitted in any form by any means without the written permission of the copyright holder.

Purpose of Issue			INFORMATION		
Drawn	-		Checked	-	
Date	27.06.23				
Scale	1:50			@A3	
Project Number	4033		Sheet Number	DR-04-003	Rev
					-

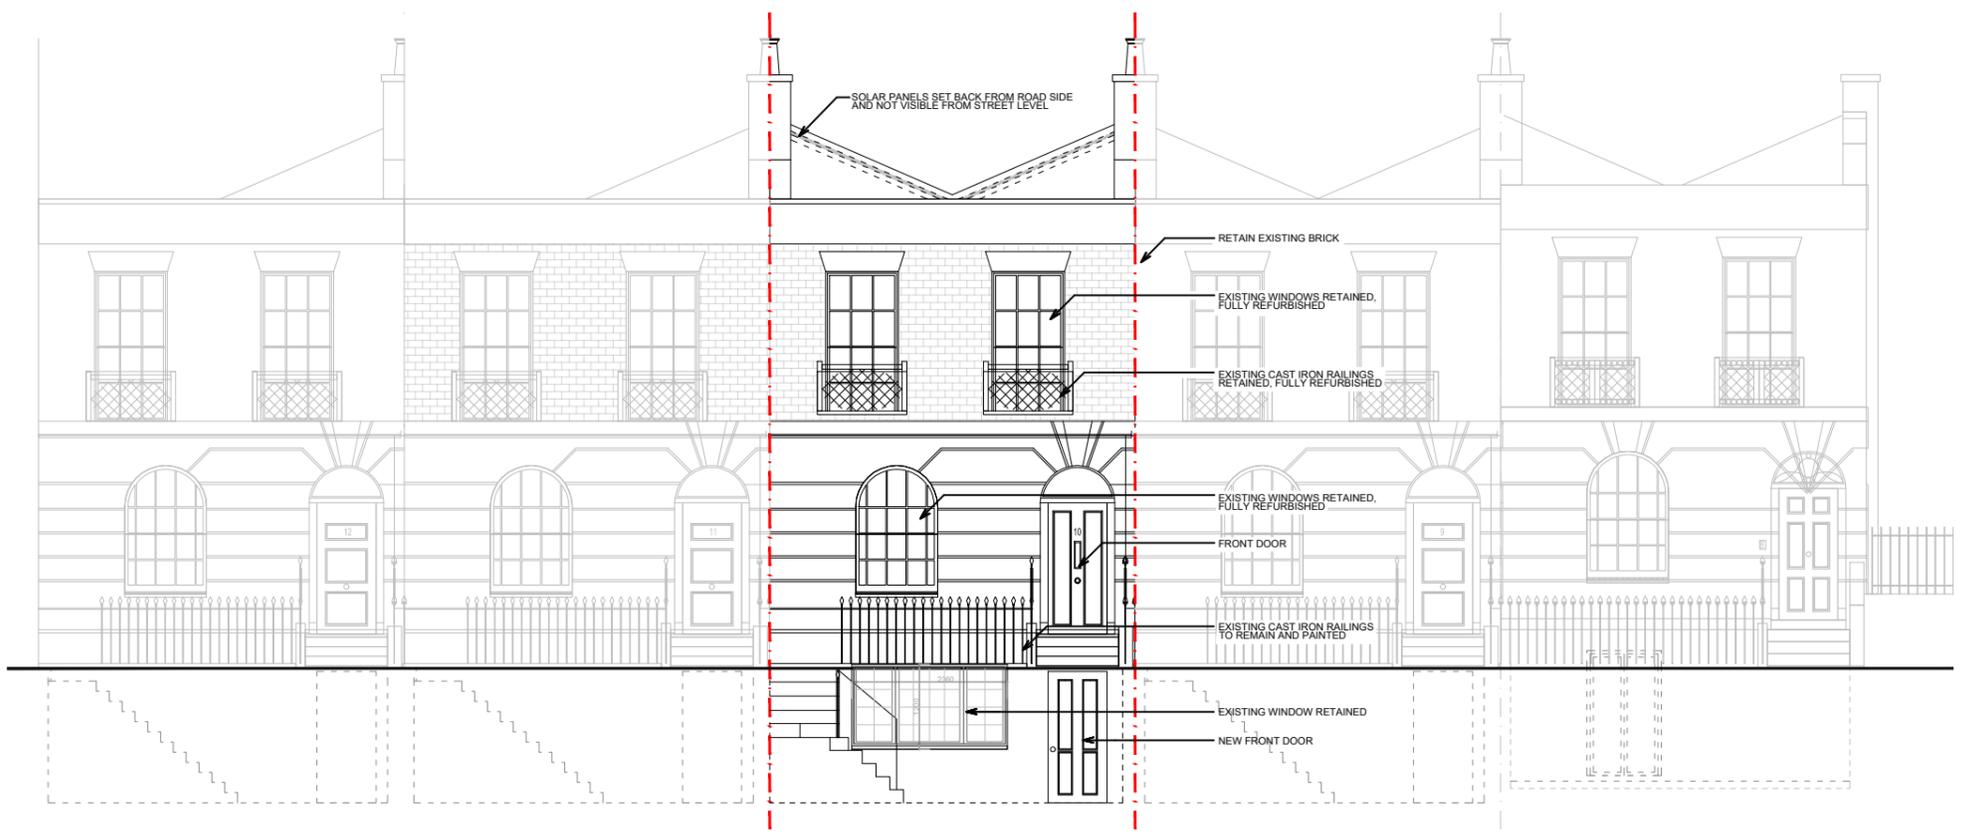

Front Elevation (South West) 1:100

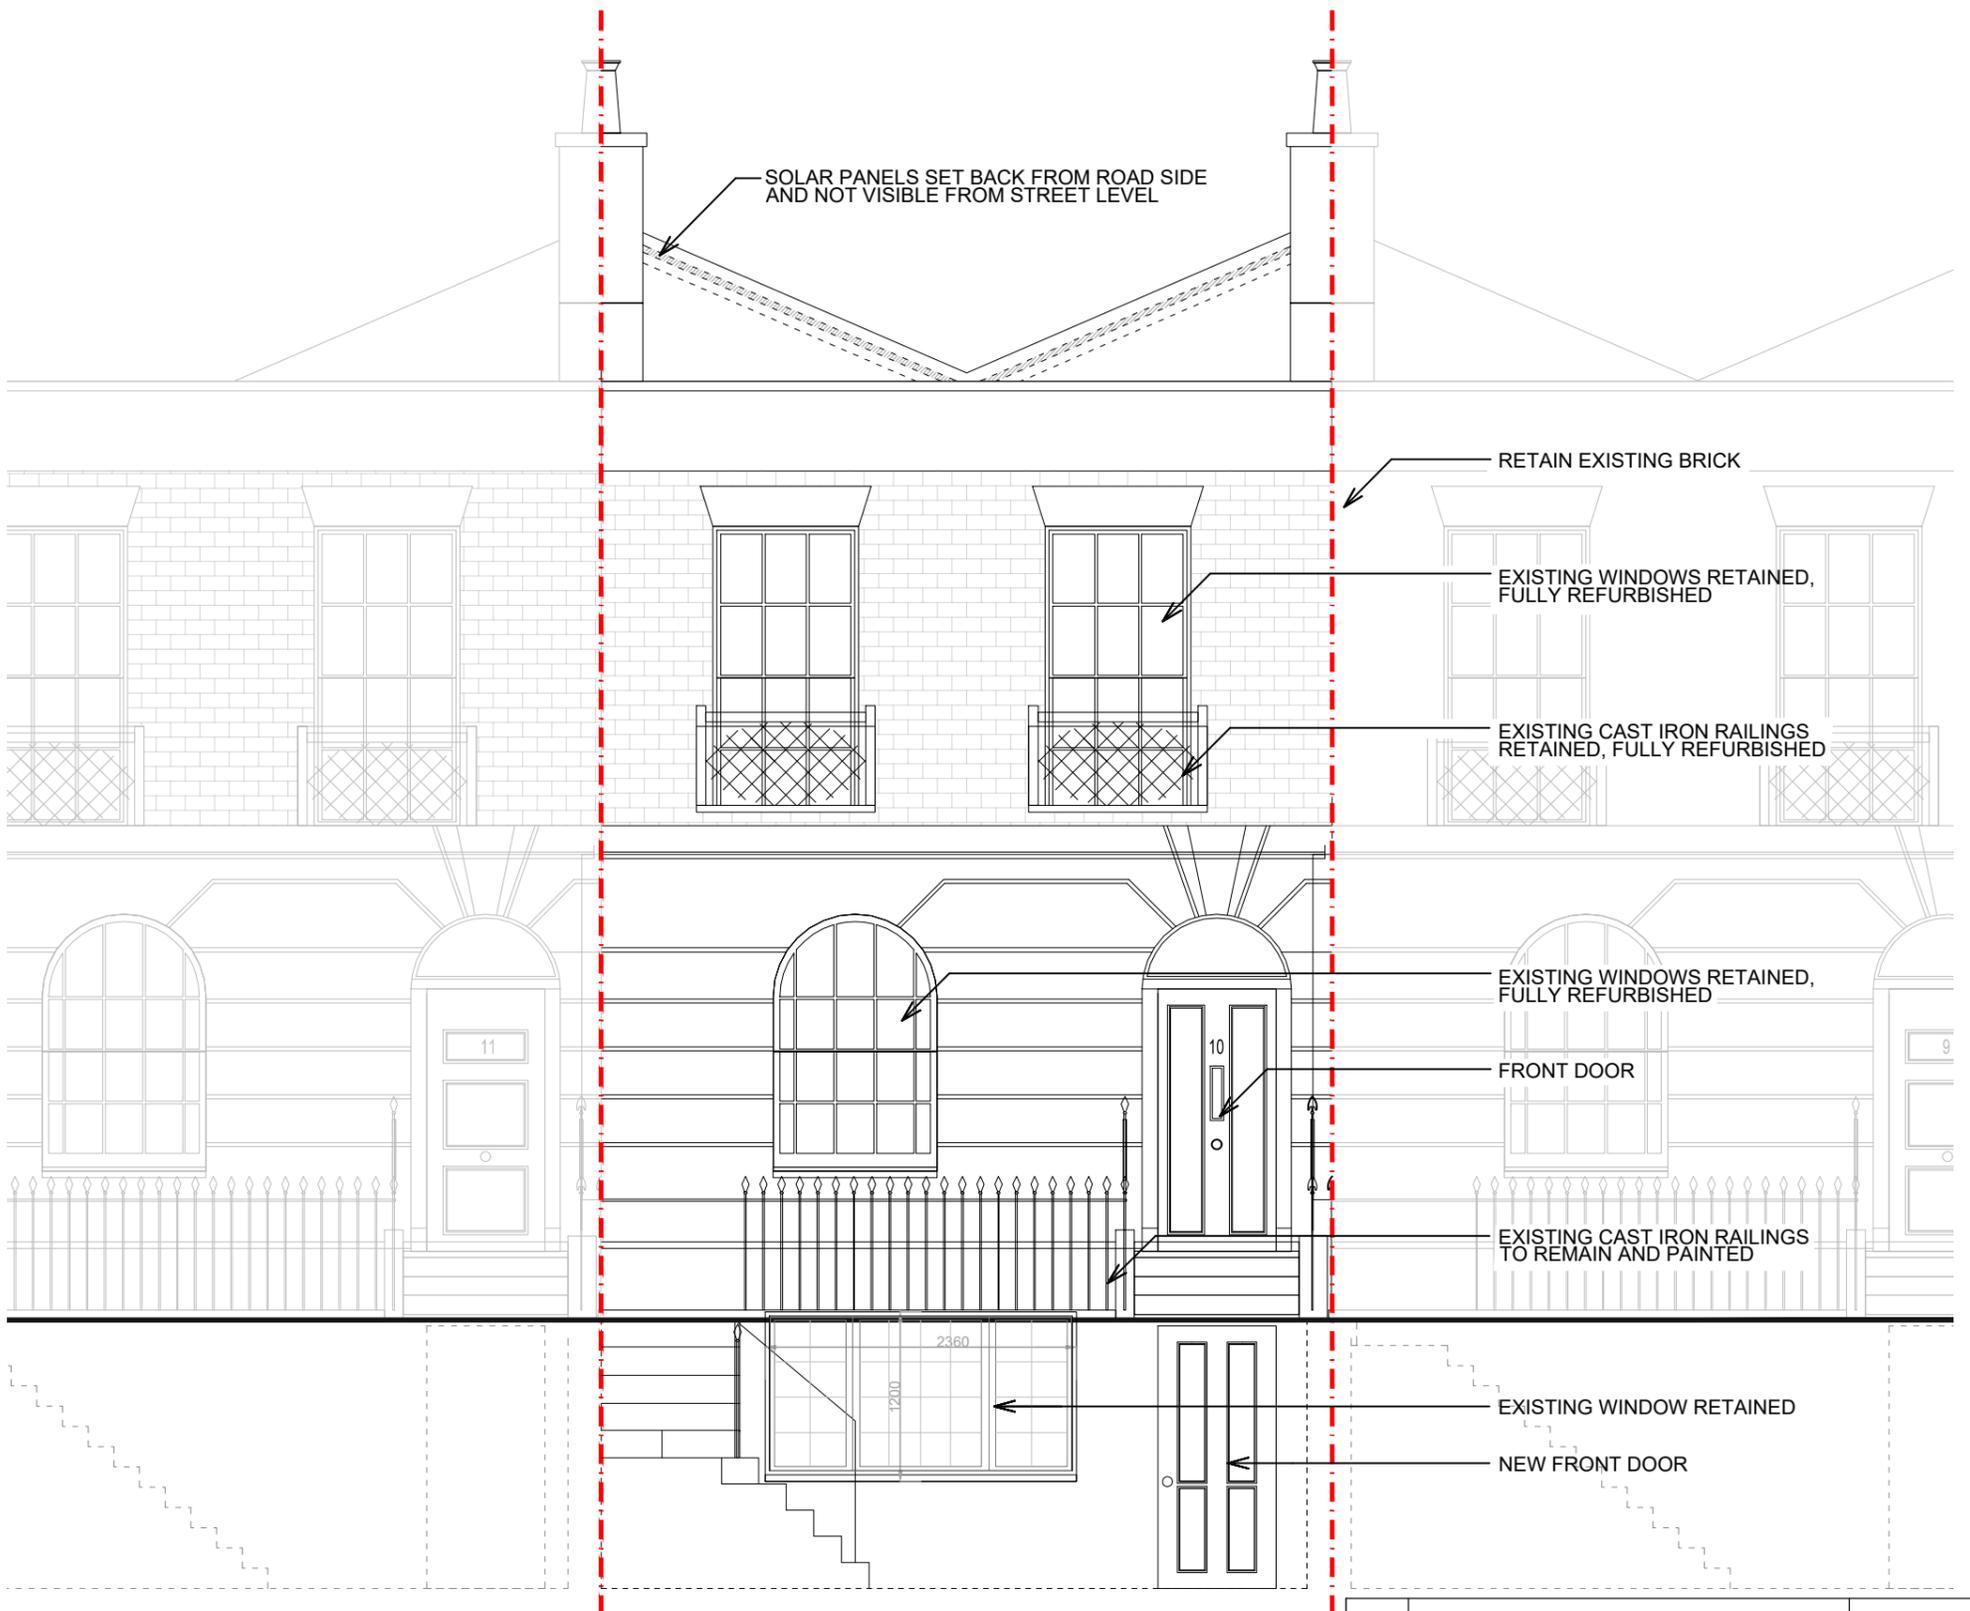

Front Elevation (South West) 1:50



**PROJECT:**  
10 Thanet St. London WC1H 9QL  
**DRAWING NAME:**  
Proposed Front (South West) Elevation  
**NOTES:**  
Orientated to fit sheet size, 1:50@A3


© Copyright Once Printed and distributed this document is assumed uncontrolled.  
© All rights reserved. No part of this drawing may be reproduced or transmitted in any form by any means without the written permission of the copyright holder.

B	UPDATED AS PER COMMENTS	14.10.2023
REV	DESCRIPTION	DATE

Purpose of Issue INFORMATION		
Drawn	-	Checked -
Date	27.06.23	
Scale	1:50	@A3
Project Number	Sheet Number	Rev
4033	DR-05-002	B



Rear Elevation (South West) 1:100

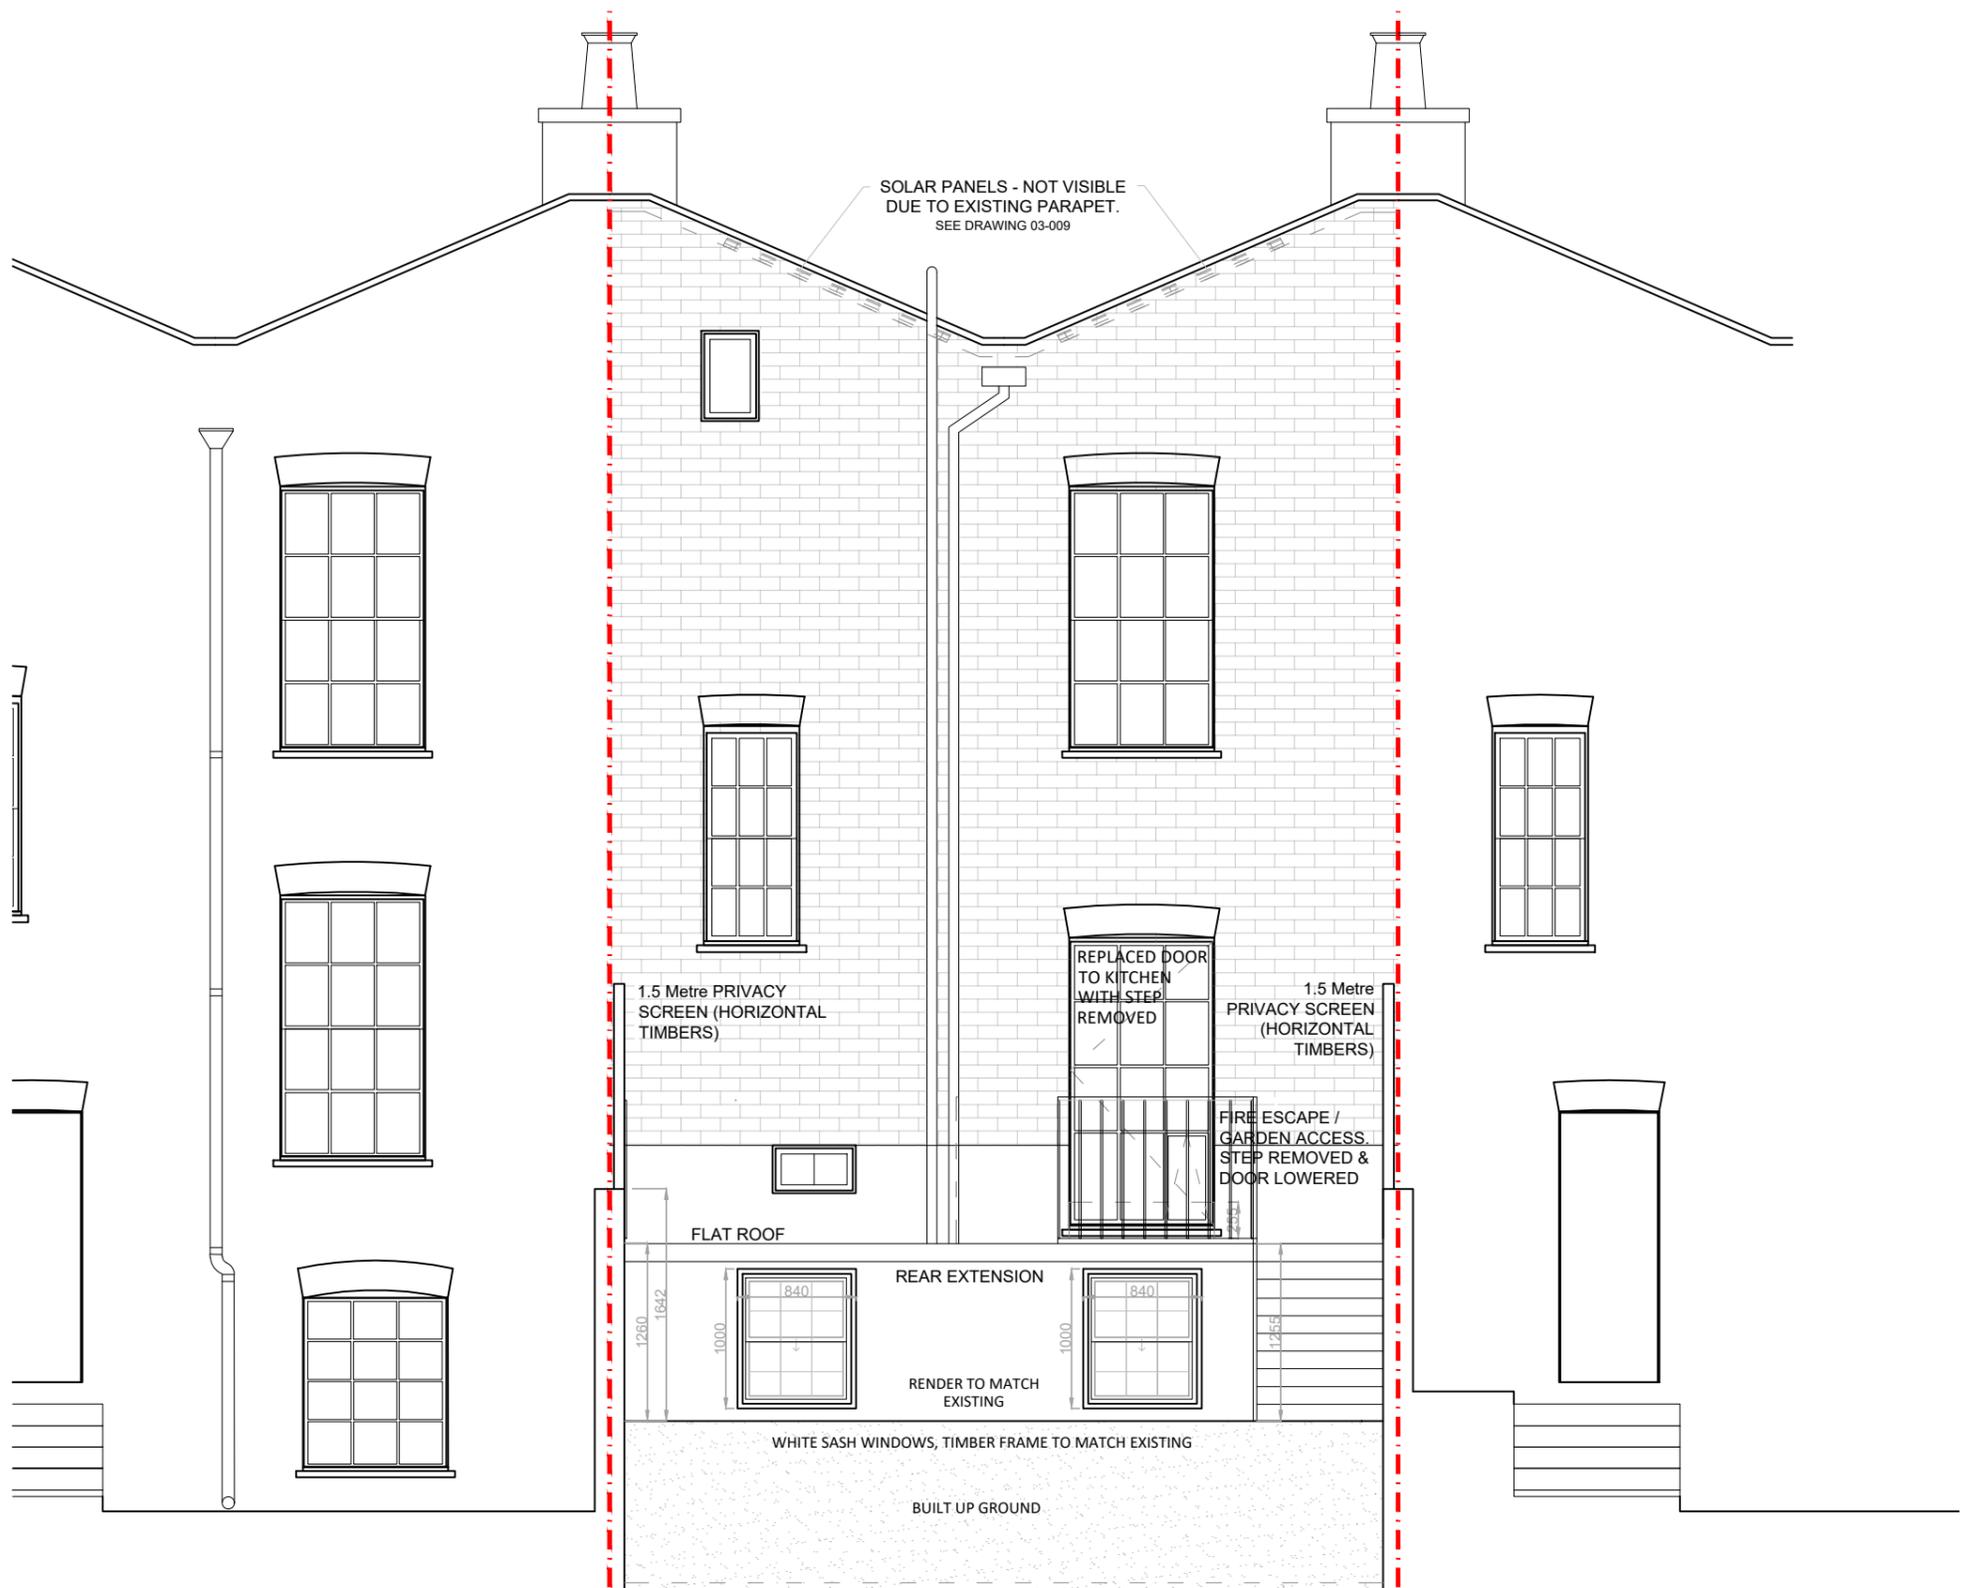

Rear Elevation (South West) 1:50




**PROJECT:**  
10 Thanet St. London WC1H 9QL  
**DRAWING NAME:**  
Proposed Rear (North East) Elevation  
**NOTES:**  
Orientated to fit sheet size, 1:50@A3


© Copyright Once Printed and distributed this document is assumed uncontrolled.  
© All rights reserved. No part of this drawing may be reproduced or transmitted in any form by any means without the written permission of the copyright holder.

C	UPDATED AS PER COMMENTS	15.10.2023
REV	DESCRIPTION	DATE

Purpose of Issue INFORMATION		
Drawn	-	Checked -
Date	27.06.23	
Scale	1:50	@A3
Project Number	Sheet Number	Rev
4033	DR-05-004	C

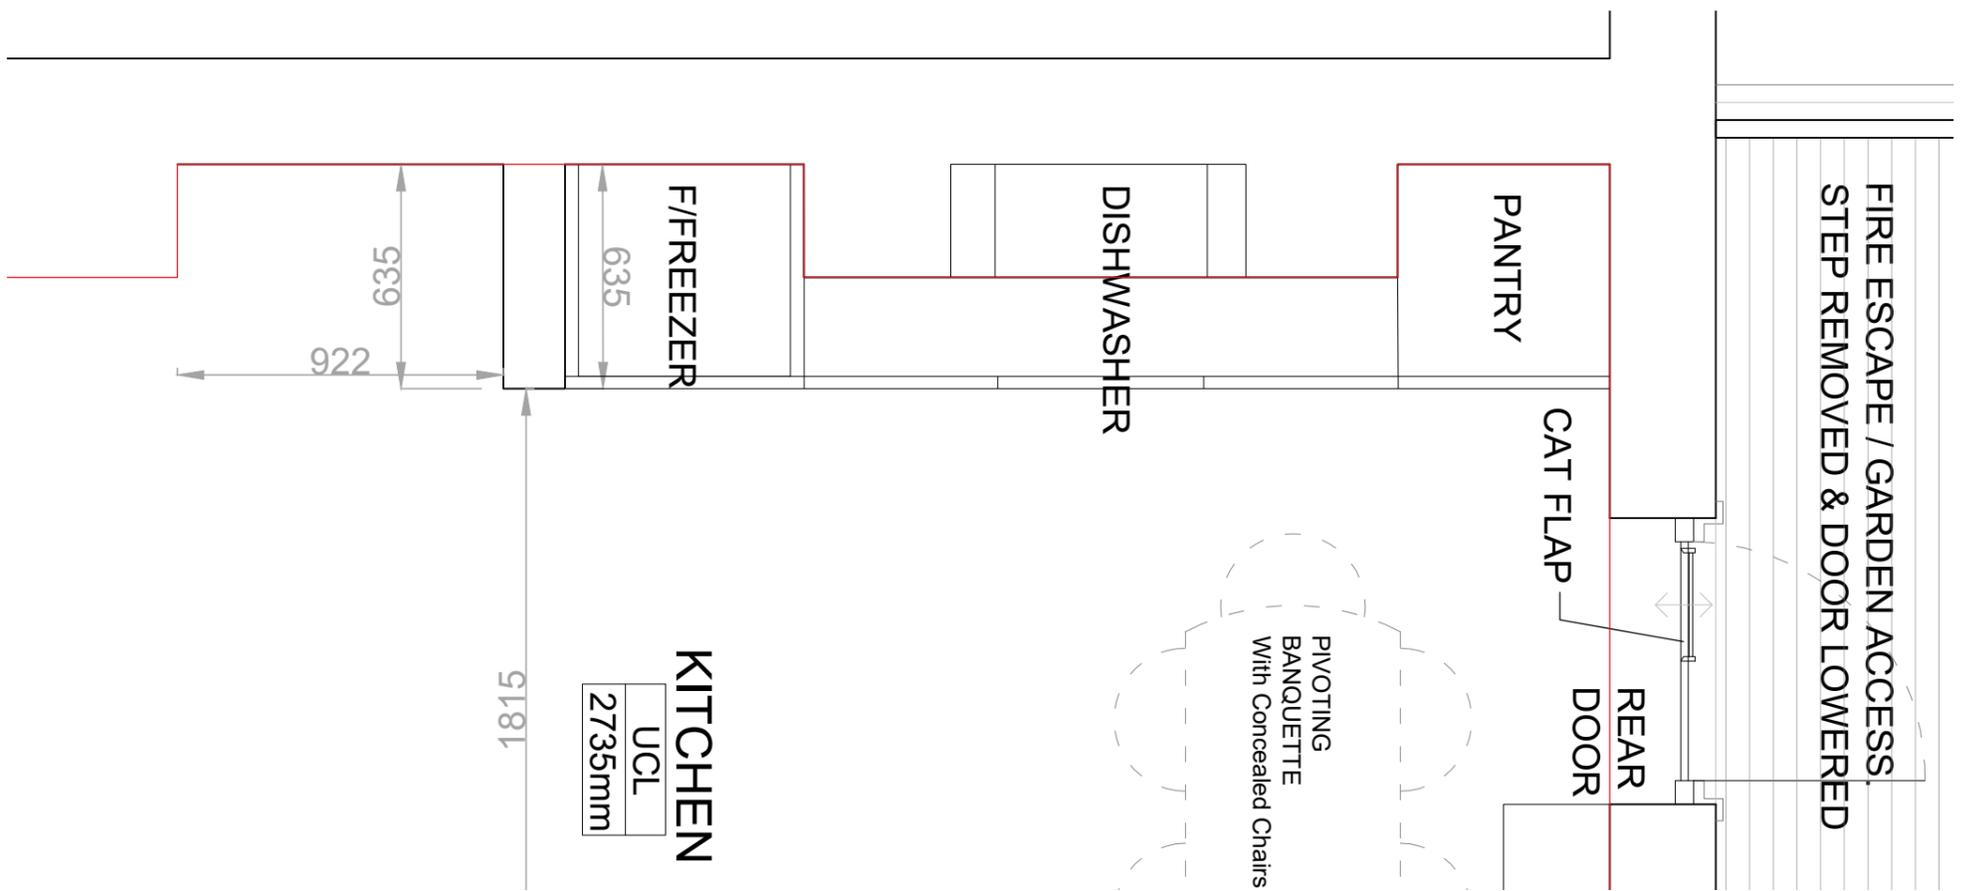

Kitchen Reference Plan 1:20

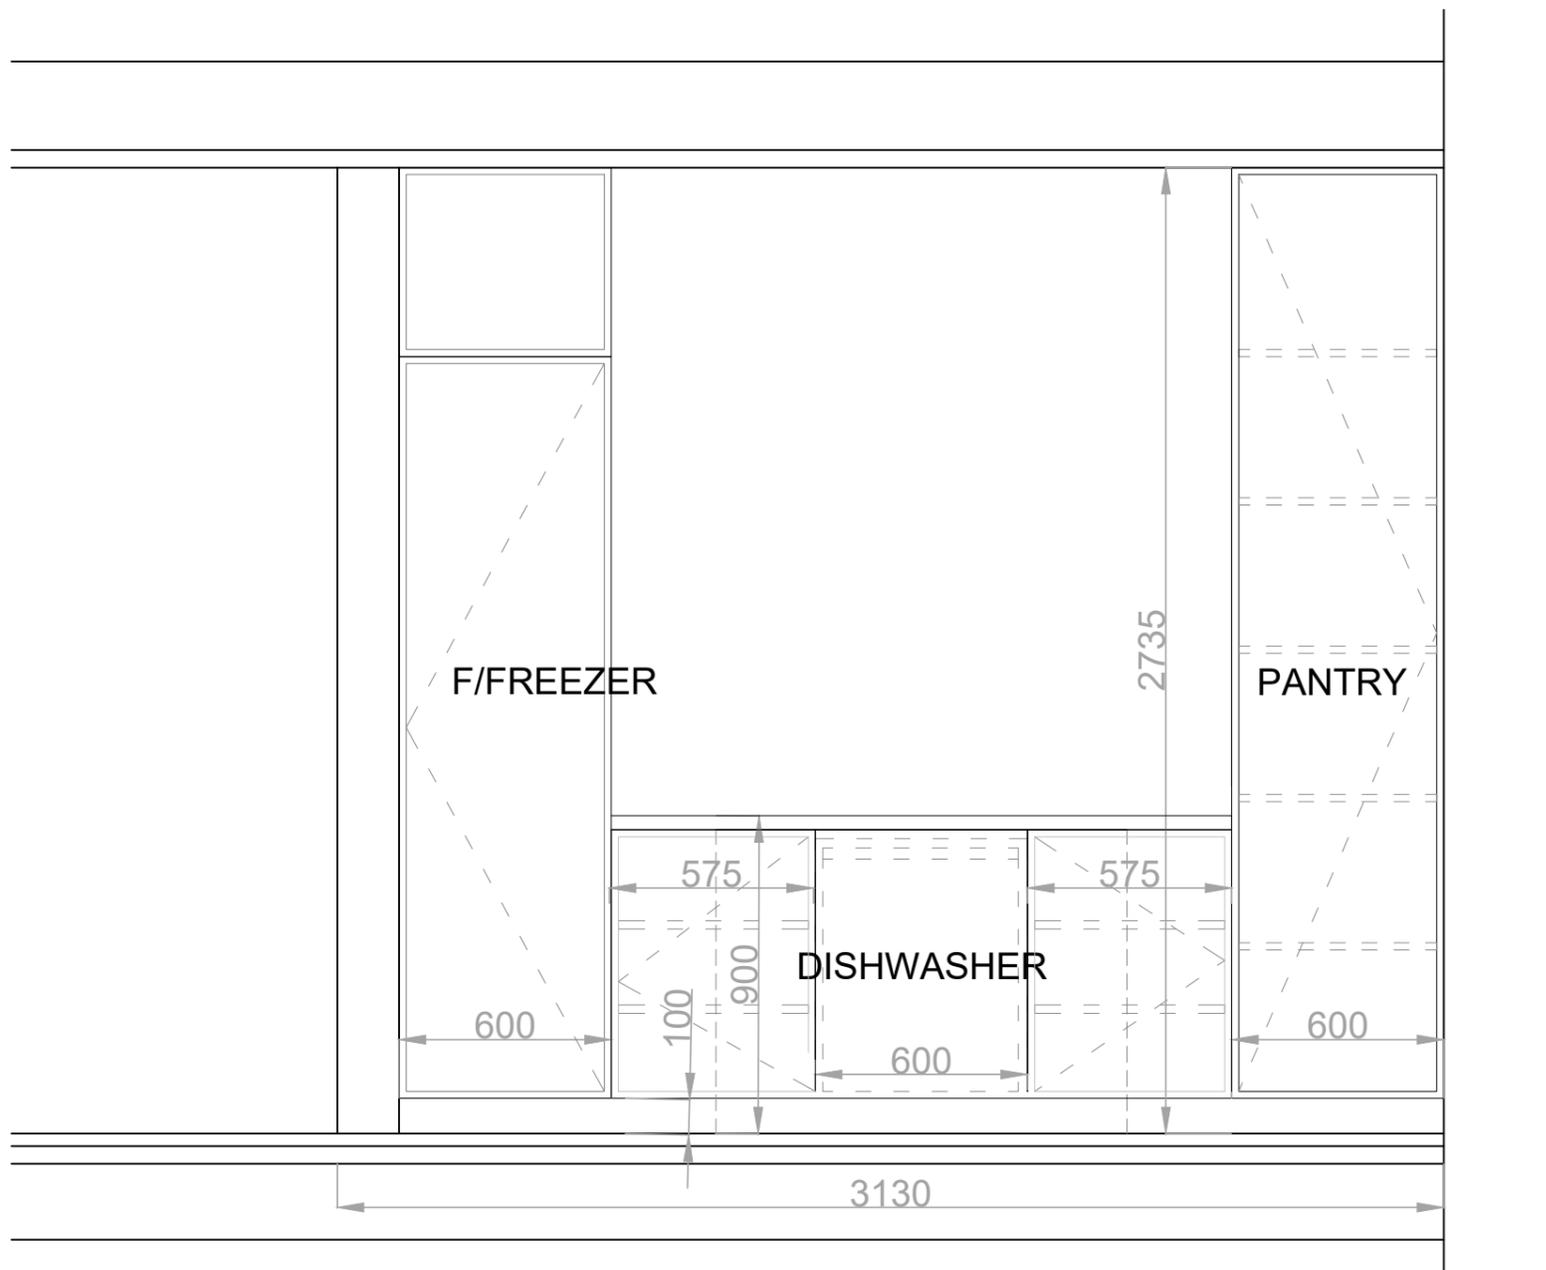

Kitchen Elevation 1:20

B	UPDATED AS PER COMMENTS	14.10.2023
REV	DESCRIPTION	DATE

Purpose of Issue			INFORMATION		
Drawn	-	Checked	-		
Date	27.06.23				
Scale	1:20	@A3			
Project Number	4033	Sheet Number	DR-05-005	Rev	B




insideout

**PROJECT:**  
10 Thanet St. London WC1H 9QL

**DRAWING NAME:**  
Proposed Kitchen - Elevation

**NOTES:**  
Orientated to fit sheet size, 1:20@A3

© Copyright Once Printed and distributed this document is assumed uncontrolled.  
© All rights reserved. No part of this drawing may be reproduced or transmitted in any form by any means without the written permission of the copyright holder.

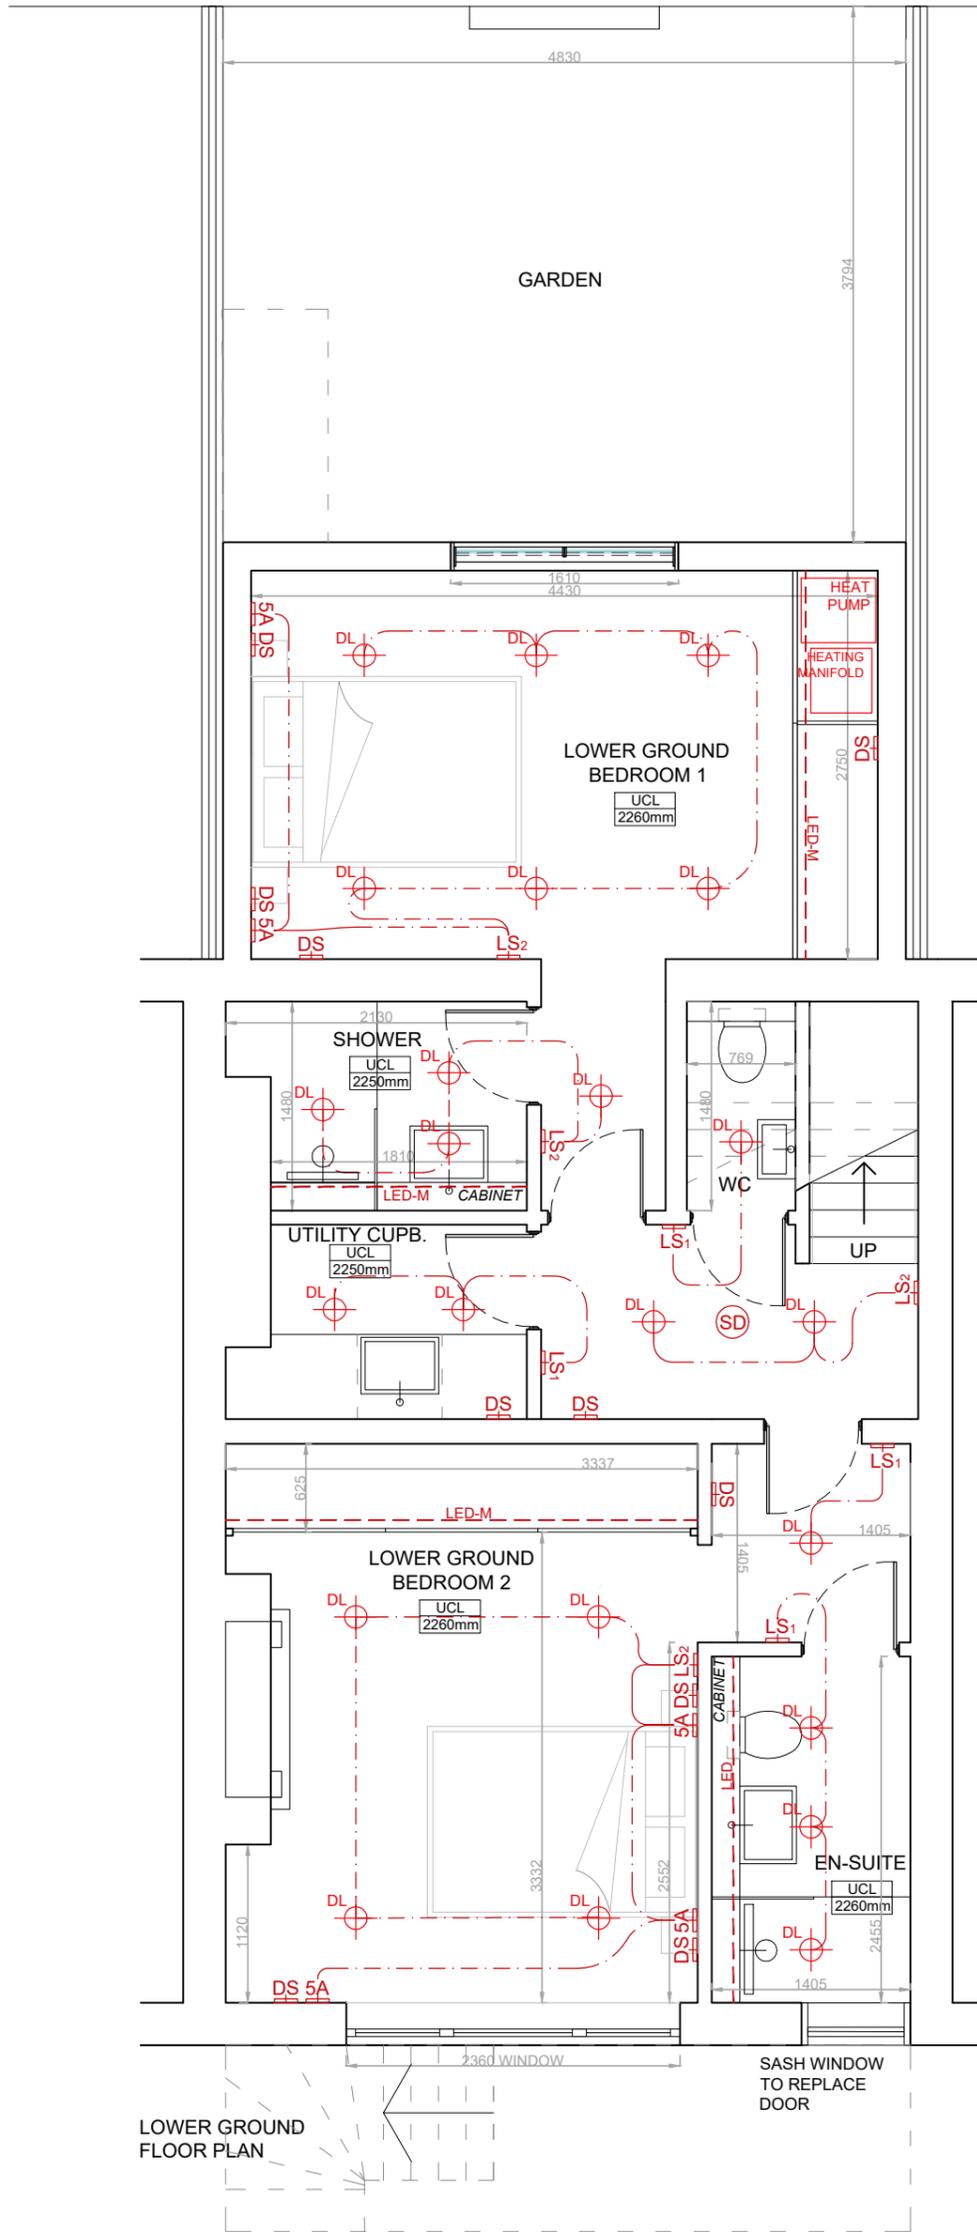

- LEGEND:**
- LS<sub>1</sub>** 1 Gang Light Switch
  - LS<sub>2</sub>** 2 Gang Light Switch
  - SS** Single Socket
  - DS** Double Socket
  - BT** RJ11 Socket
  - 5A** 5 Amp Socket
  - SH** Shaver Socket
  - SD** Mains Wired Smoke Detector (Battery back-up)
  - HD** Mains Wired Heat Detector (Battery back-up)
  - P** Pendant Light
  - DL** IP65 Recessed Downlight
  - LED** Recessed LED's
  - LED-M** Recessed LED's - Motion Activated




**PROJECT:**  
10 Thanet St. London WC1H 9QL

**DRAWING NAME:**  
Proposed Lower Ground Floor Electrical Plan

**NOTES:**  
Orientated to fit sheet size, 1:50@A3

© Copyright Once Printed and distributed this document is assumed uncontrolled.  
© All rights reserved. No part of this drawing may be reproduced or transmitted in any form by any means without the written permission of the copyright holder.

Purpose of Issue			INFORMATION		
Drawn	-		Checked	-	
Date	27.06.23				
Scale	1:50			@A3	
Project Number	4033		Sheet Number	DR-60-001	Rev
					-

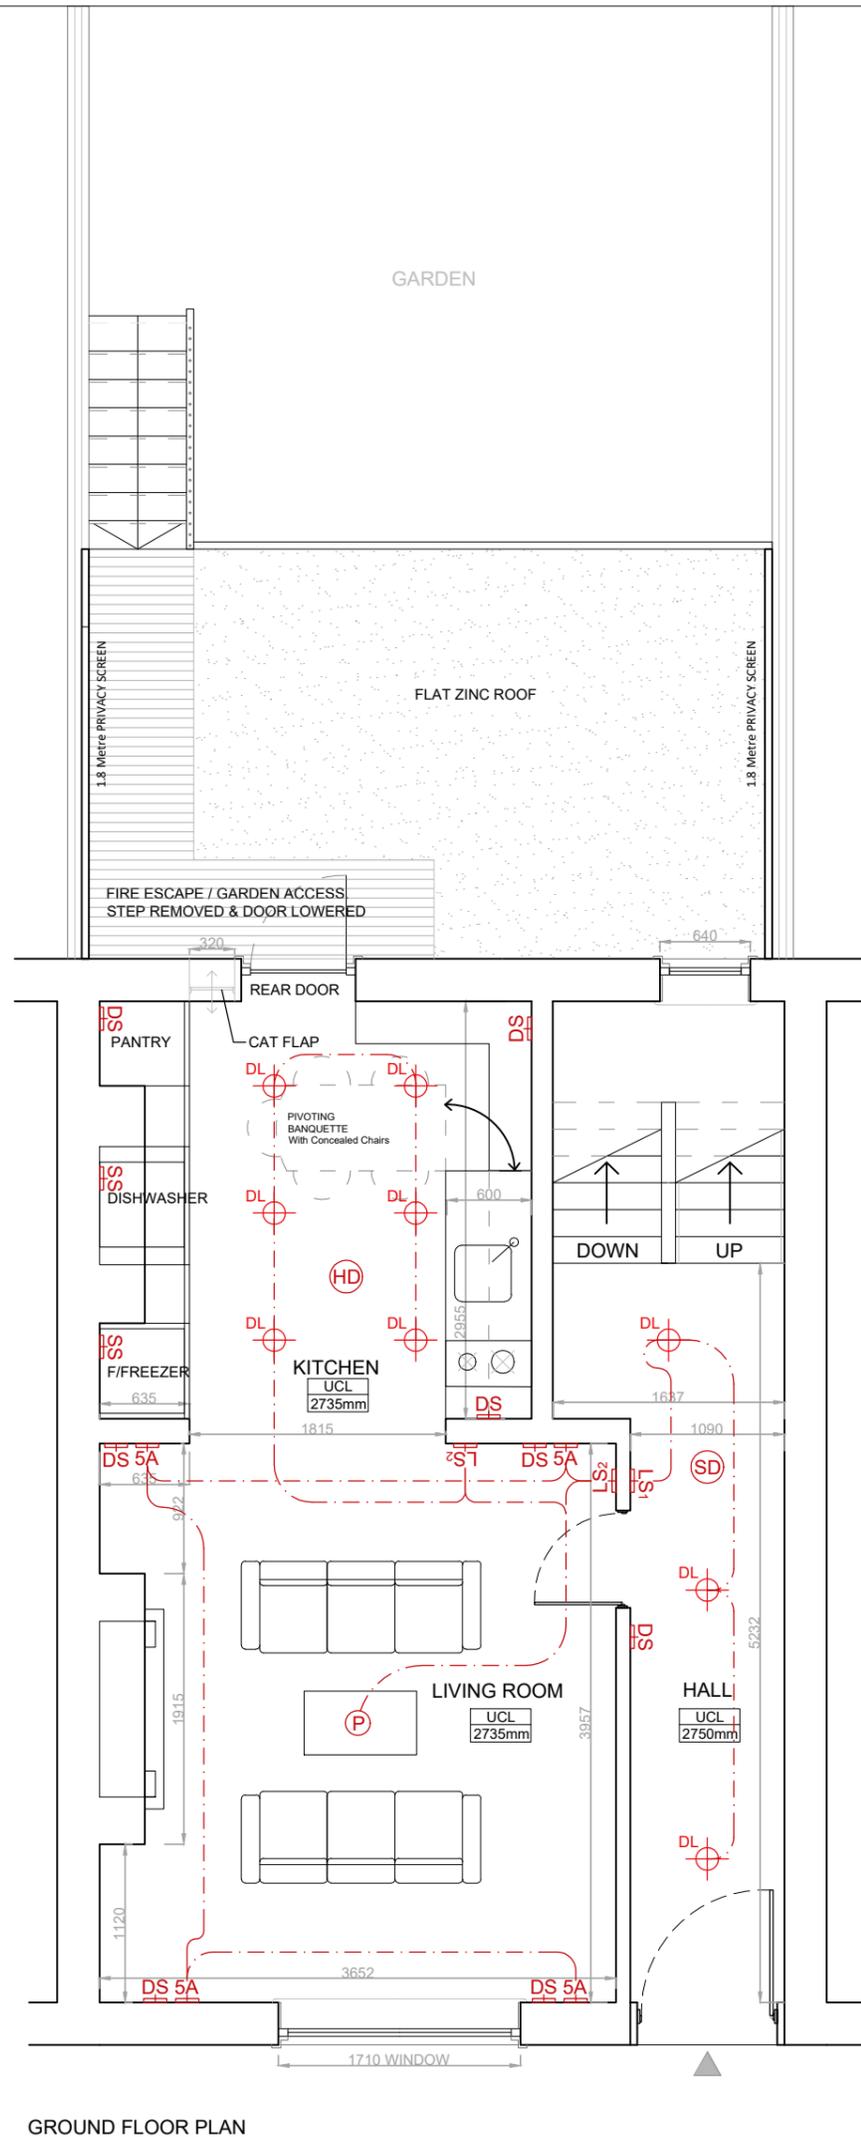

- LEGEND:**
- LS1** 1 Gang Light Switch
  - LS2** 2 Gang Light Switch
  - SS** Single Socket
  - DS** Double Socket
  - BT** RJ11 Socket
  - 5A** 5 Amp Socket
  - SH** Shaver Socket
  - SD** Mains Wired Smoke Detector (Battery back-up)
  - HD** Mains Wired Heat Detector (Battery back-up)
  - P** Pendant Light
  - DL** IP65 Recessed Downlight
  - LED** Recessed LED's
  - LED-M** Recessed LED's - Motion Activated

GROUND FLOOR PLAN




**PROJECT:**  
10 Thanet St. London WC1H 9QL

**DRAWING NAME:**  
Proposed Ground Floor Electrical Plan

**NOTES:**  
Orientated to fit sheet size, 1:50@A3

© Copyright Once Printed and distributed this document is assumed uncontrolled.  
© All rights reserved. No part of this drawing may be reproduced or transmitted in any form by any means without the written permission of the copyright holder.

Purpose of Issue			INFORMATION		
Drawn	-		Checked	-	
Date	27.06.23				
Scale	1:50			@A3	
Project Number	4033		Sheet Number	DR-60-002	Rev
					-

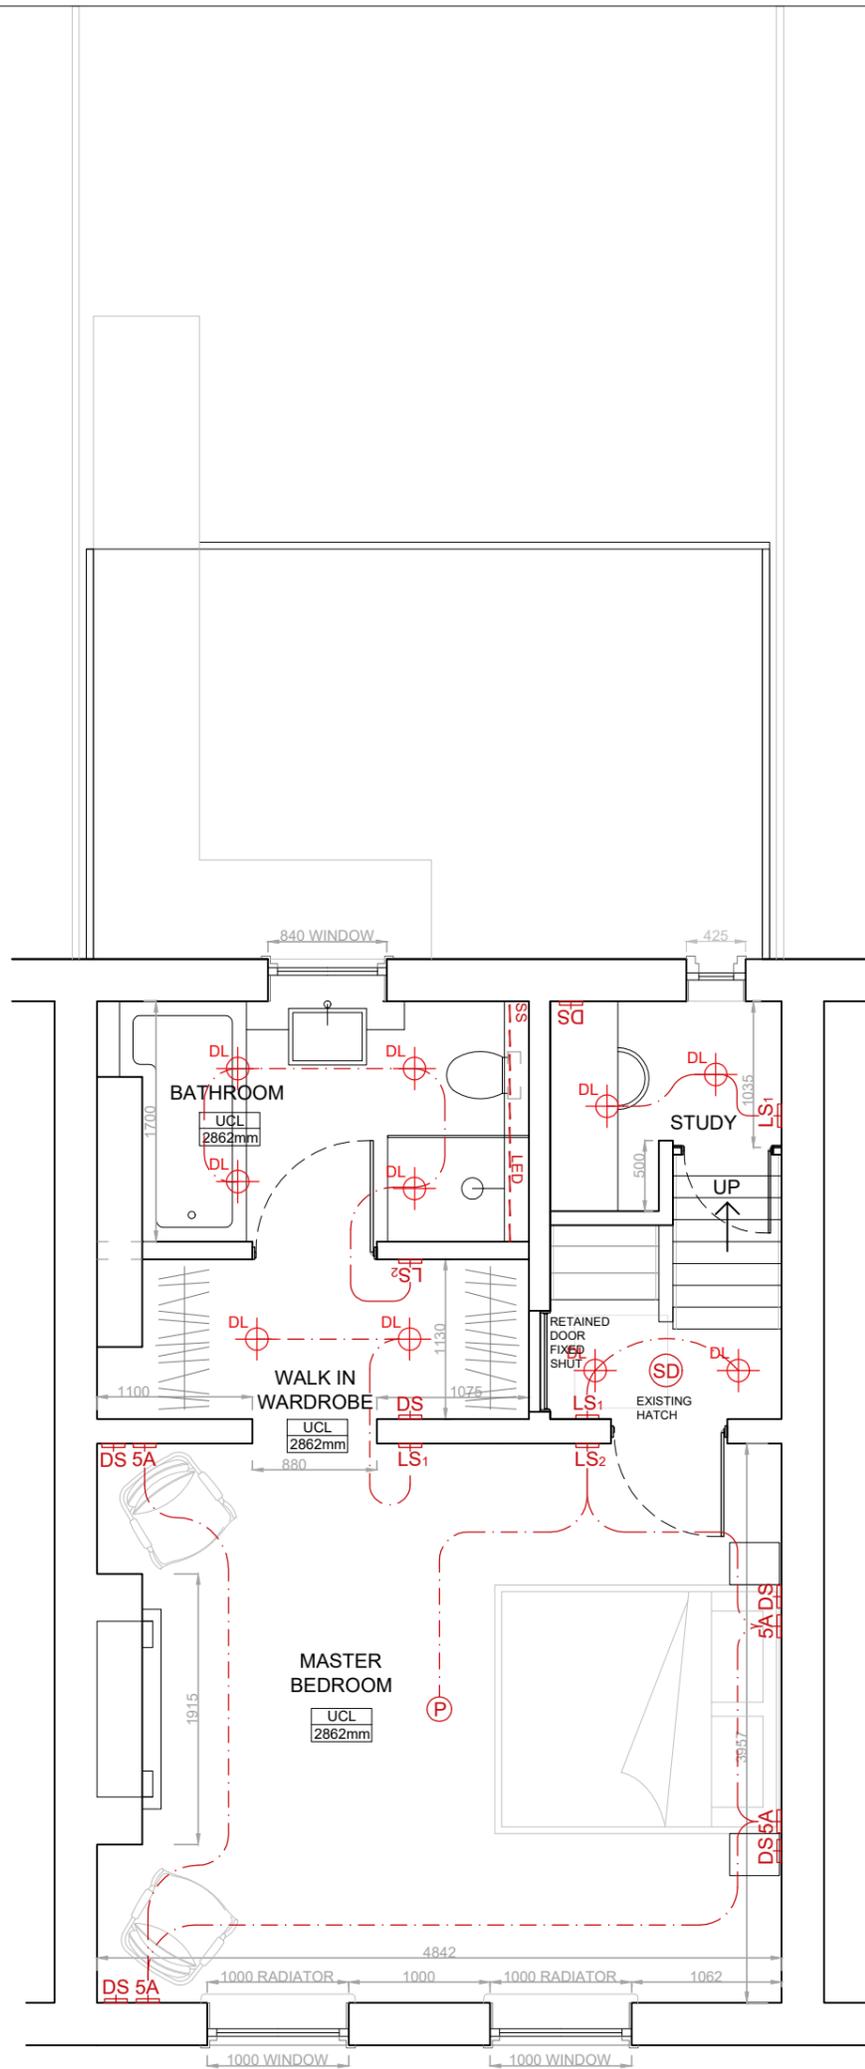

FIRST FLOOR PLAN

**LEGEND:**

- LS1** 1 Gang Light Switch
- LS2** 2 Gang Light Switch
- SS** Single Socket
- DS** Double Socket
- BT** RJ11 Socket
- 5A** 5 Amp Socket
- SH** Shaver Socket
- SD** Mains Wired Smoke Detector (Battery back-up)
- HD** Mains Wired Heat Detector (Battery back-up)
- P** Pendant Light
- DL** IP65 Recessed Downlight
- LED** Recessed LED's
- LED-M** Recessed LED's - Motion Activated



**PROJECT:**

10 Thanet St. London WC1H 9QL

**DRAWING NAME:**


Proposed First Floor Electrical Plan

**NOTES:**

Orientated to fit sheet size, 1:50@A3

© Copyright Once Printed and distributed this document is assumed uncontrolled.  
 © All rights reserved. No part of this drawing may be reproduced or transmitted in any form by any means without the written permission of the copyright holder.

Purpose of Issue INFORMATION		
Drawn	-	Checked -
Date	27.06.23	
Scale	1:50	@A3
Project Number	Sheet Number	Rev
4033	DR-60-003	-

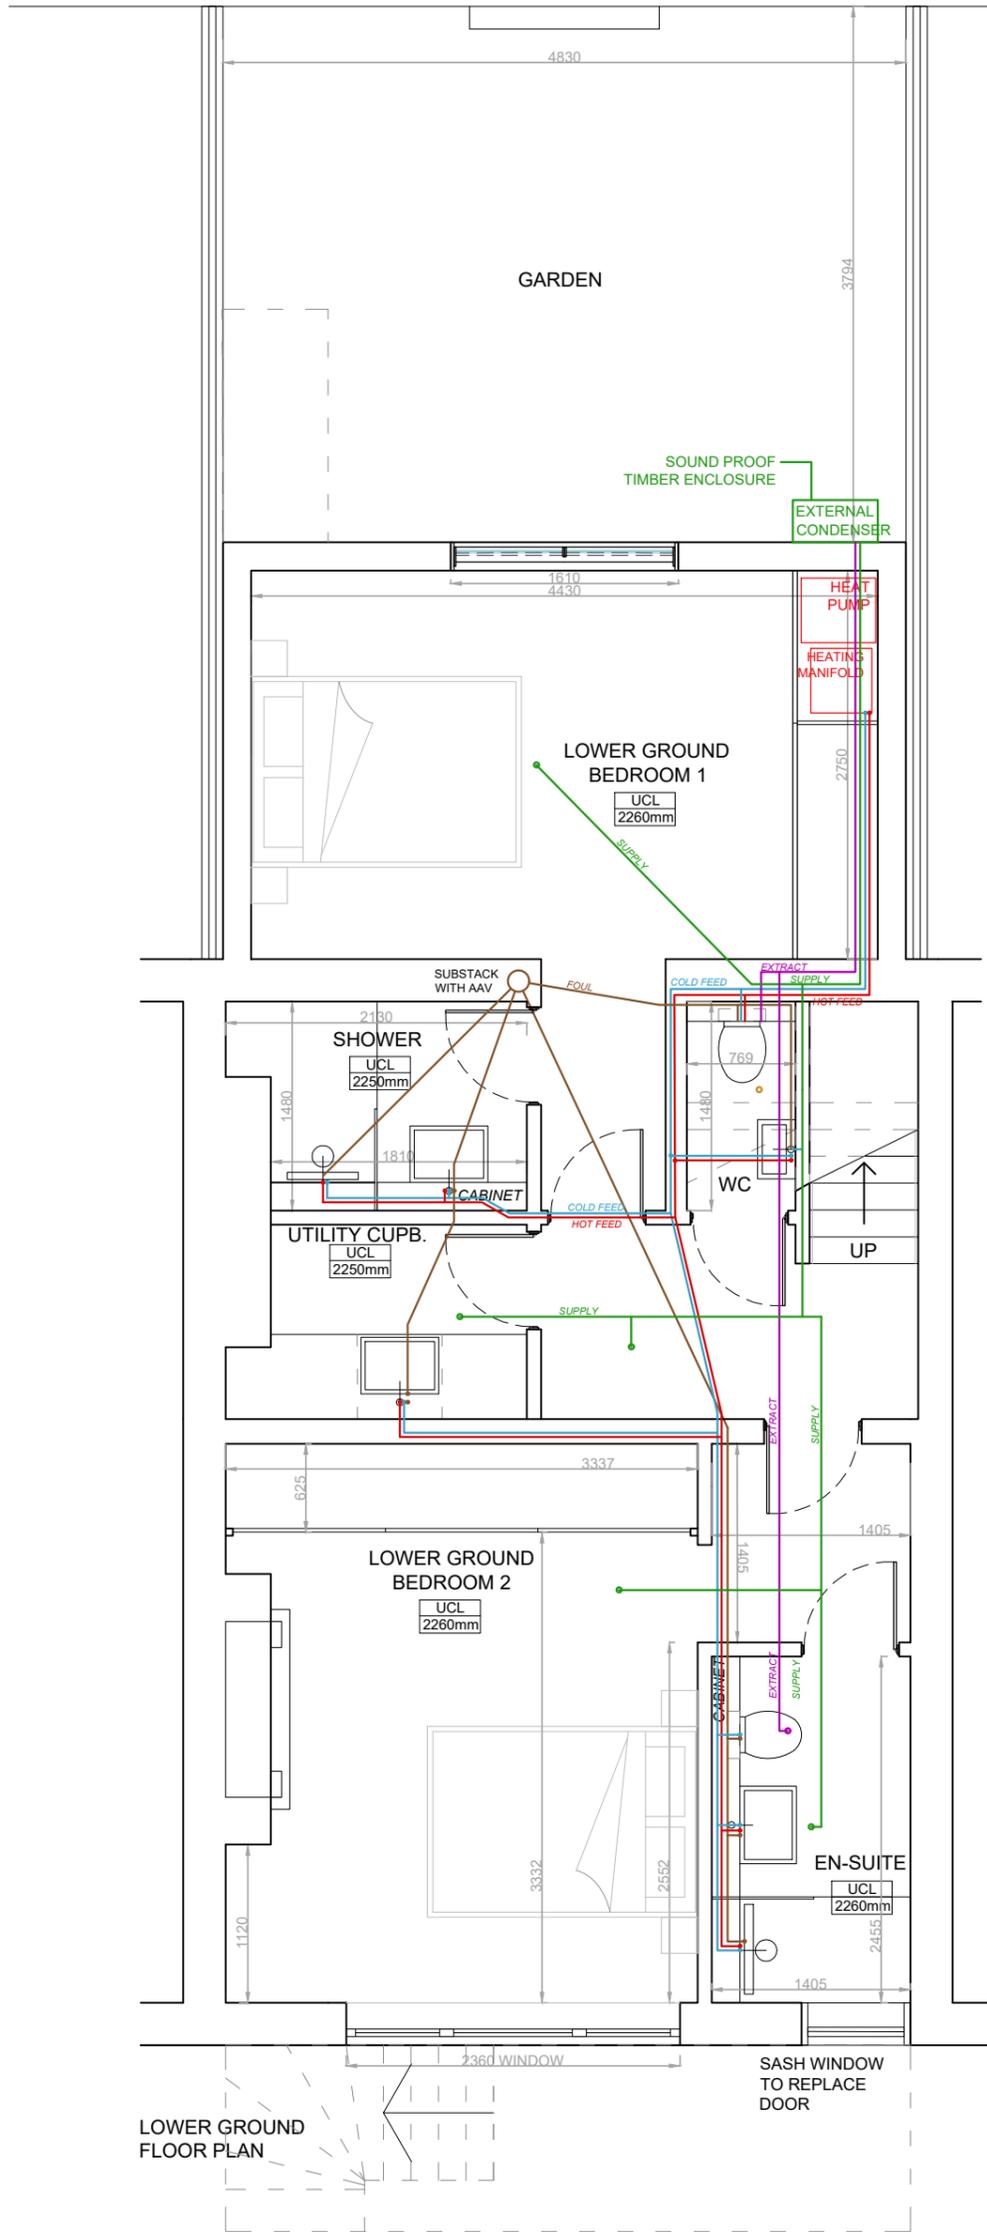


**PROJECT:**  
10 Thanet St. London WC1H 9QL

**DRAWING NAME:**  
Proposed Lower Ground Floor Services Schematic

**NOTES:**  
Orientated to fit sheet size, 1:50@A3

© Copyright Once Printed and distributed this document is assumed uncontrolled.  
© All rights reserved. No part of this drawing may be reproduced or transmitted in any form by any means without the written permission of the copyright holder.

Purpose of Issue			INFORMATION		
Drawn	-		Checked	-	
Date	27.06.23				
Scale	1:50			@A3	
Project Number	4033		Sheet Number	DR-65-001	Rev
					-

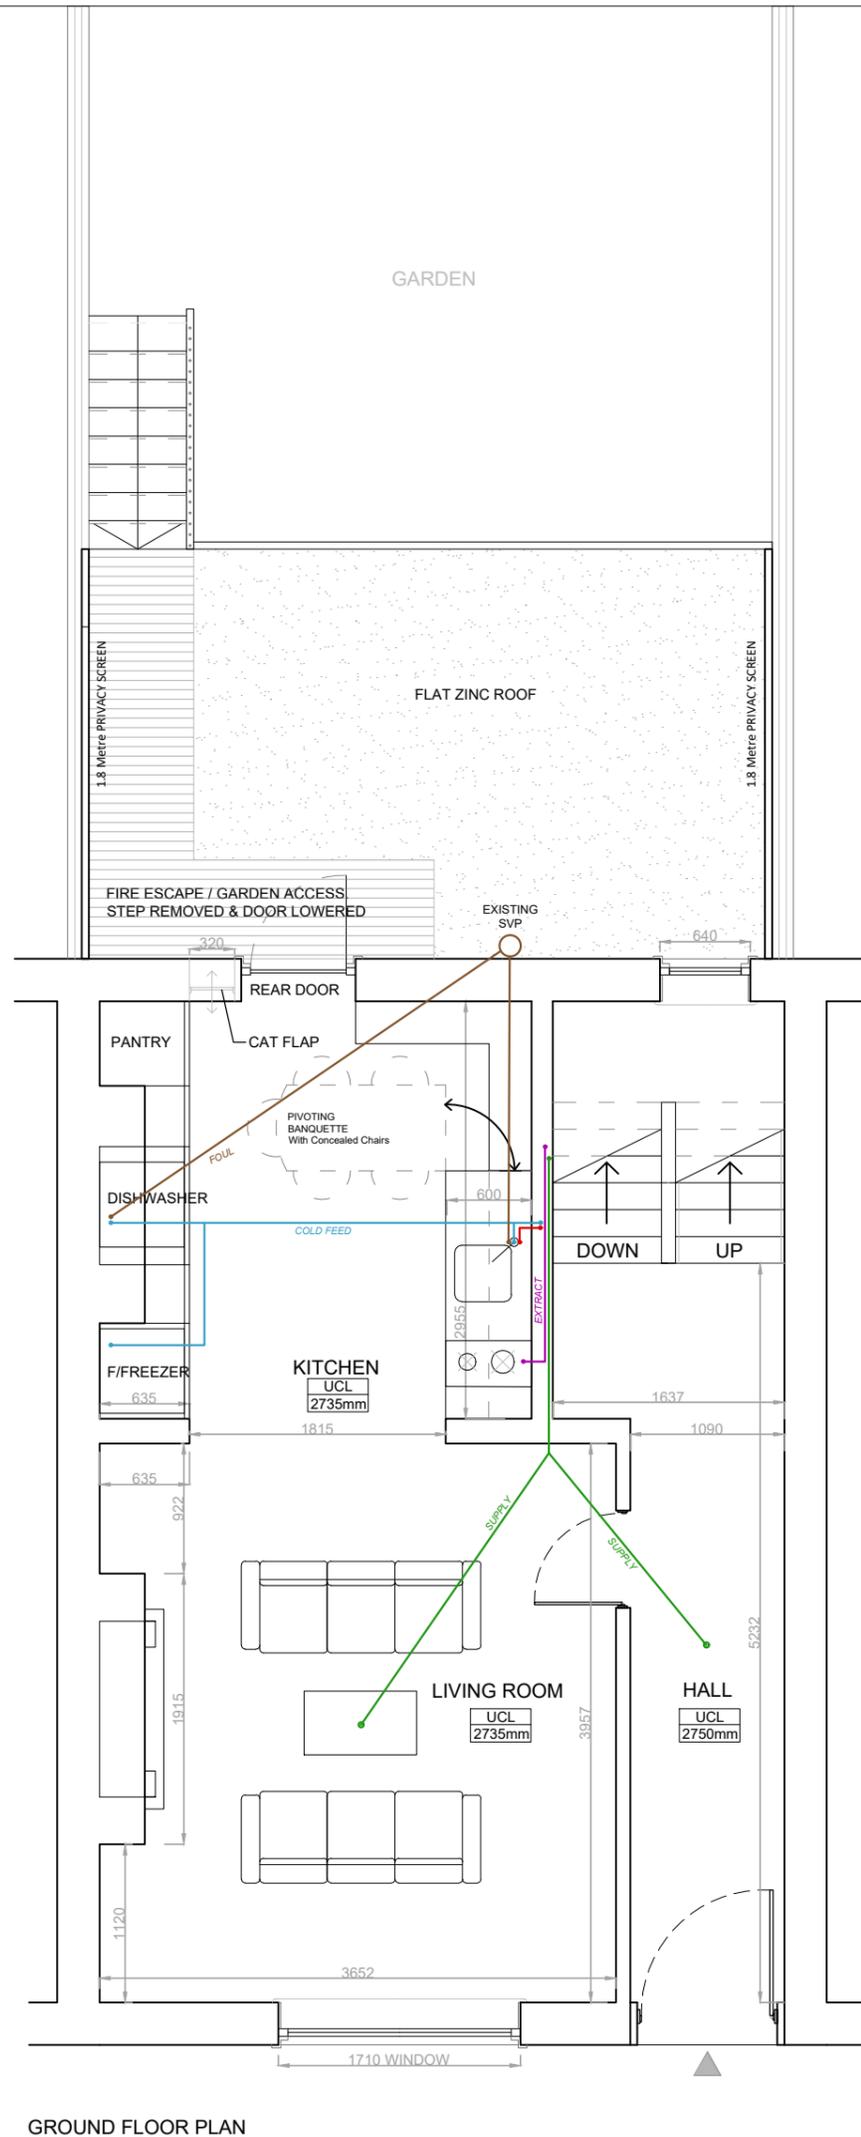

GROUND FLOOR PLAN




**PROJECT:**  
10 Thanet St. London WC1H 9QL

**DRAWING NAME:**  
Proposed Ground Floor Services Schematic

**NOTES:**  
Orientated to fit sheet size, 1:50@A3

© Copyright Once Printed and distributed this document is assumed uncontrolled.  
© All rights reserved. No part of this drawing may be reproduced or transmitted in any form by any means without the written permission of the copyright holder.

Purpose of Issue			INFORMATION		
Drawn	-		Checked	-	
Date	27.06.23				
Scale	1:50			@A3	
Project Number	4033		Sheet Number	DR-65-002	Rev
					-

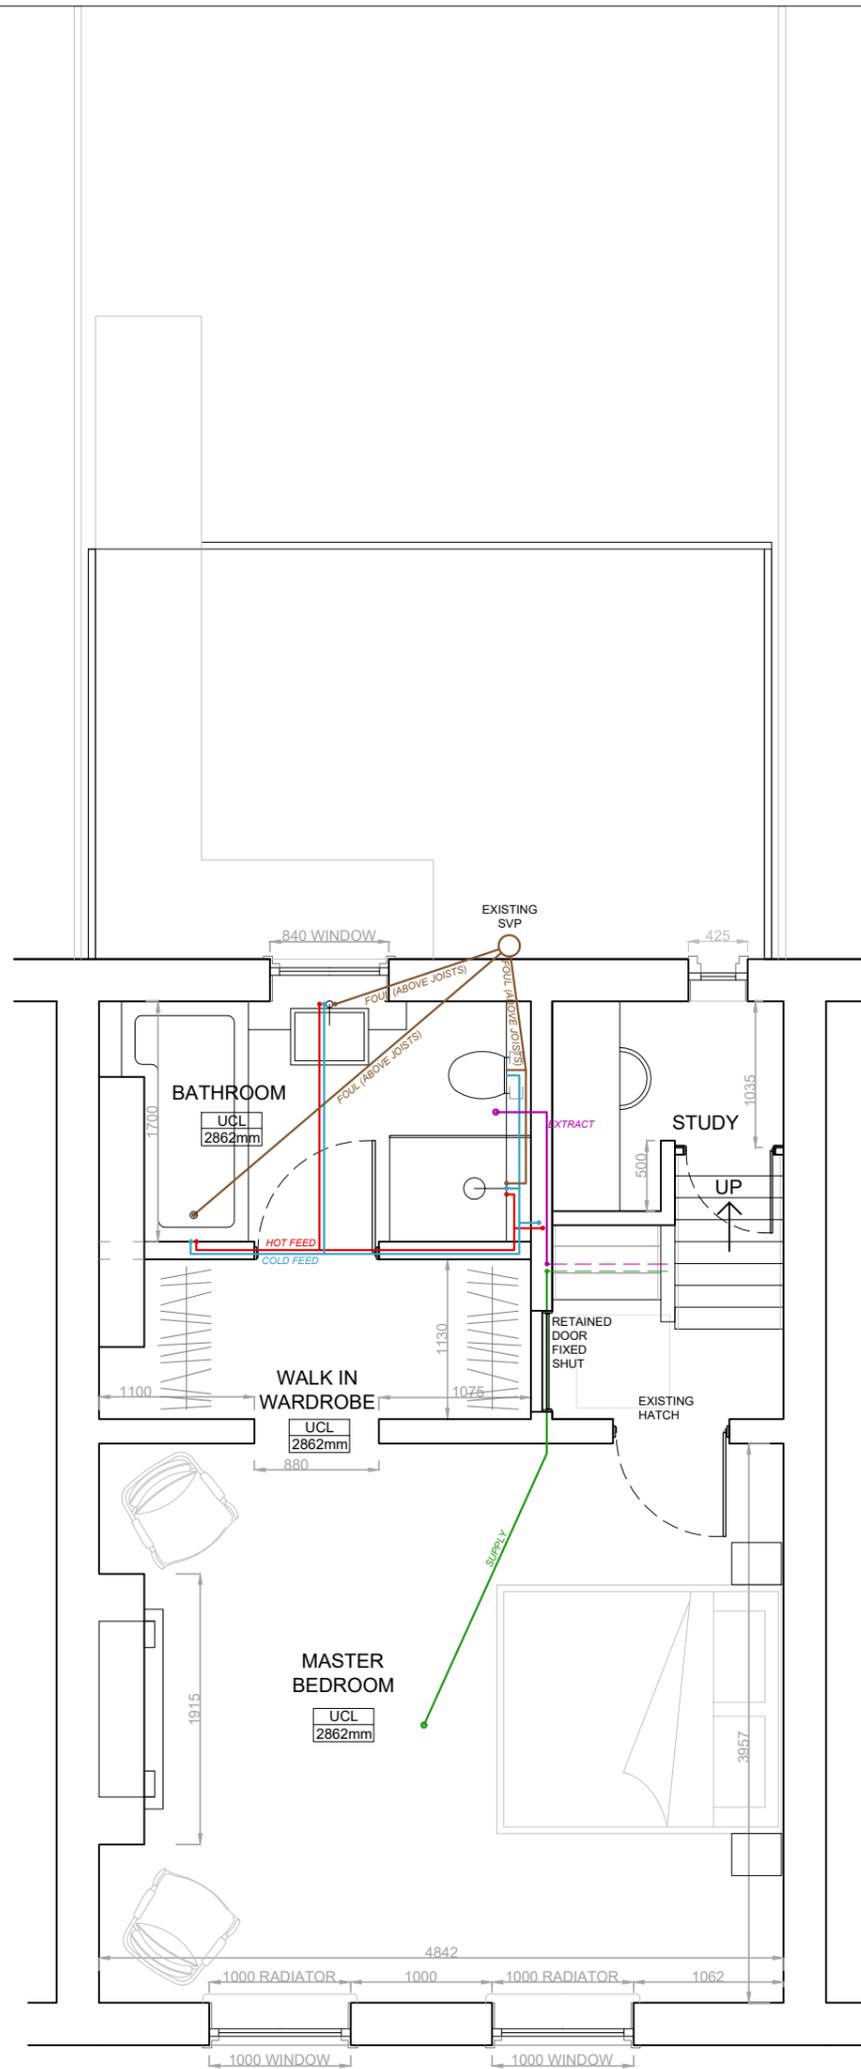



FIRST FLOOR PLAN



**PROJECT:**  
10 Thanet St. London WC1H 9QL  
**DRAWING NAME:**  
Proposed First Floor Services Schematic  
**NOTES:**  
Orientated to fit sheet size, 1:50@A3

© Copyright Once Printed and distributed this document is assumed uncontrolled.  
© All rights reserved. No part of this drawing may be reproduced or transmitted in any form by any means without the written permission of the copyright holder.

Purpose of Issue INFORMATION		
Drawn	-	Checked -
Date	27.06.23	
Scale	1:50	@A3
Project Number	4033	Sheet Number DR-65-003
		Rev -

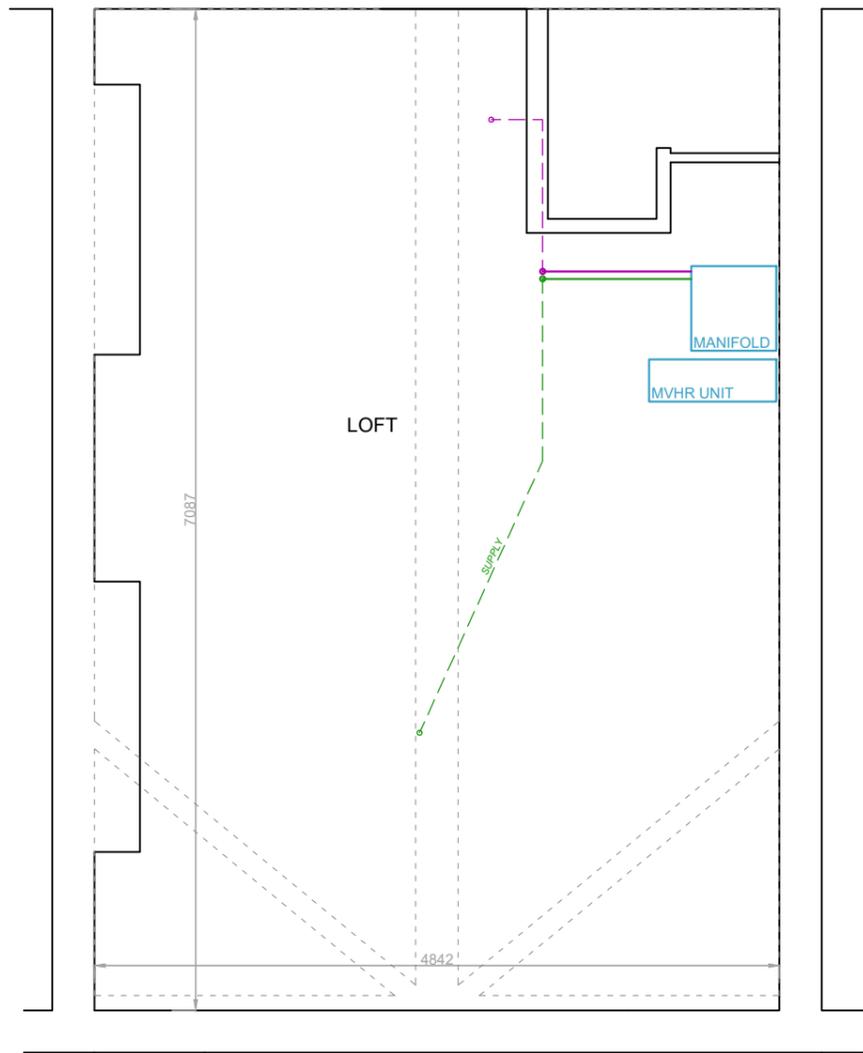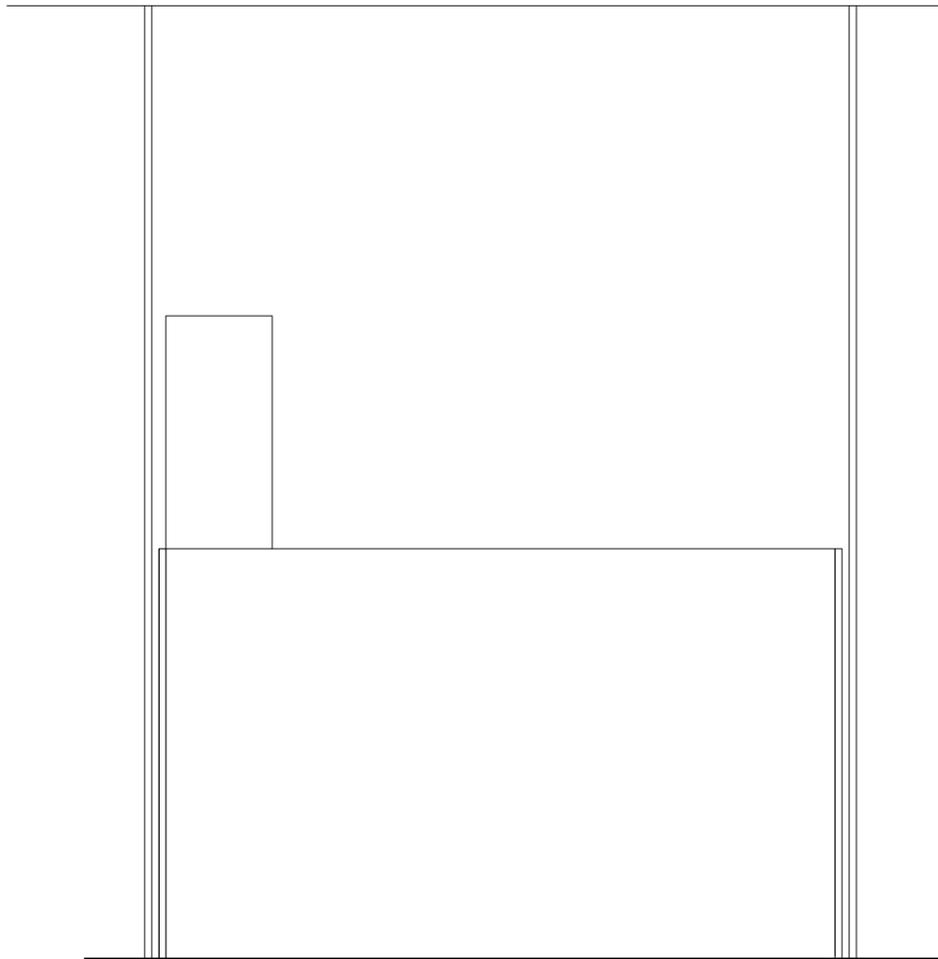

All extract and supply through 70mm ribbed ducting that does not cut through or maim any of the joists.

LOFT PLAN




insideout


**PROJECT:**  
10 Thanet St. London WC1H 9QL  
**DRAWING NAME:**  
Proposed Loft Plan Services Schematic  
**NOTES:**  
Orientated to fit sheet size, 1:50@A3

© Copyright Once Printed and distributed this document is assumed uncontrolled.  
© All rights reserved. No part of this drawing may be reproduced or transmitted in any form by any means without the written permission of the copyright holder.


Purpose of Issue INFORMATION		
Drawn	-	Checked -
Date	27.06.23	
Scale	1:50	@A3
Project Number	Sheet Number	Rev
4033	DR-65-004	-

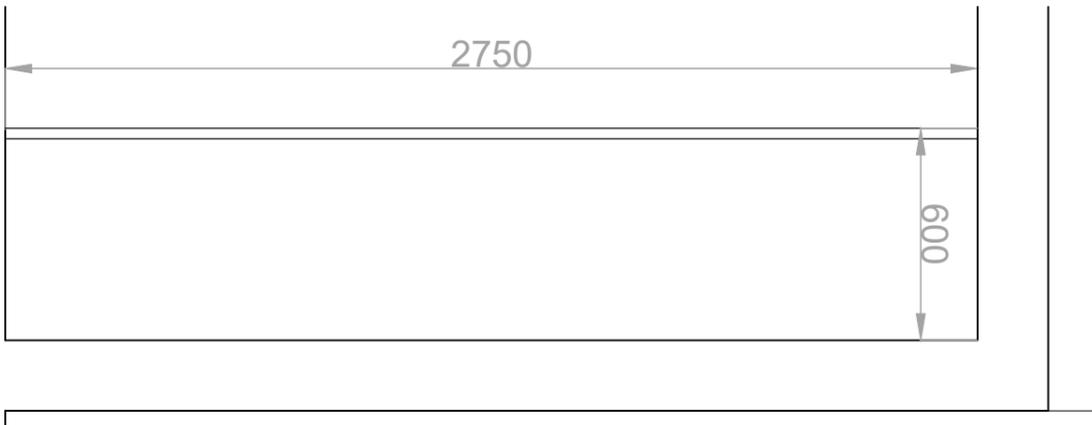

Lower Ground Bedroom 1 - Wardrobe Plan 1:20

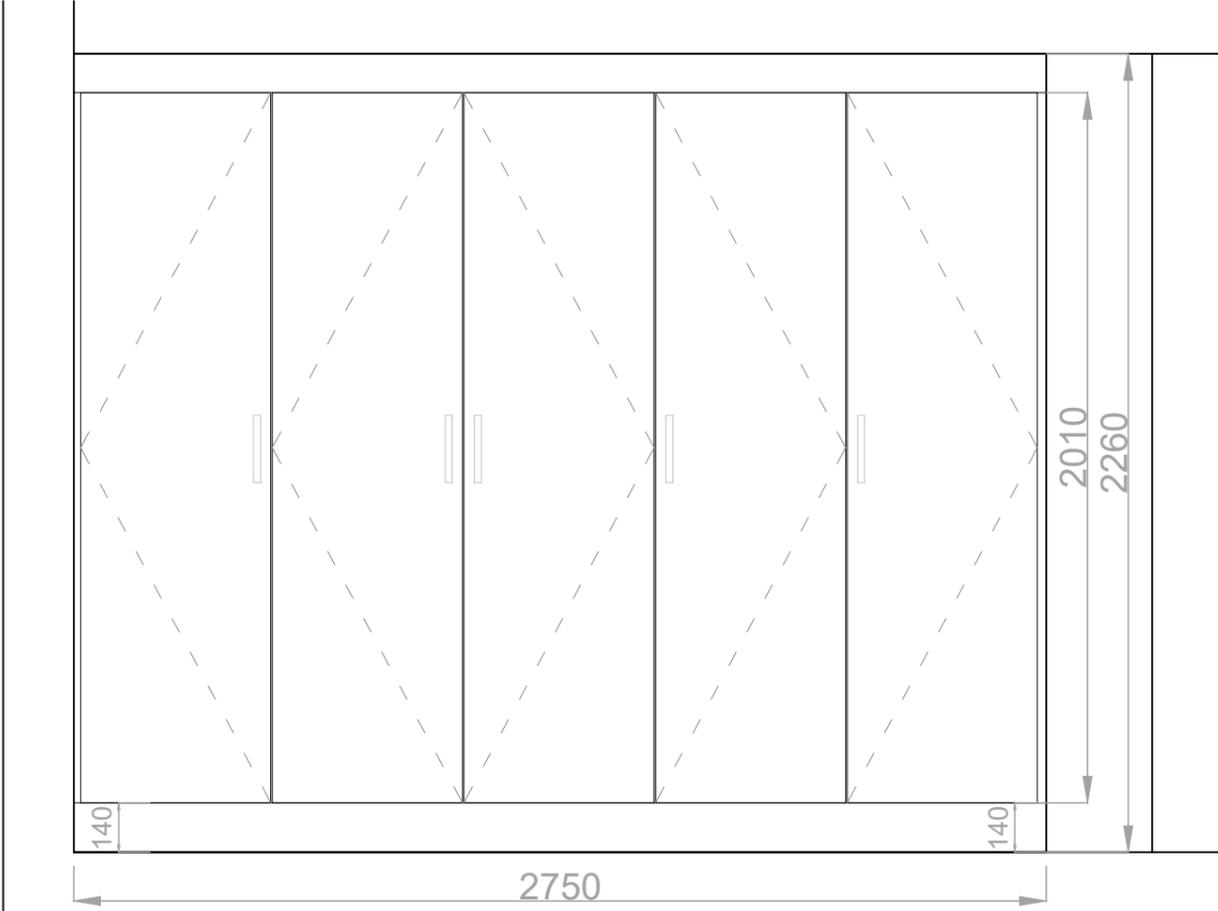

Lower Ground Bedroom 1 - Wardrobe Elevation 1:20

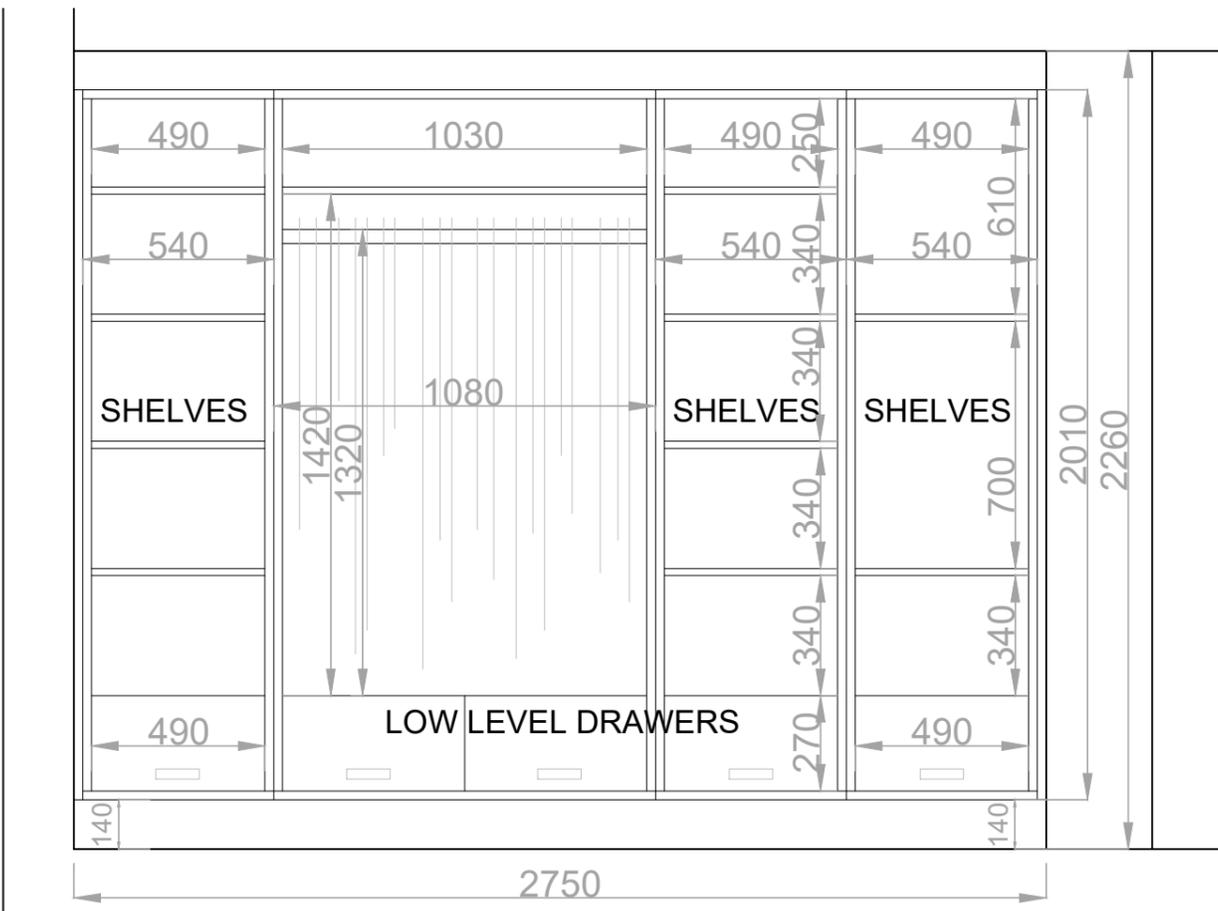


Lower Ground Bedroom 1 - Wardrobe (Open) Elevation 1:20




**PROJECT:**  
 10 Thanet St. London WC1H 9QL  
**DRAWING NAME:**  
 Lower Ground Bedroom 1 - Joinery - Wardrobe Plan & Elevations  
**NOTES:**  
 Orientated to fit sheet size, 1:20@A3  
 © Copyright Once Printed and distributed this document is assumed uncontrolled.  
 © All rights reserved. No part of this drawing may be reproduced or transmitted  
 in any form by any means without the written permission of the copyright holder.


Purpose of Issue			INFORMATION		
Drawn	-		Checked	-	
Date	27.06.23				
Scale	1:20		@A3		
Project Number	4033		Sheet Number	DR-72-001	Rev
					-

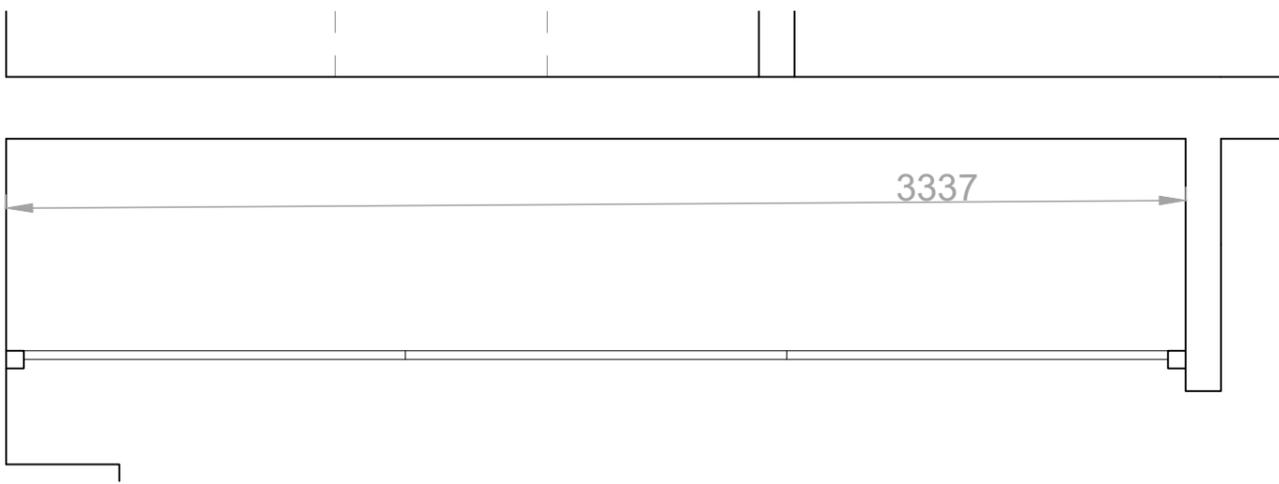

Lower Ground Bedroom 2 - Wardrobe Plan - 1:20

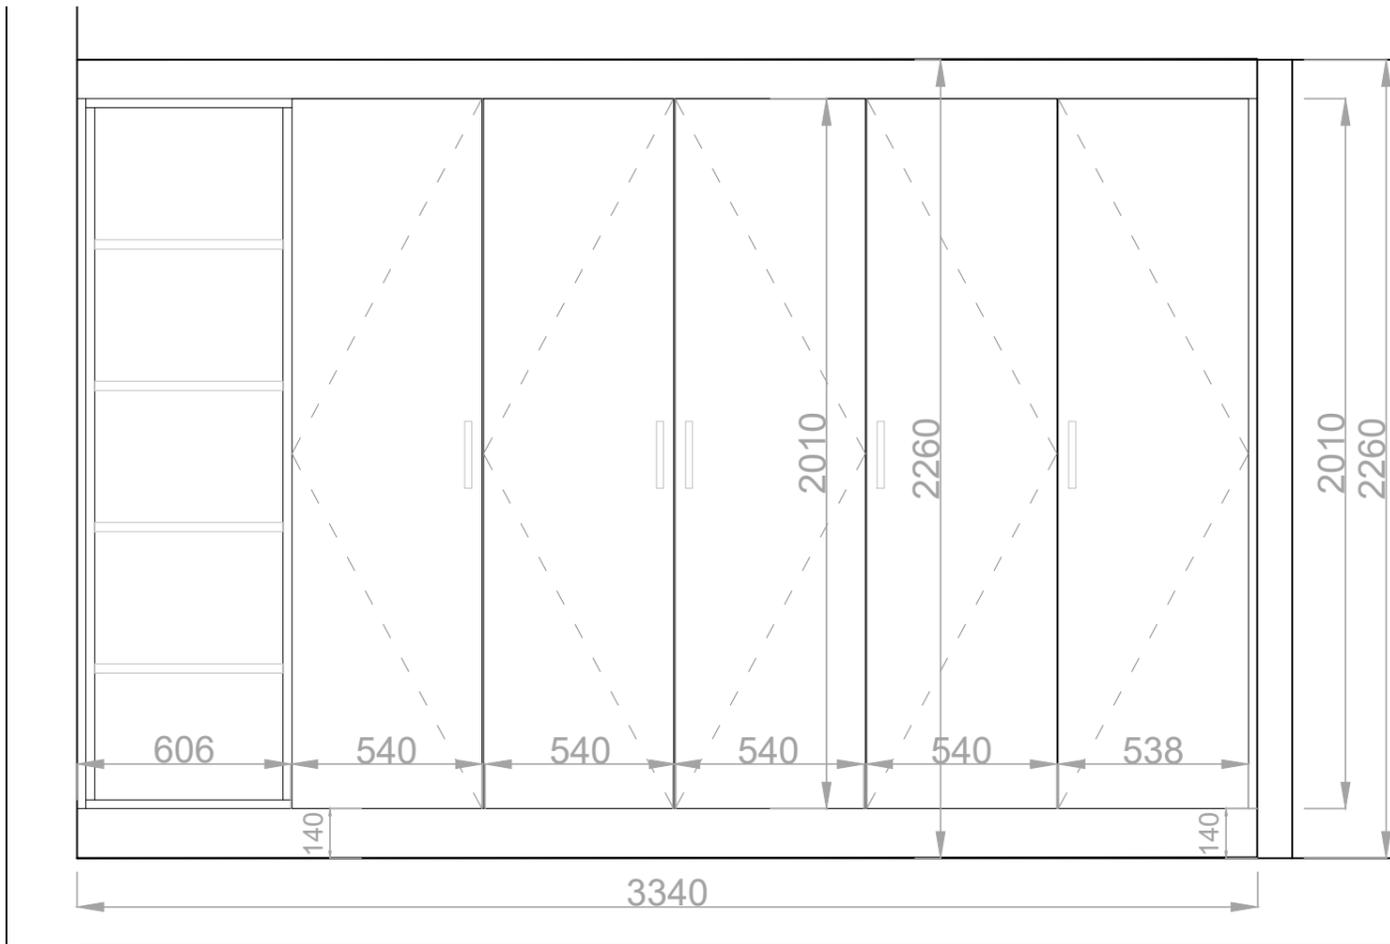

Lower Ground Bedroom 2 - Wardrobe Elevation - 1:20

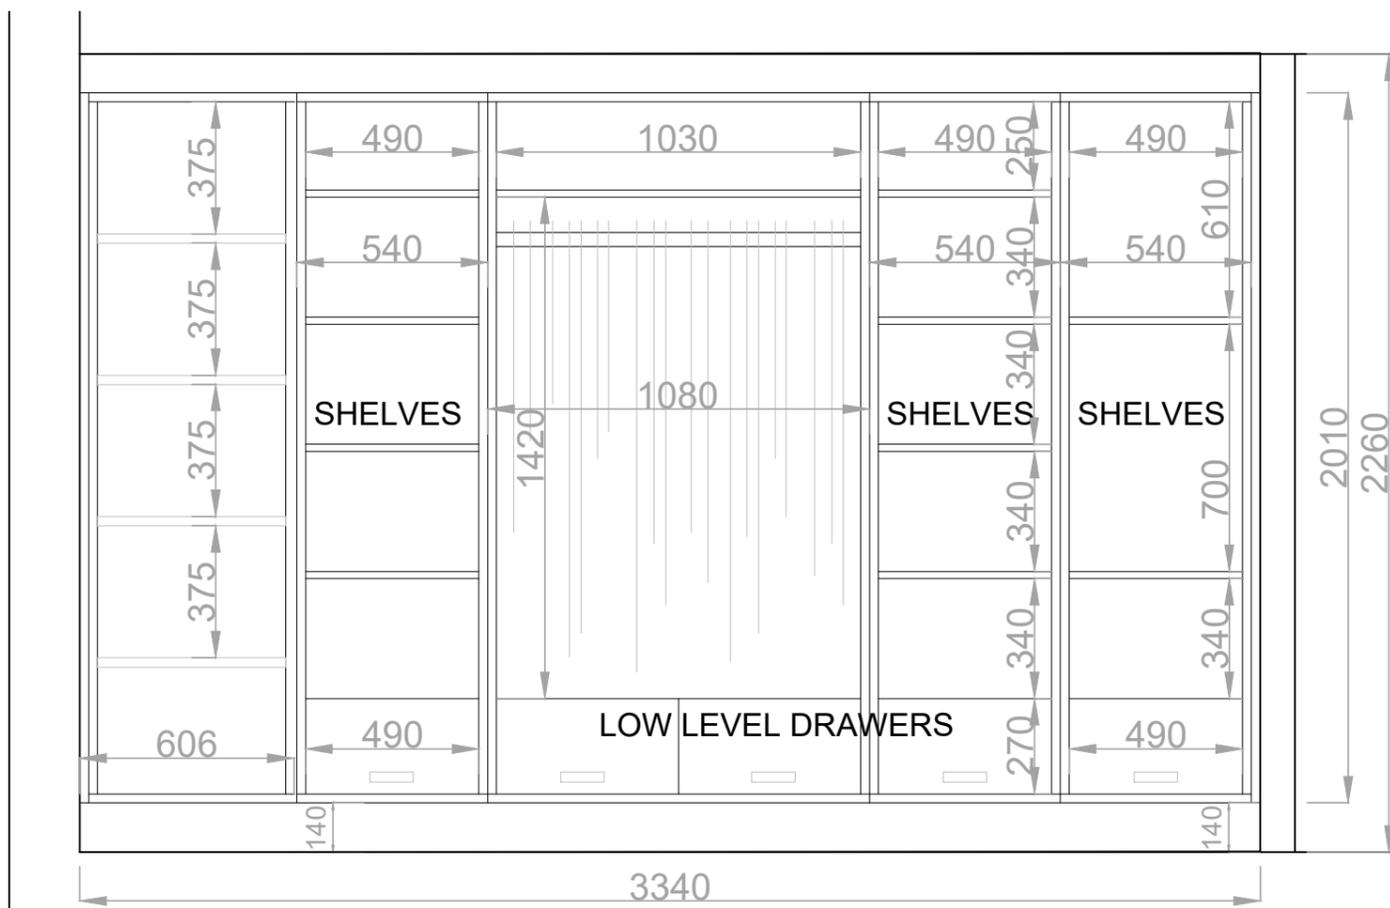


Lower Ground Bedroom 2 - Wardrobe Elevation - 1:20




**PROJECT:**  
 10 Thanet St. London WC1H 9QL  
**DRAWING NAME:**  
 Lower Ground Bedroom 2 - Joinery - Wardrobe Plan & Elevations  
**NOTES:**  
 Orientated to fit sheet size, 1:20@A3  
 © Copyright Once Printed and distributed this document is assumed uncontrolled.  
 © All rights reserved. No part of this drawing may be reproduced or transmitted  
 in any form by any means without the written permission of the copyright holder.

Purpose of Issue			INFORMATION		
Drawn	-		Checked	-	
Date	27.06.23				
Scale	1:20			@A3	
Project Number	4033		Sheet Number	DR-72-002	Rev
					-

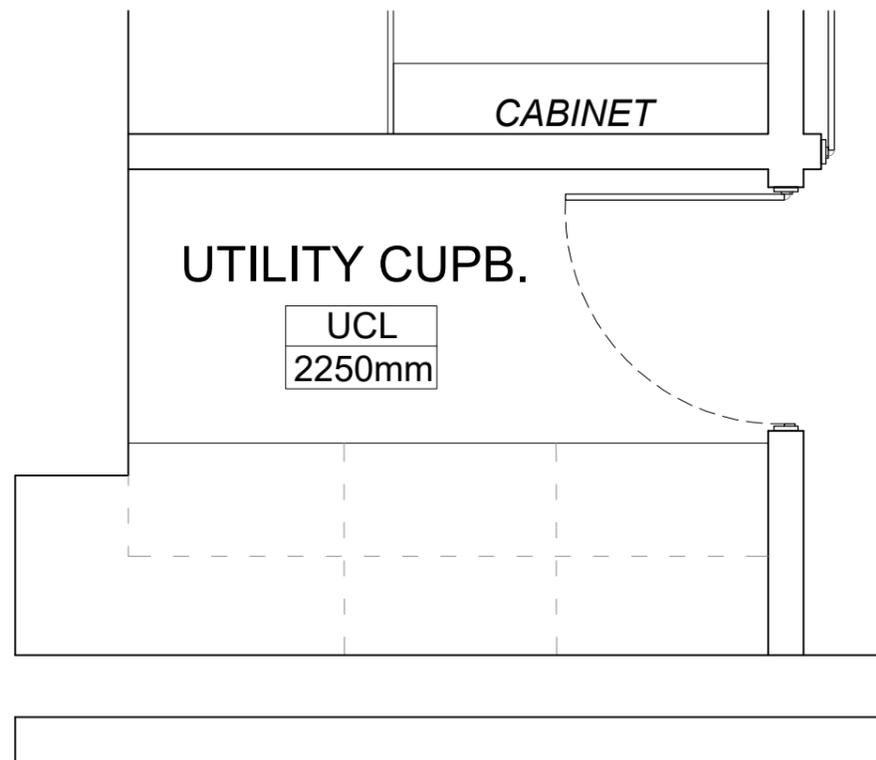

Utility Room Floor Plan 1:20

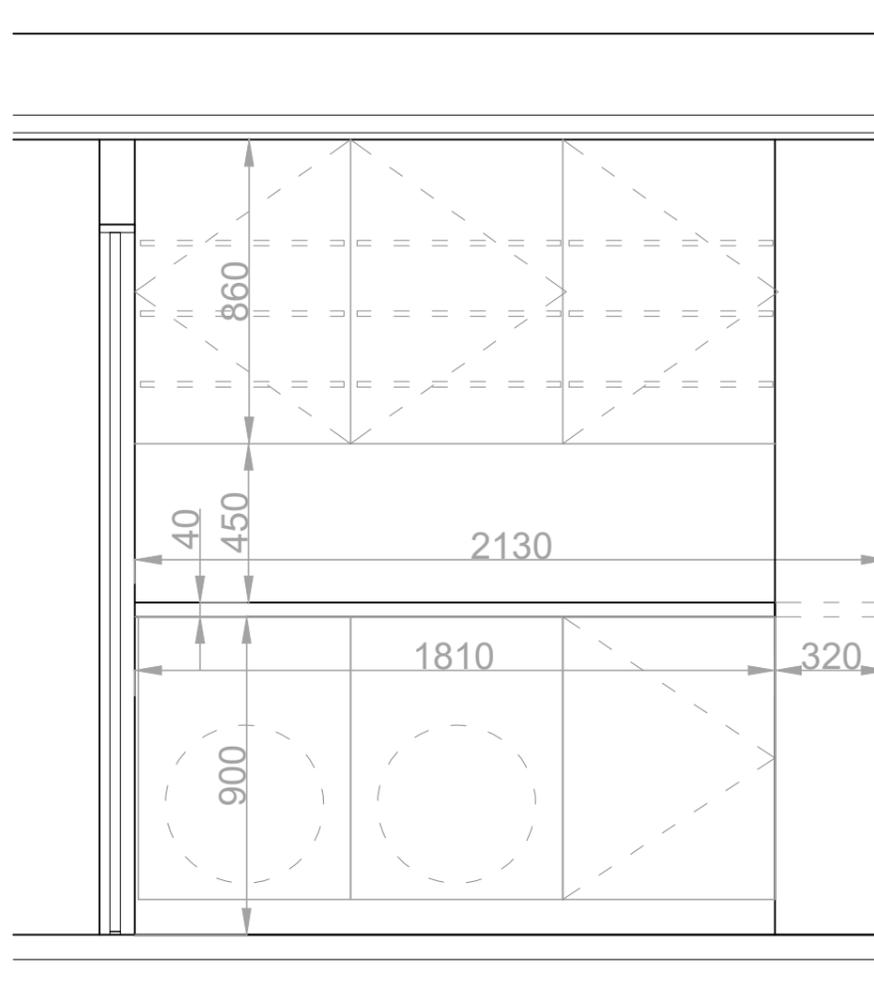

Utility Room Elevation 1:20



**PROJECT:**  
 10 Thanet St. London WC1H 9QL  
**DRAWING NAME:**  
 Utility Room Joinery - Lower Ground  
**NOTES:**  
 Orientated to fit sheet size, 1:20@A3  
 © Copyright Once Printed and distributed this document is assumed uncontrolled.  
 © All rights reserved. No part of this drawing may be reproduced or transmitted  
 in any form by any means without the written permission of the copyright holder.

Purpose of Issue			INFORMATION		
Drawn	-		Checked	-	
Date	27.06.23				
Scale	1:20		@A3		
Project Number	4033		Sheet Number	DR-72-003	Rev
					-