


DATUM=17.00m ELEVATION 2D DATUM=17.00m ELEVATION 9

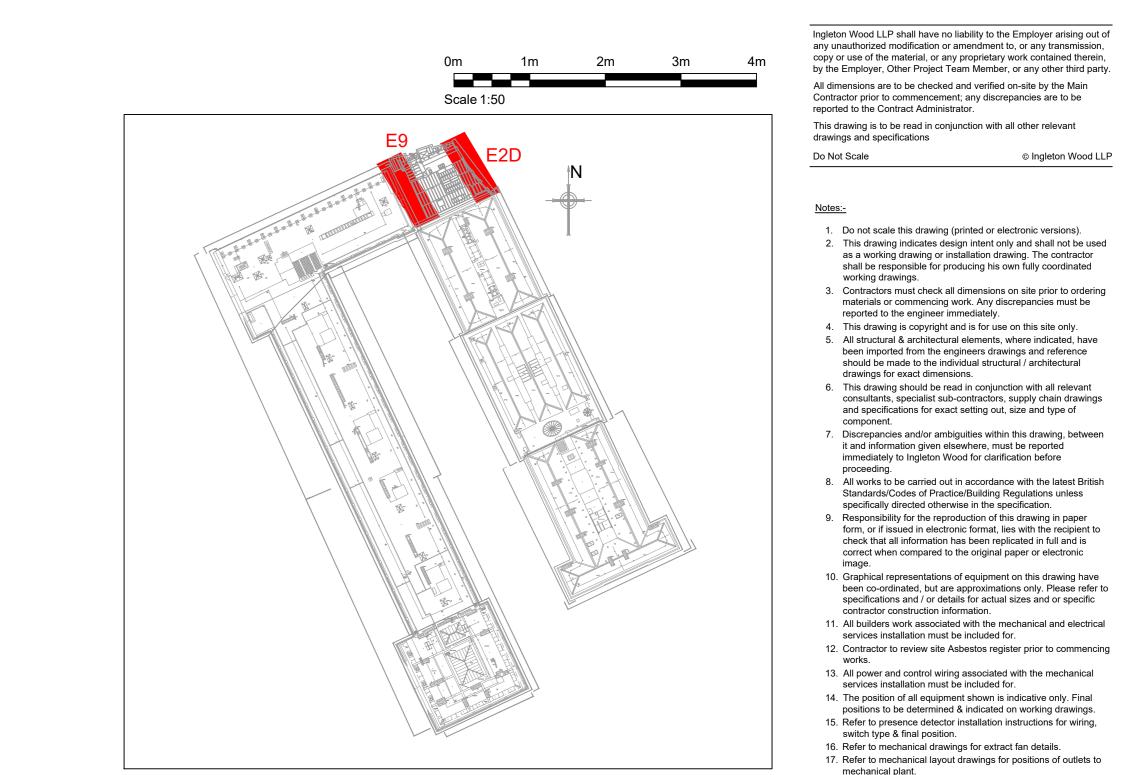

KEY PLAN SCALE: NTS



 
 P02
 Scale Bar Added

 P01
 Information Issue

 Rev
 Description

 Project No:
 Scale @ A0:

 502705
 1:50
 Ingleton Wood Vision, form and function

© Ingleton Wood LLP

as a working drawing or installation drawing. The contractor shall be responsible for producing his own fully coordinated

materials or commencing work. Any discrepancies must be

been imported from the engineers drawings and reference should be made to the individual structural / architectural

and specifications for exact setting out, size and type of

working drawings.

reported to the engineer immediately.

drawings for exact dimensions.

services installation must be included for.

switch type & final position.

mechanical plant.

suit the installation.

positions to be determined & indicated on working drawings.

18. Cable containment (if indicated) is shown as indicative only. Contractor to determine cable containment routes and sizes to

HSLI Stone Building
Lightning Protection System
Stone Buildings
London WC2A 3TL

Honourable Society of Lincoln's Inn

Lightning Protection
Elevation 2D & E9 Drawing Number:

HSLISB-IWD-XX-XX-DR-E-5813

Status: | Purpose of Issue: | Revision: | P02