


The London Tunnels

7. Application Drawings (Furnival Street Elevations)


30 November 2023


WilkinsonEyre

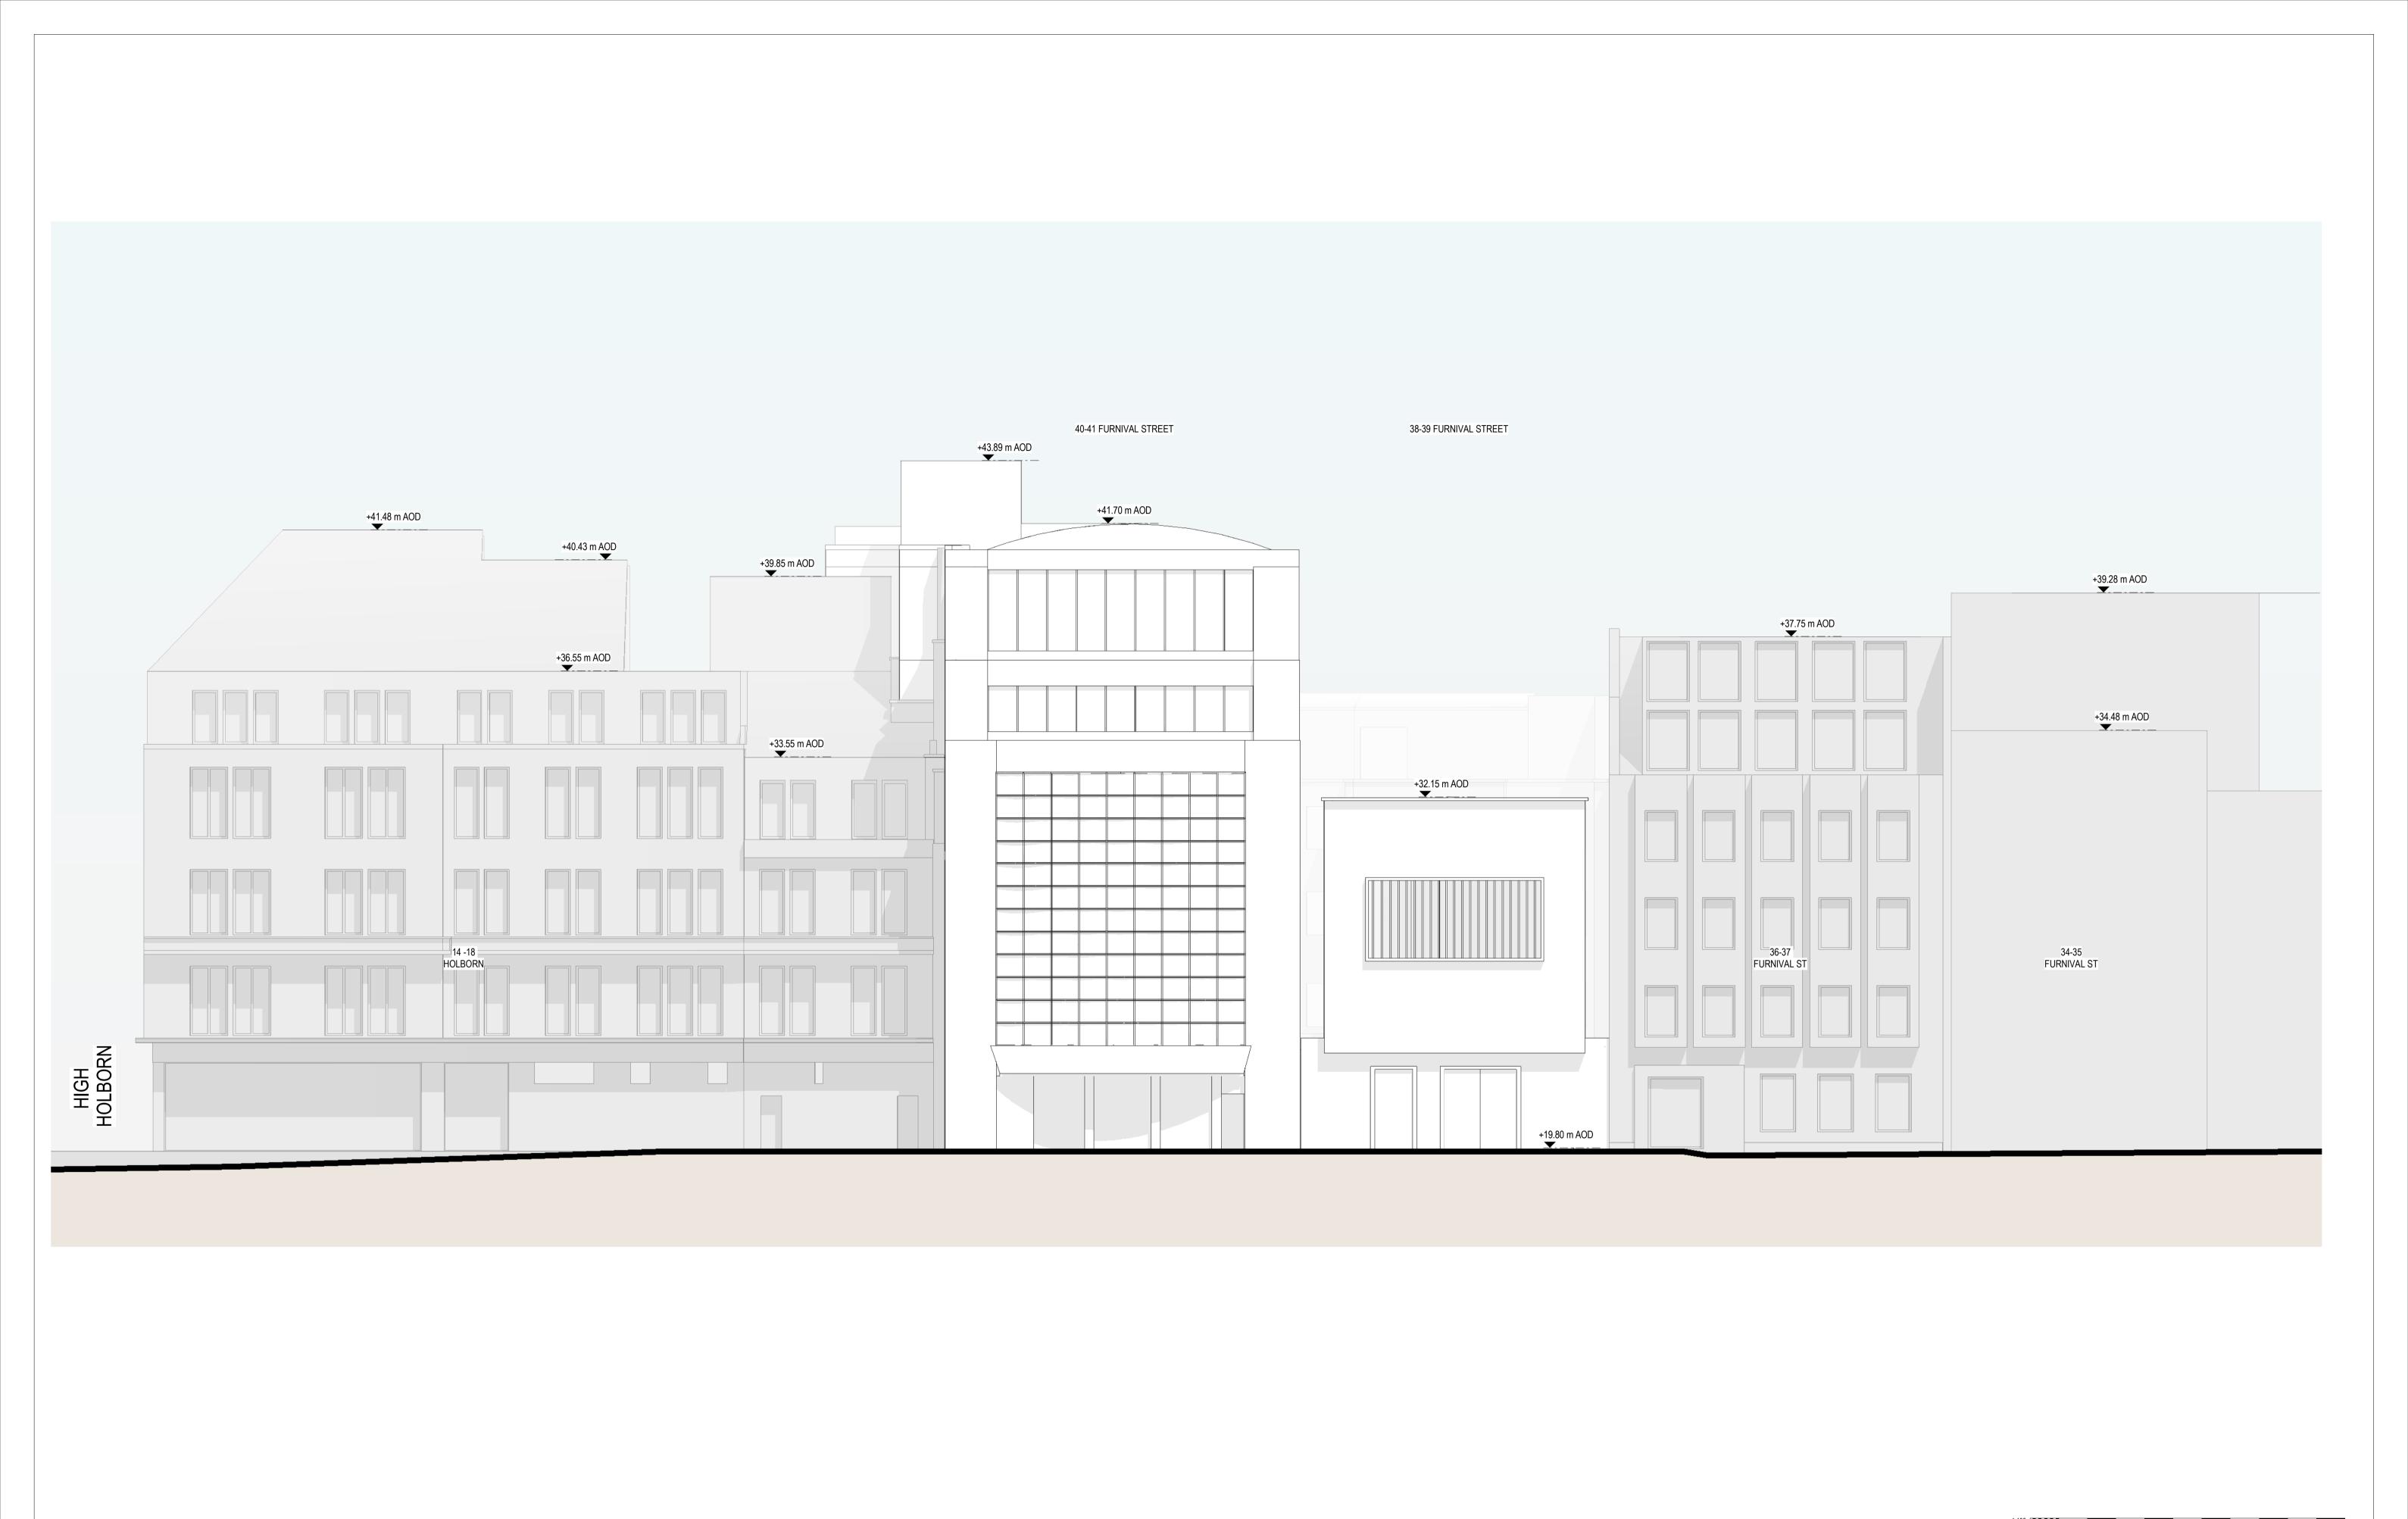



FOR PLANNING Project
THE LONDON TUNNELS THE LONDON LONDON Do not scale. Use figured dimensions only. All dimensions to be checked on site All drawings to be read in conjunction with the engineers' drawings. WilkinsonEyre FOR PLANNING TUNNELS PLC FURNIVAL STREET - OVERALL EXISTING WEST ELEVATION Any discrepancies between consultants drawings to be reported to the architect before any work commences.

The contractor's attention is drawn to the Health & Safety matters identified in the Health & Safety plan as being potentially hazardous. These items should not be considered as a complete and final list. Wilkinson Eyre Architects 33 Bowling Green Lane, London EC1R 0BJ, United Kingdom +44 (0) 20 7608 7900 T +44 (0) 20 7608 7901 F www.wilkinsoneyre.com TUNNELS The work package contractor's normal Health & Safety obligations still apply when undertaking constructional operations both on and off site. Drawing and CAD File Number 01820 - WEA - 01 - W - PD - A - 2050 Rev 00 Drawn By Checked By HC Description

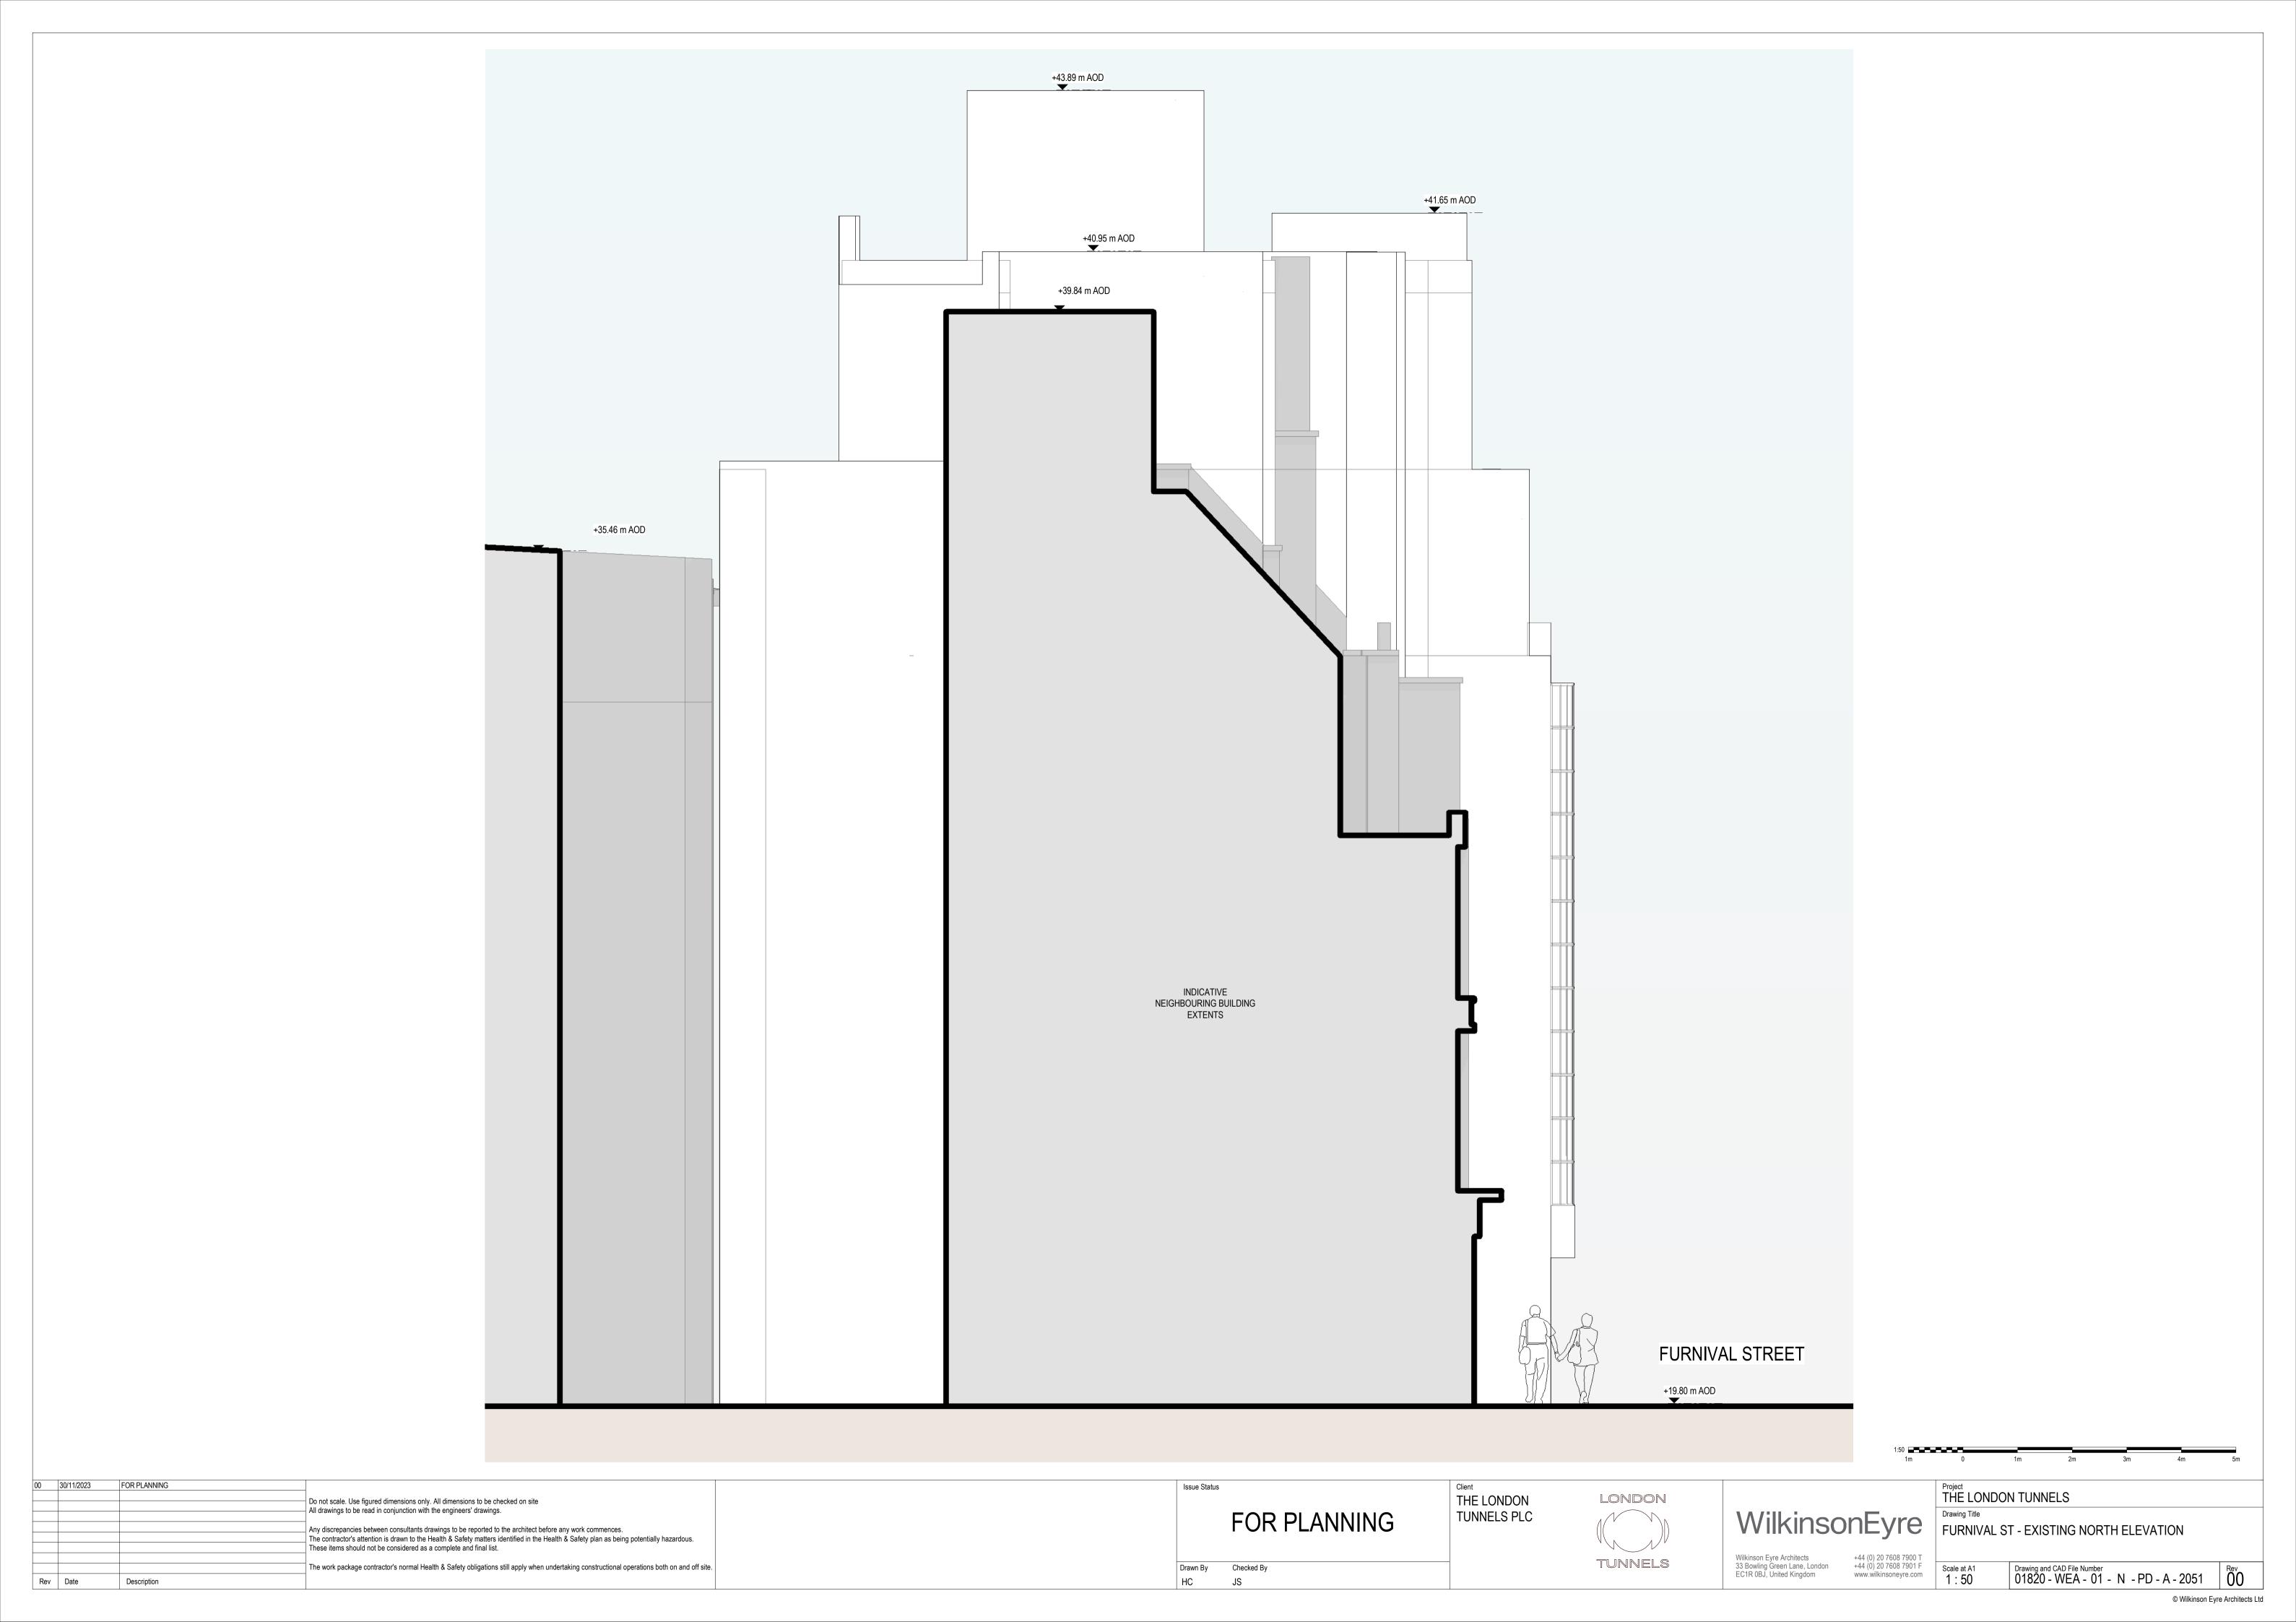

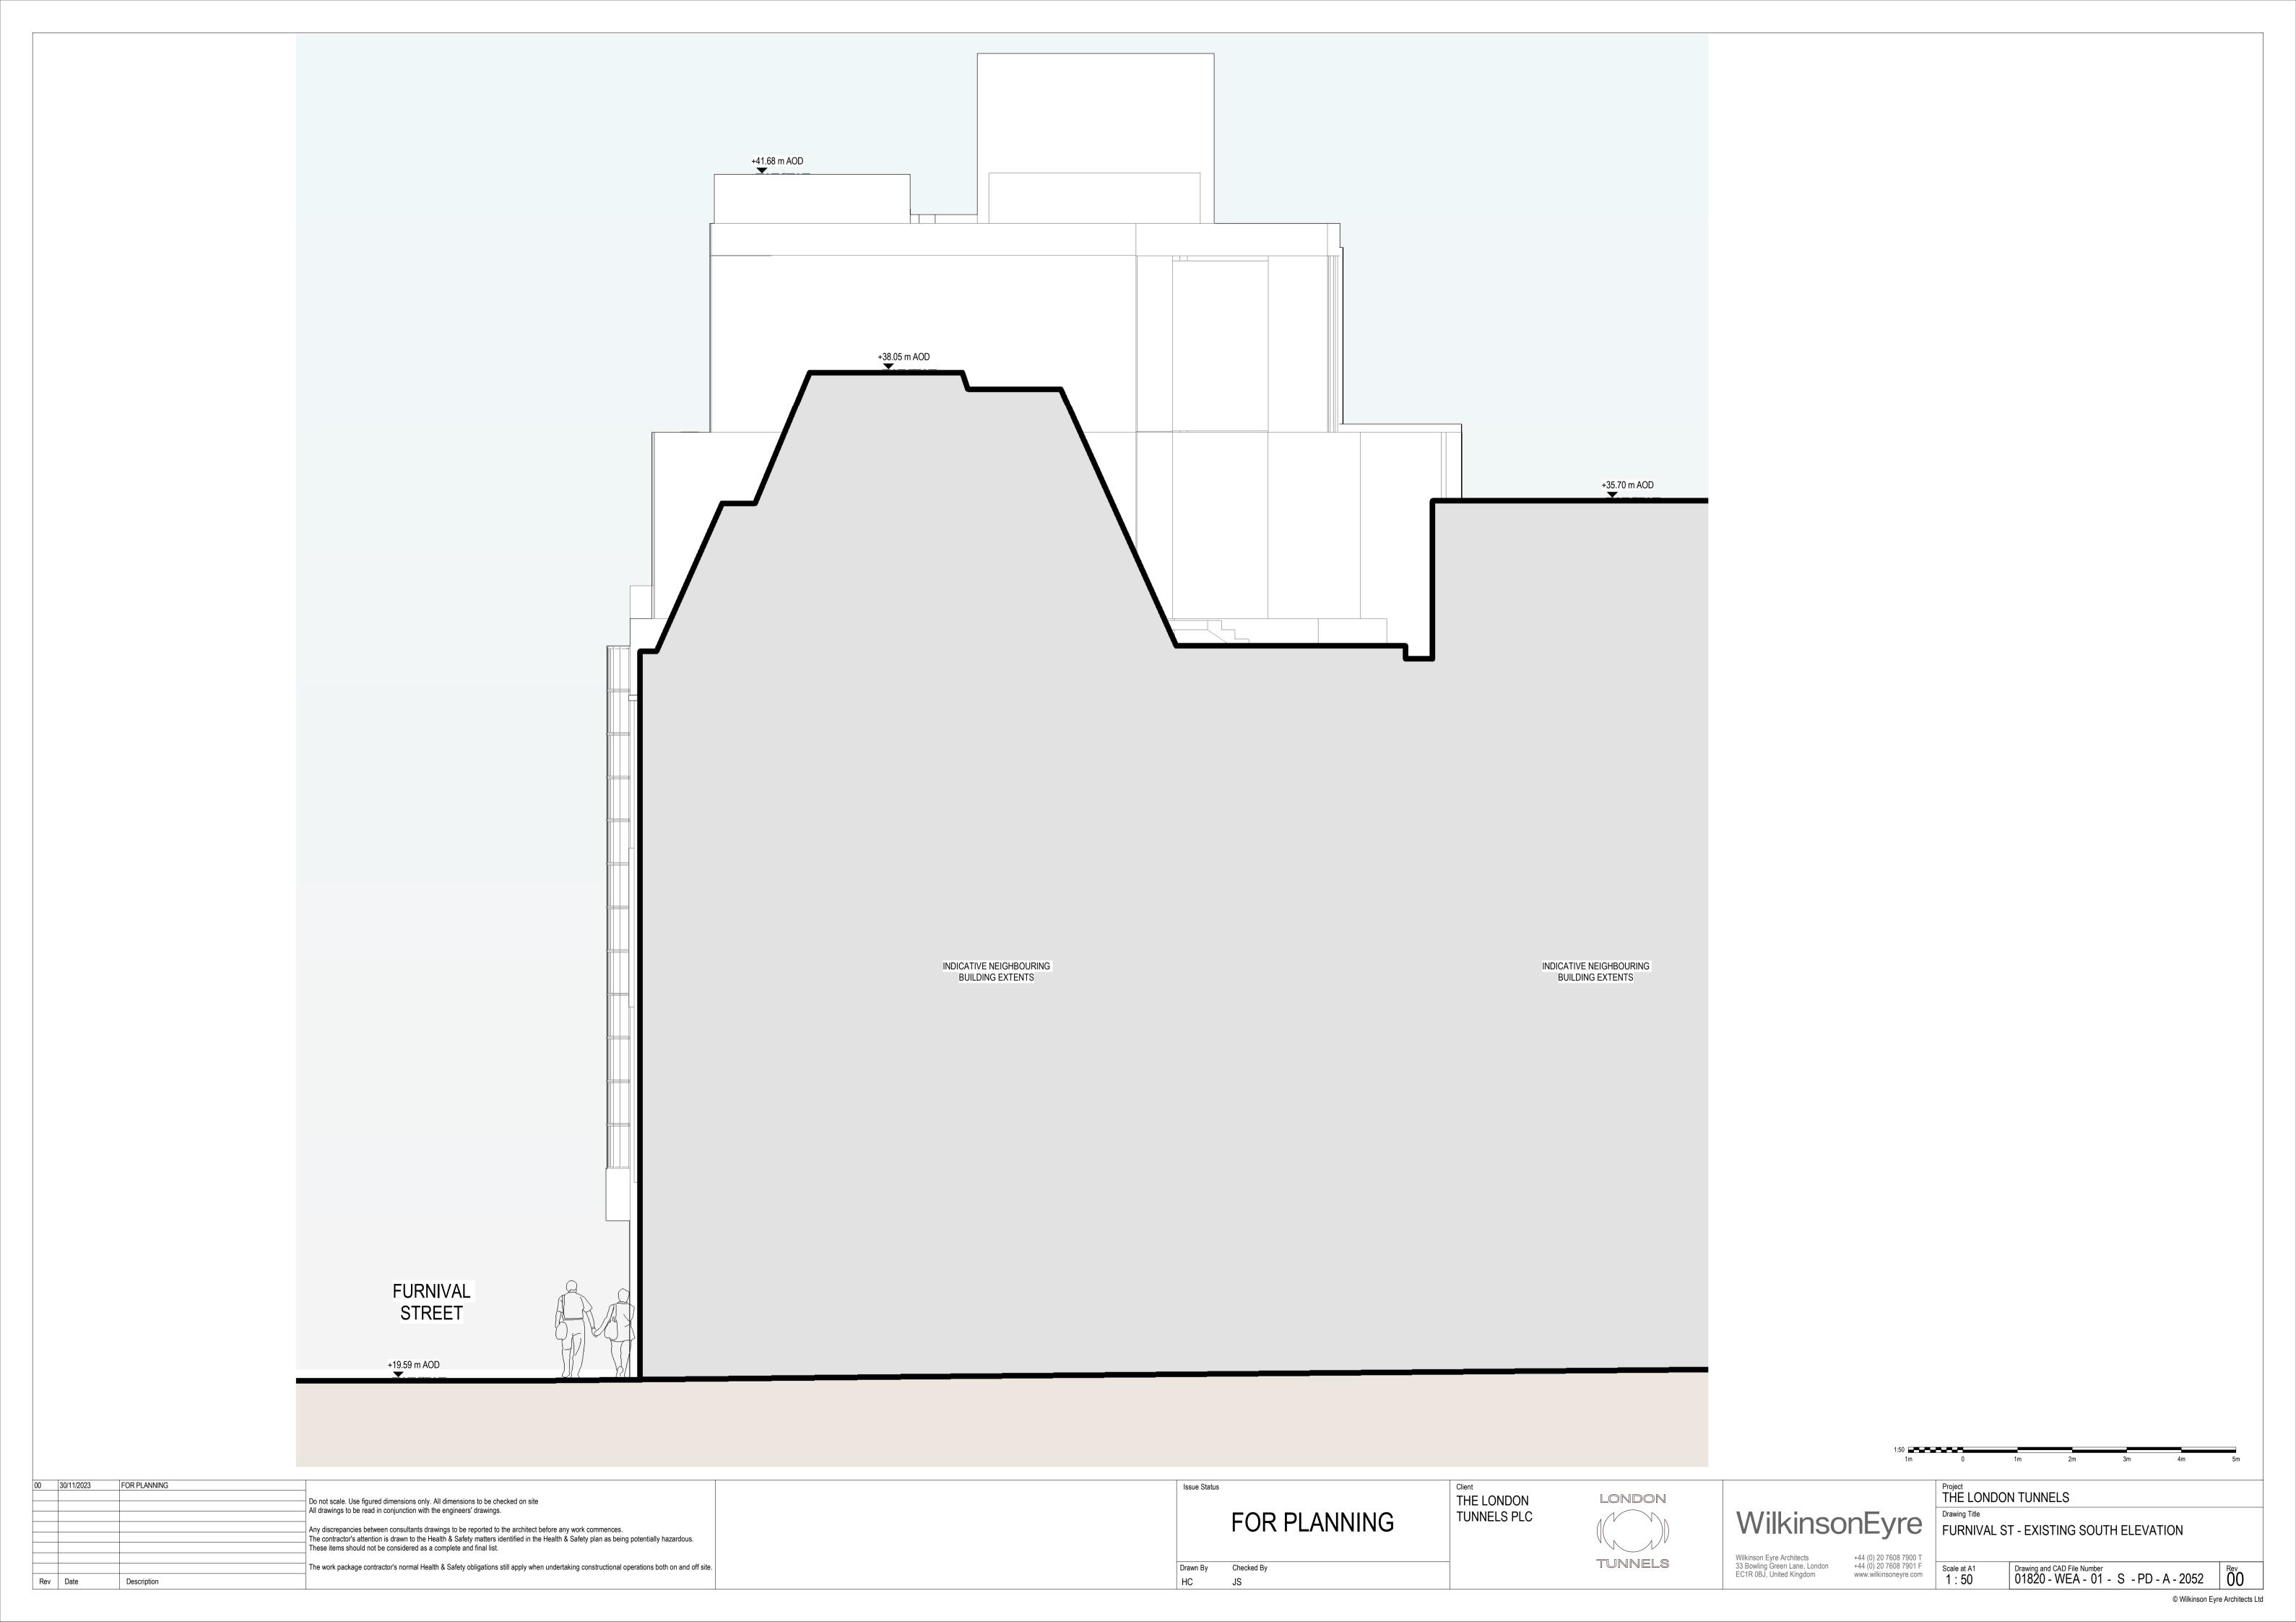

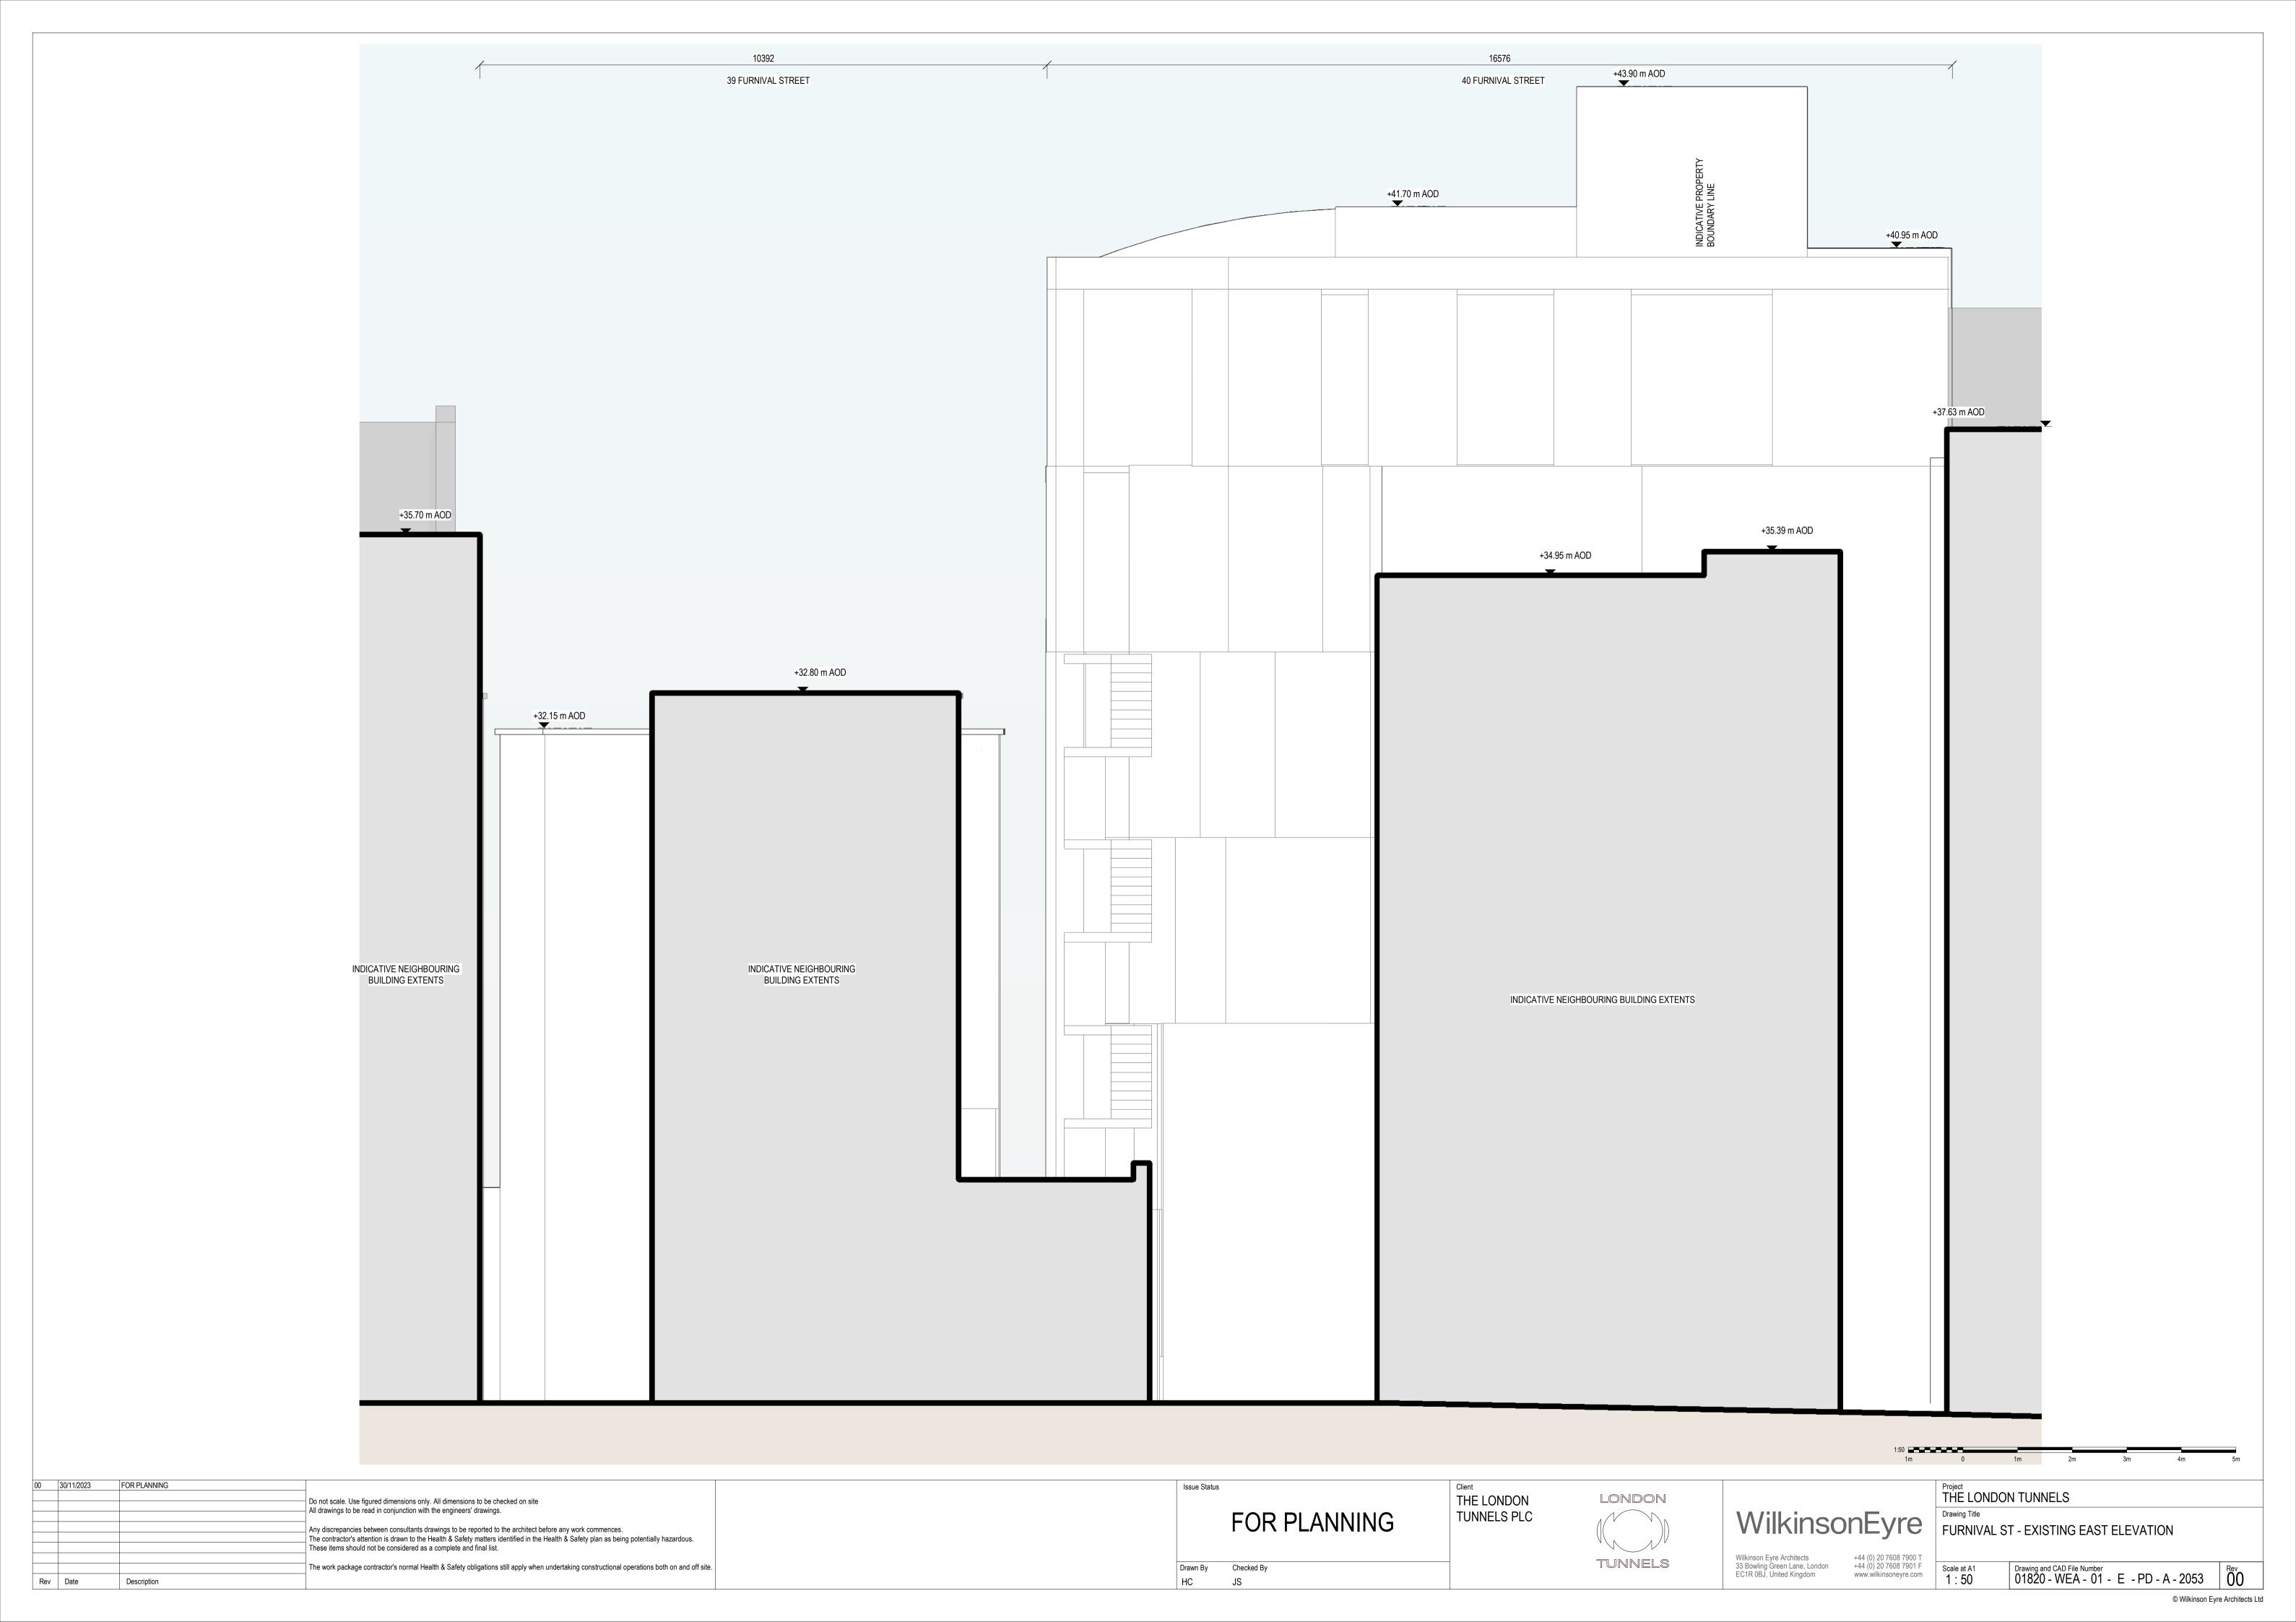

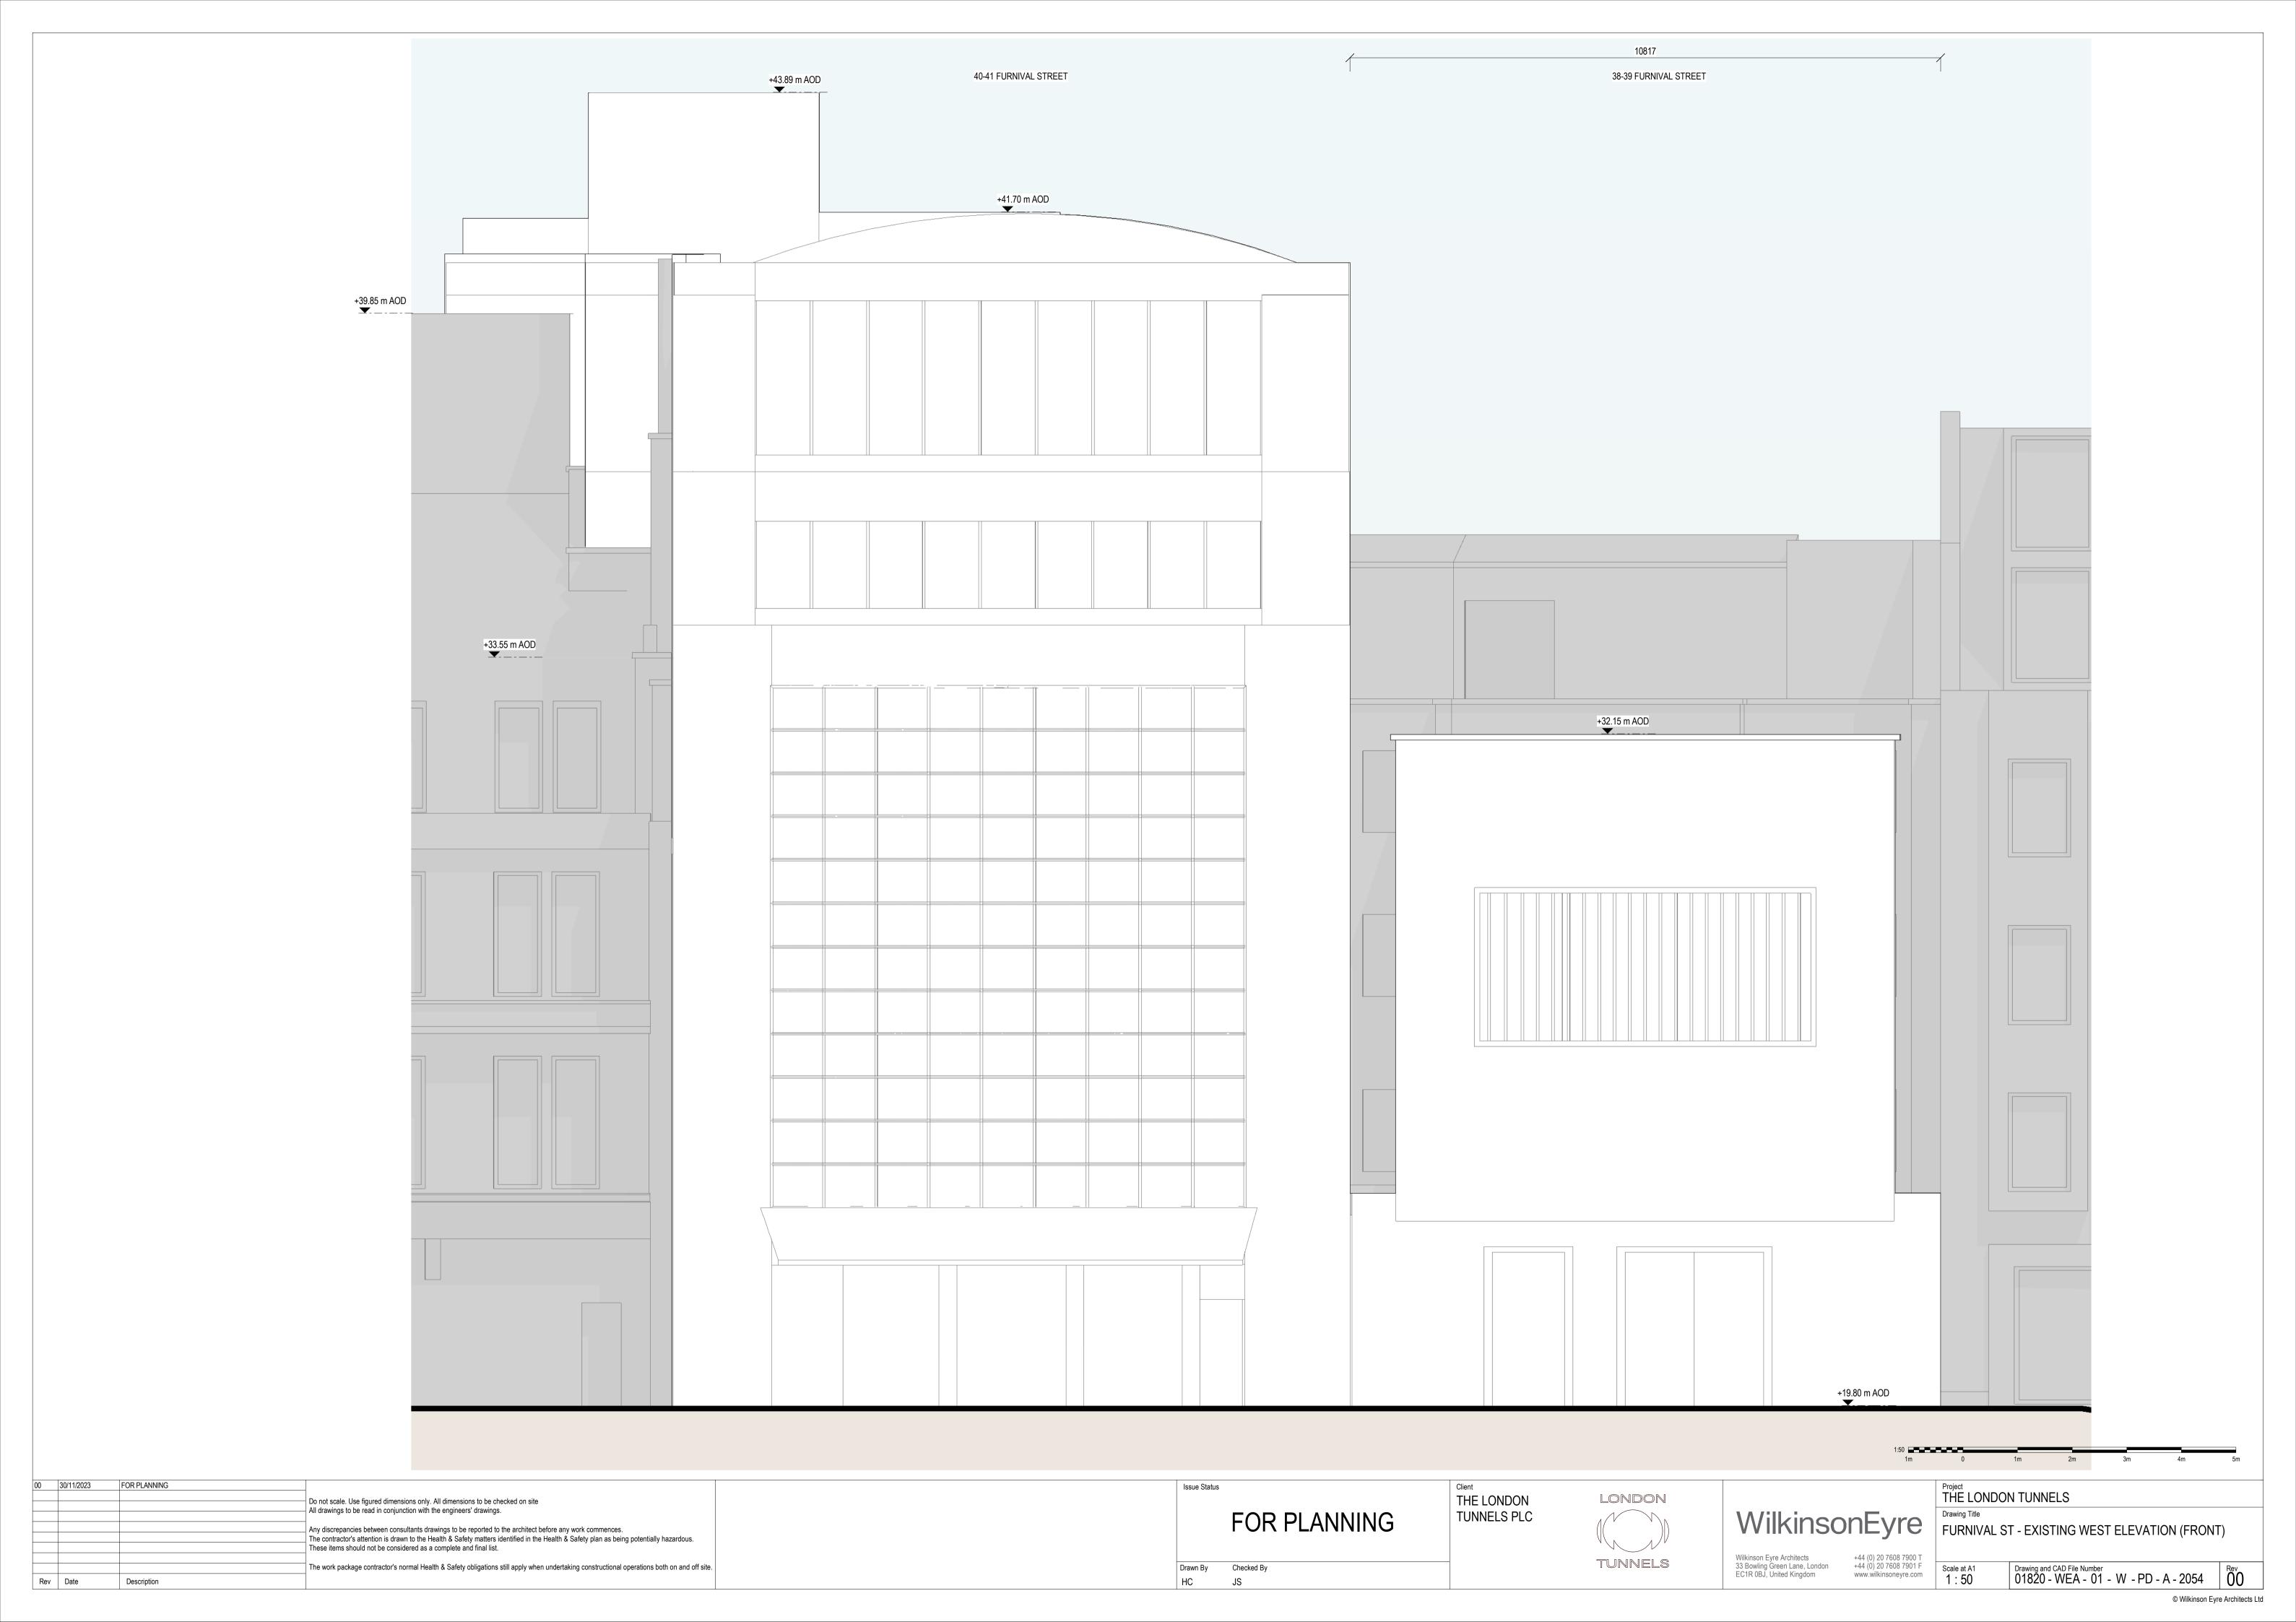



FOR PLANNING 30/11/2023 PLANNING ADDENDUM 18/04/2024 Do not scale. Use figured dimensions only. All dimensions to be checked on site All drawings to be read in conjunction with the engineers' drawings. Any discrepancies between consultants drawings to be reported to the architect before any work commences. The contractor's attention is drawn to the Health & Safety matters identified in the Health & Safety plan as being potentially hazardous. These items should not be considered as a complete and final list. The work package contractor's normal Health & Safety obligations still apply when undertaking constructional operations both on and off site. Description

THE LONDON PLANNING ADDENDUM Checked By

HC

LONDON TUNNELS


TUNNELS PLC


WilkinsonEyre 33 Bowling Green Lane, London EC1R 0BJ, United Kingdom


+44 (0) 20 7608 7901 F


www.wilkinsoneyre.com

Project THE LONDON TUNNELS FURNIVAL ST - OVERALL PROPOSED WEST ELEVATION Drawing and CAD File Number 01820 - WEA - 01 - W - PD - A - 2100 01

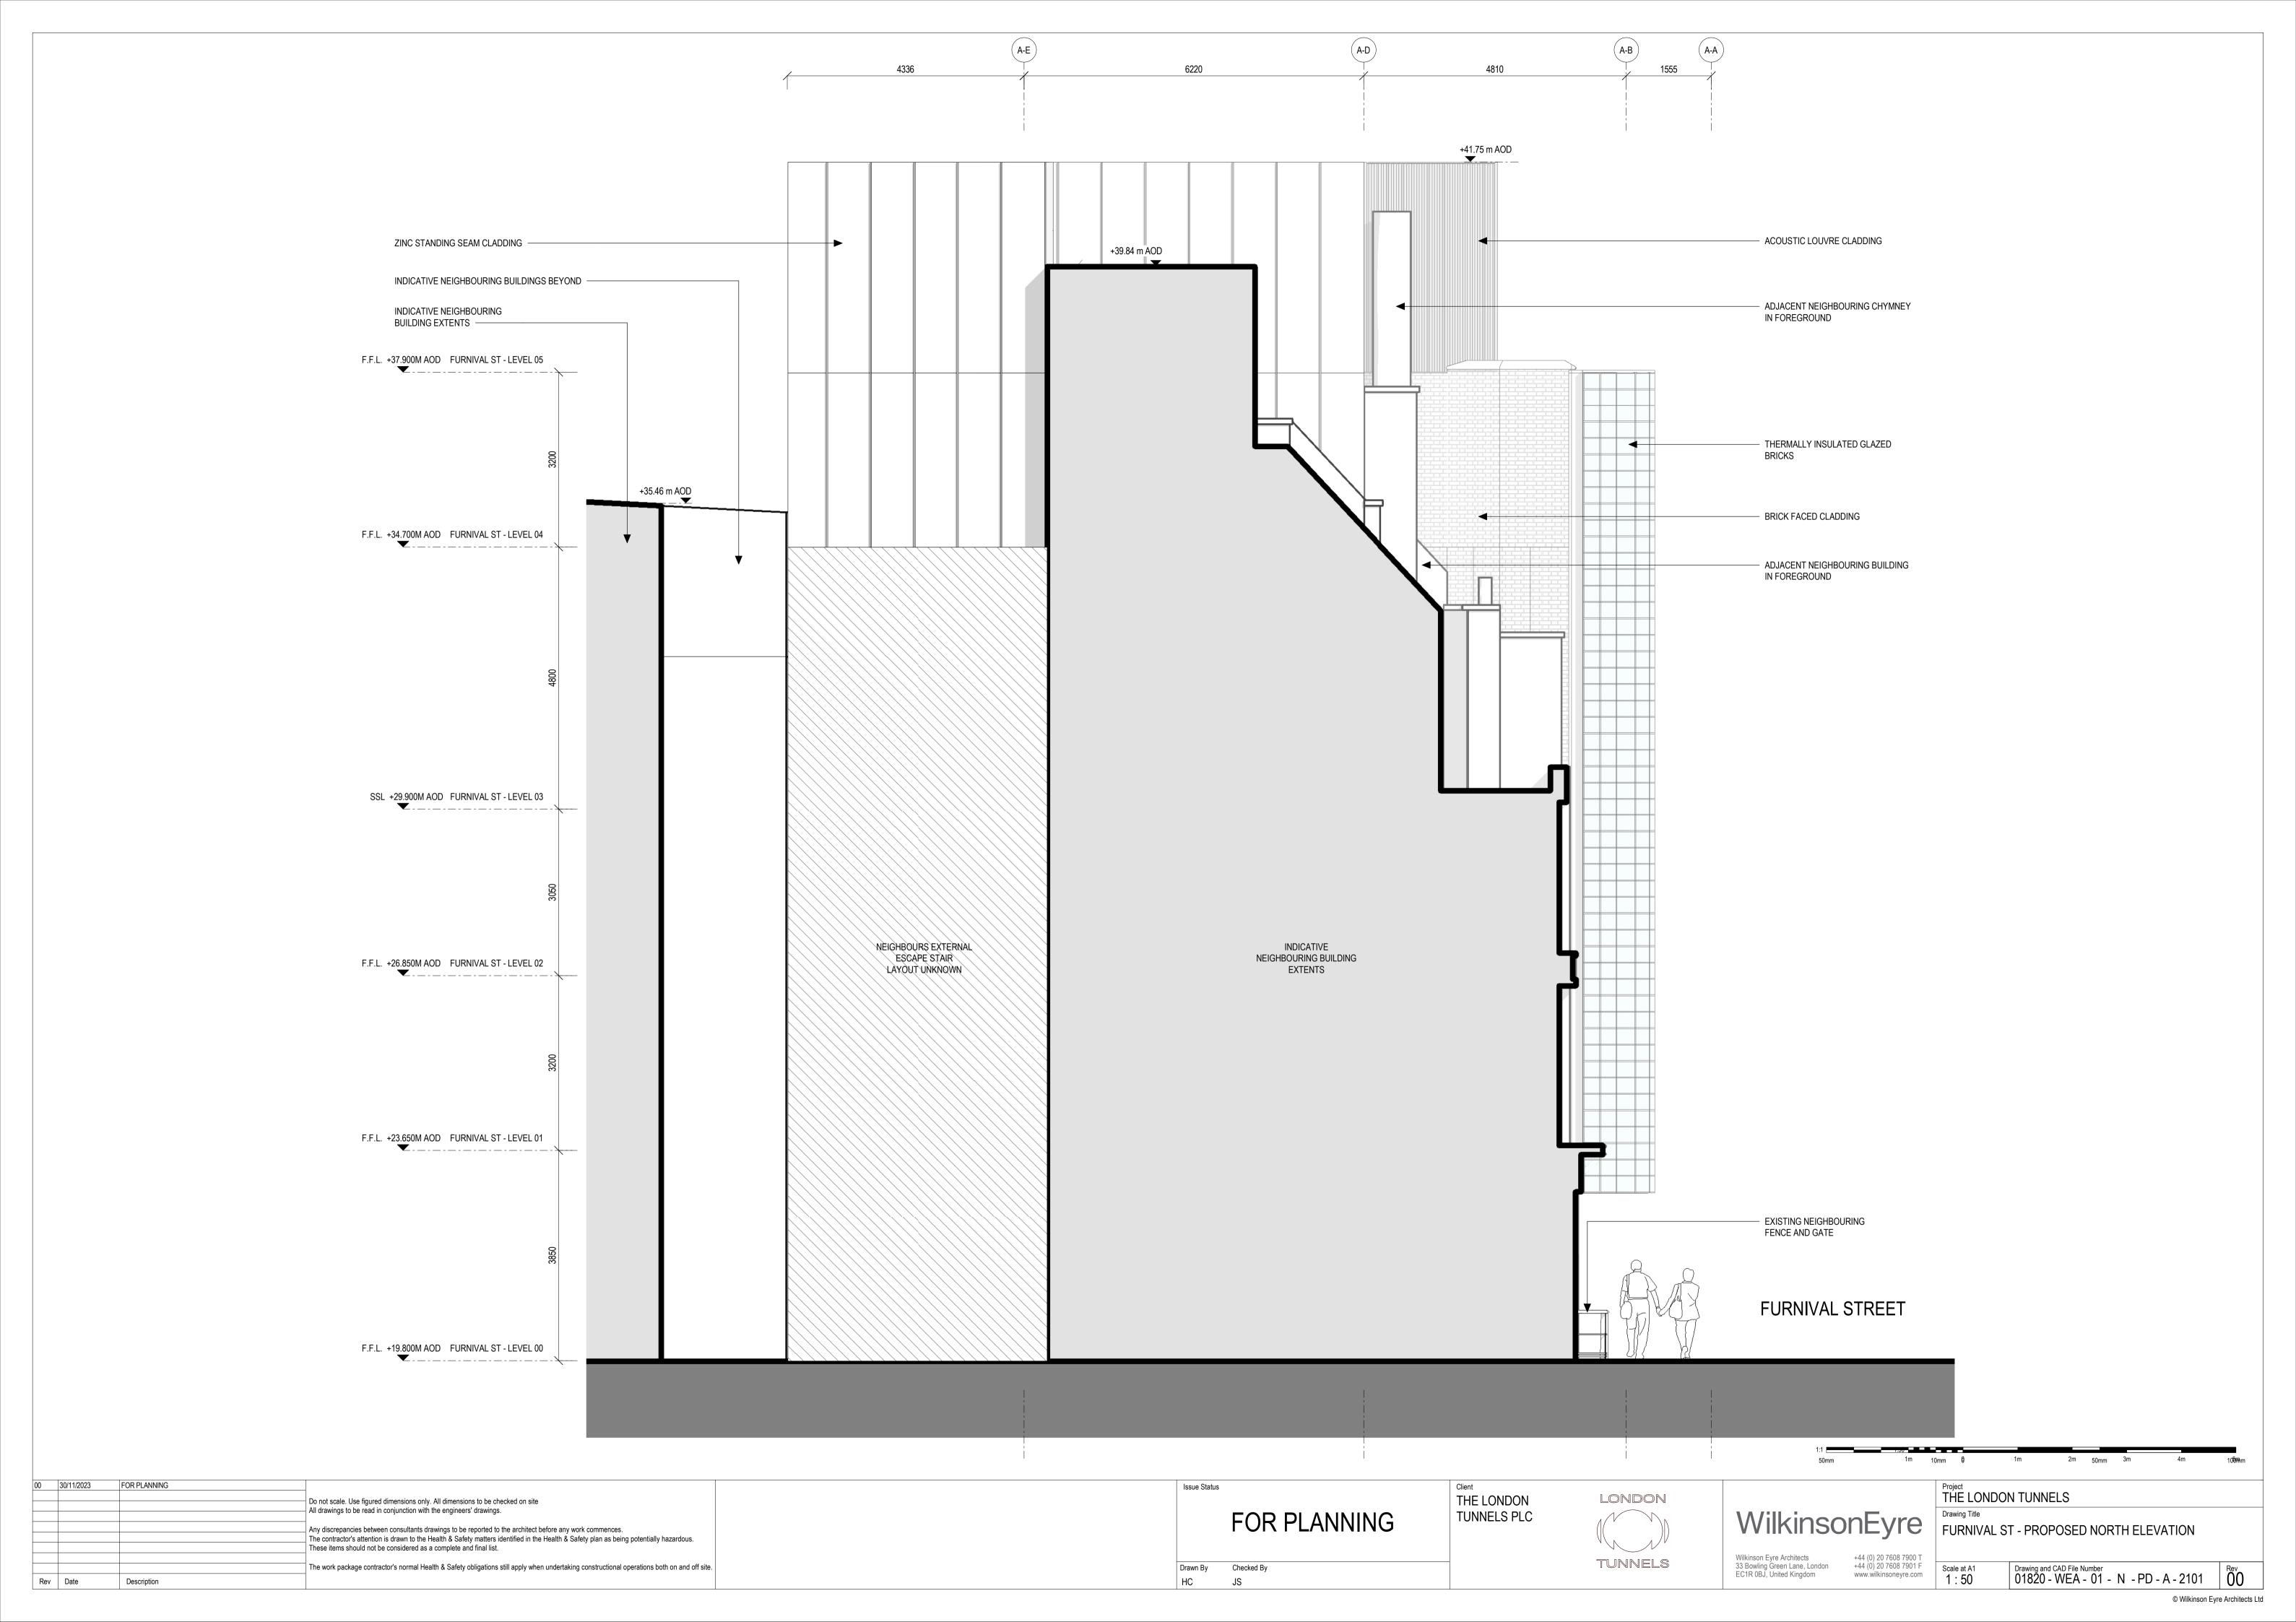

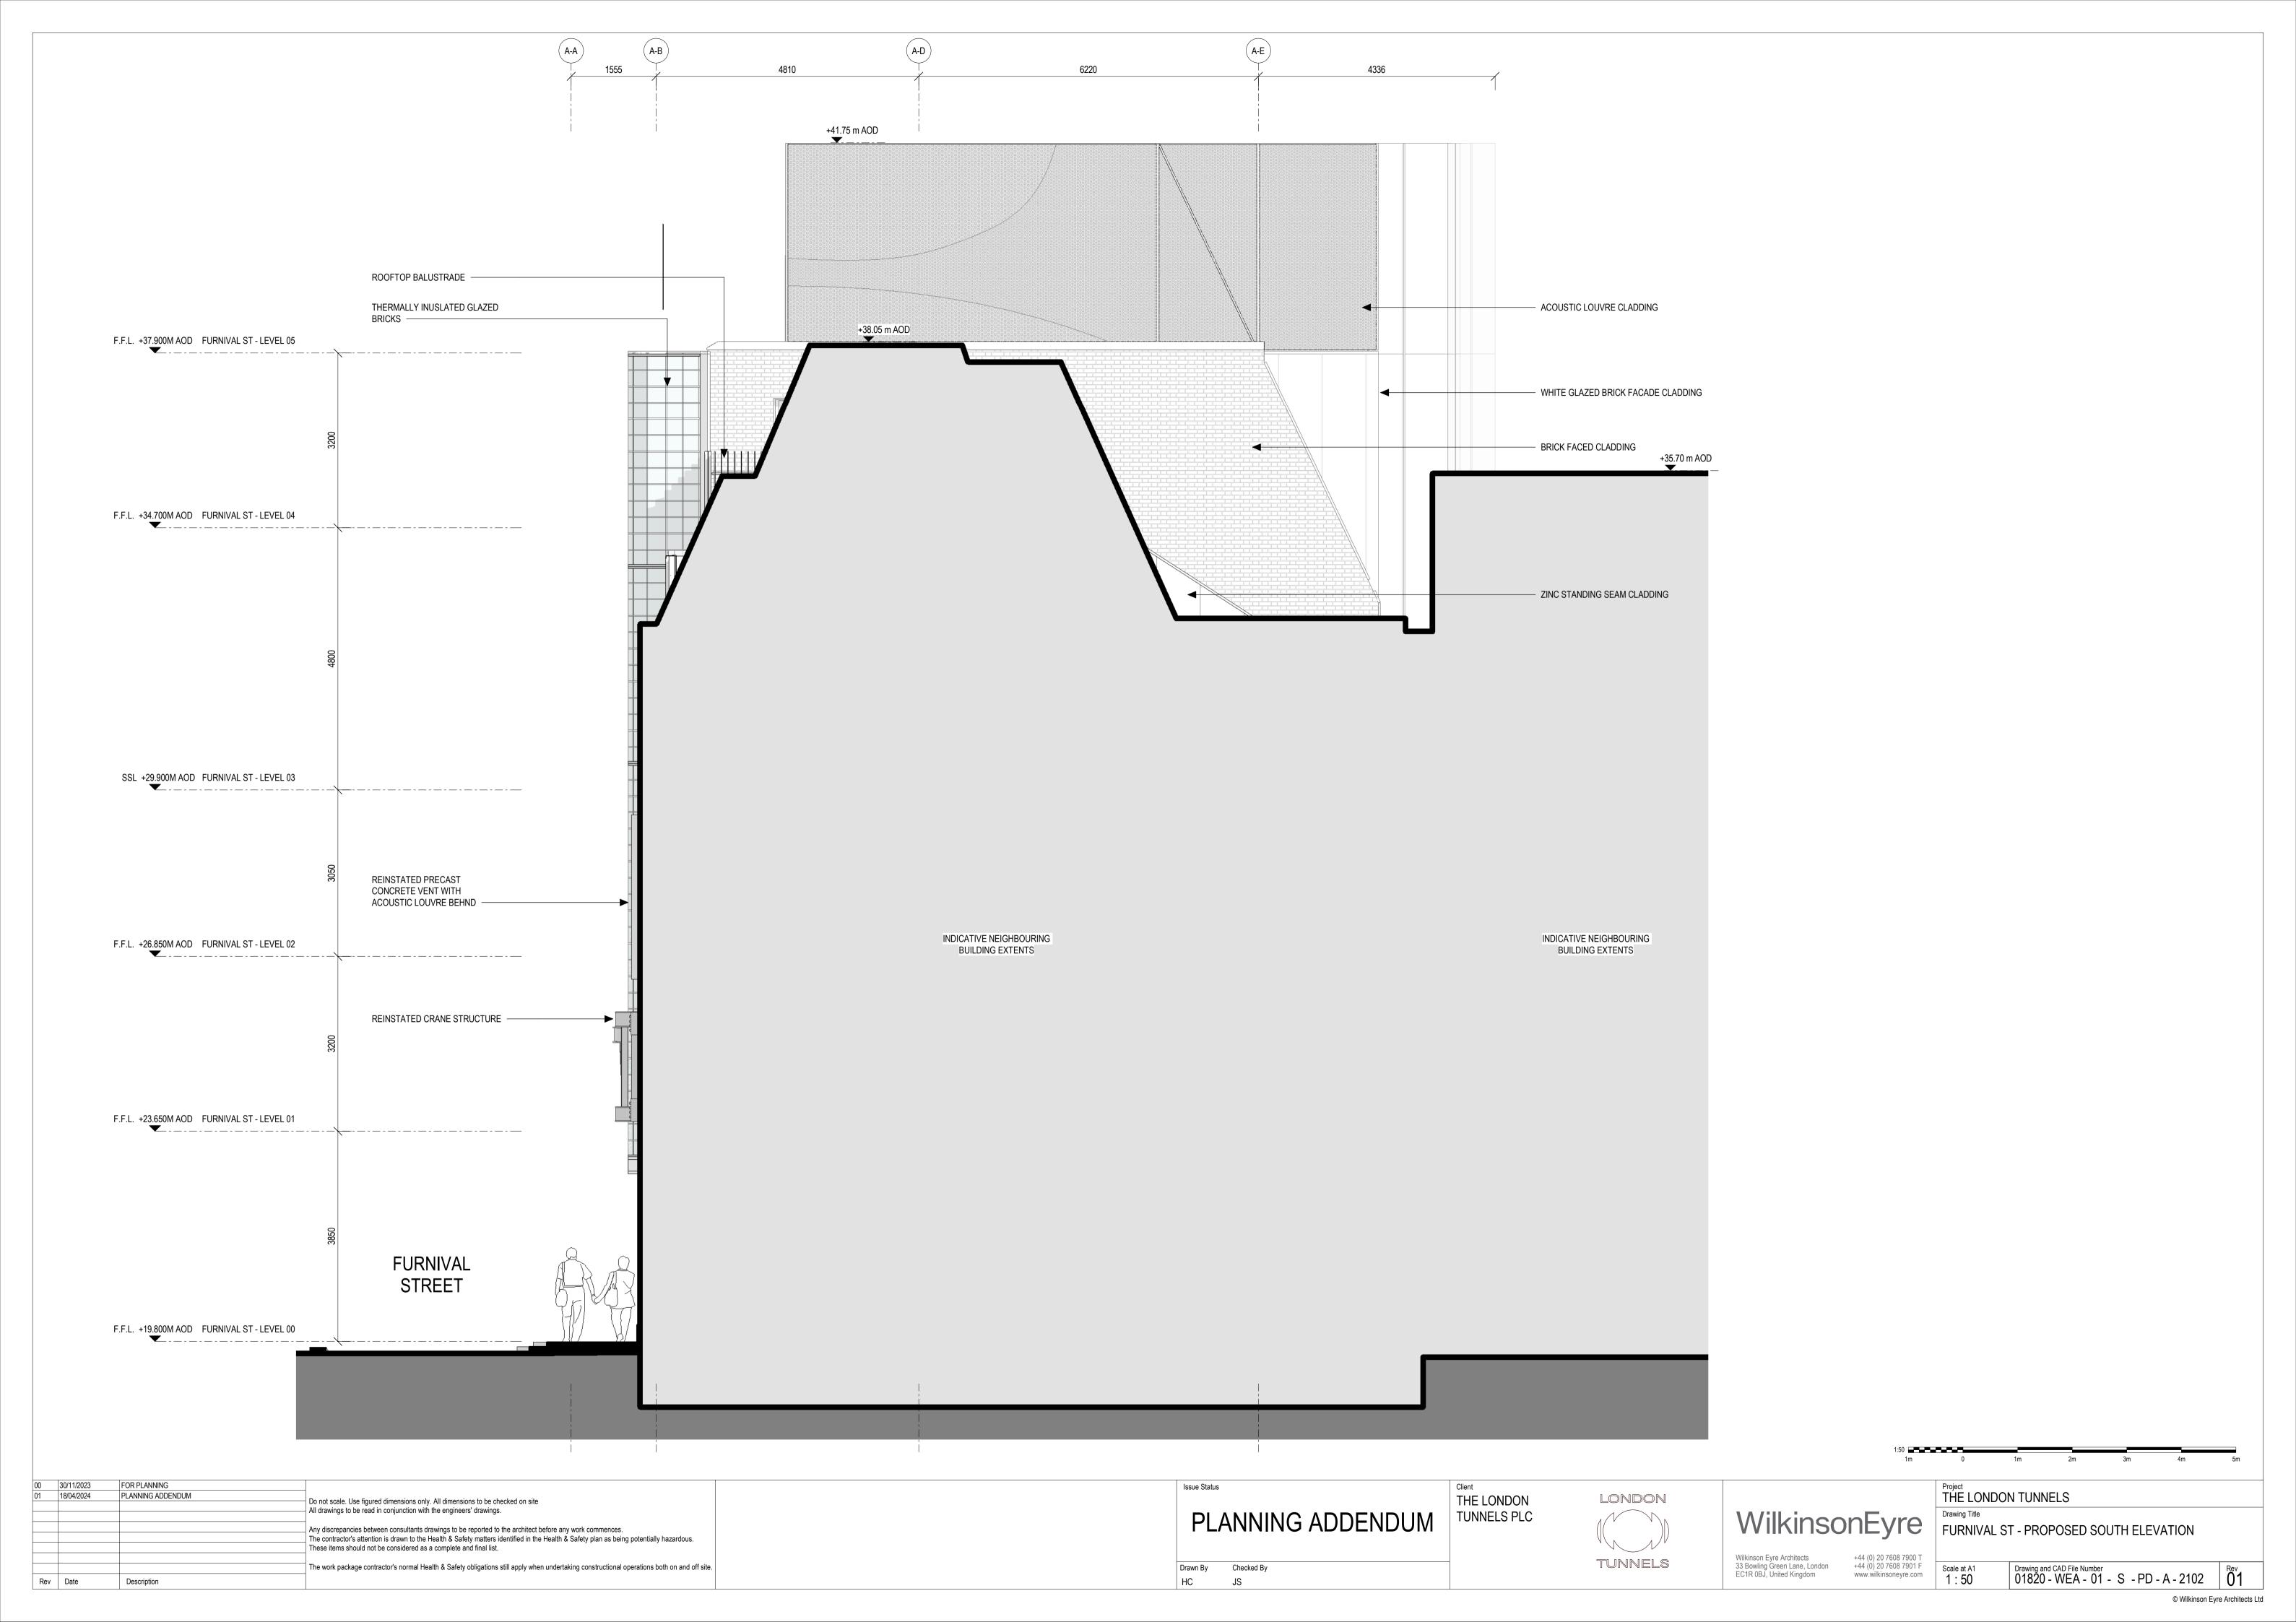

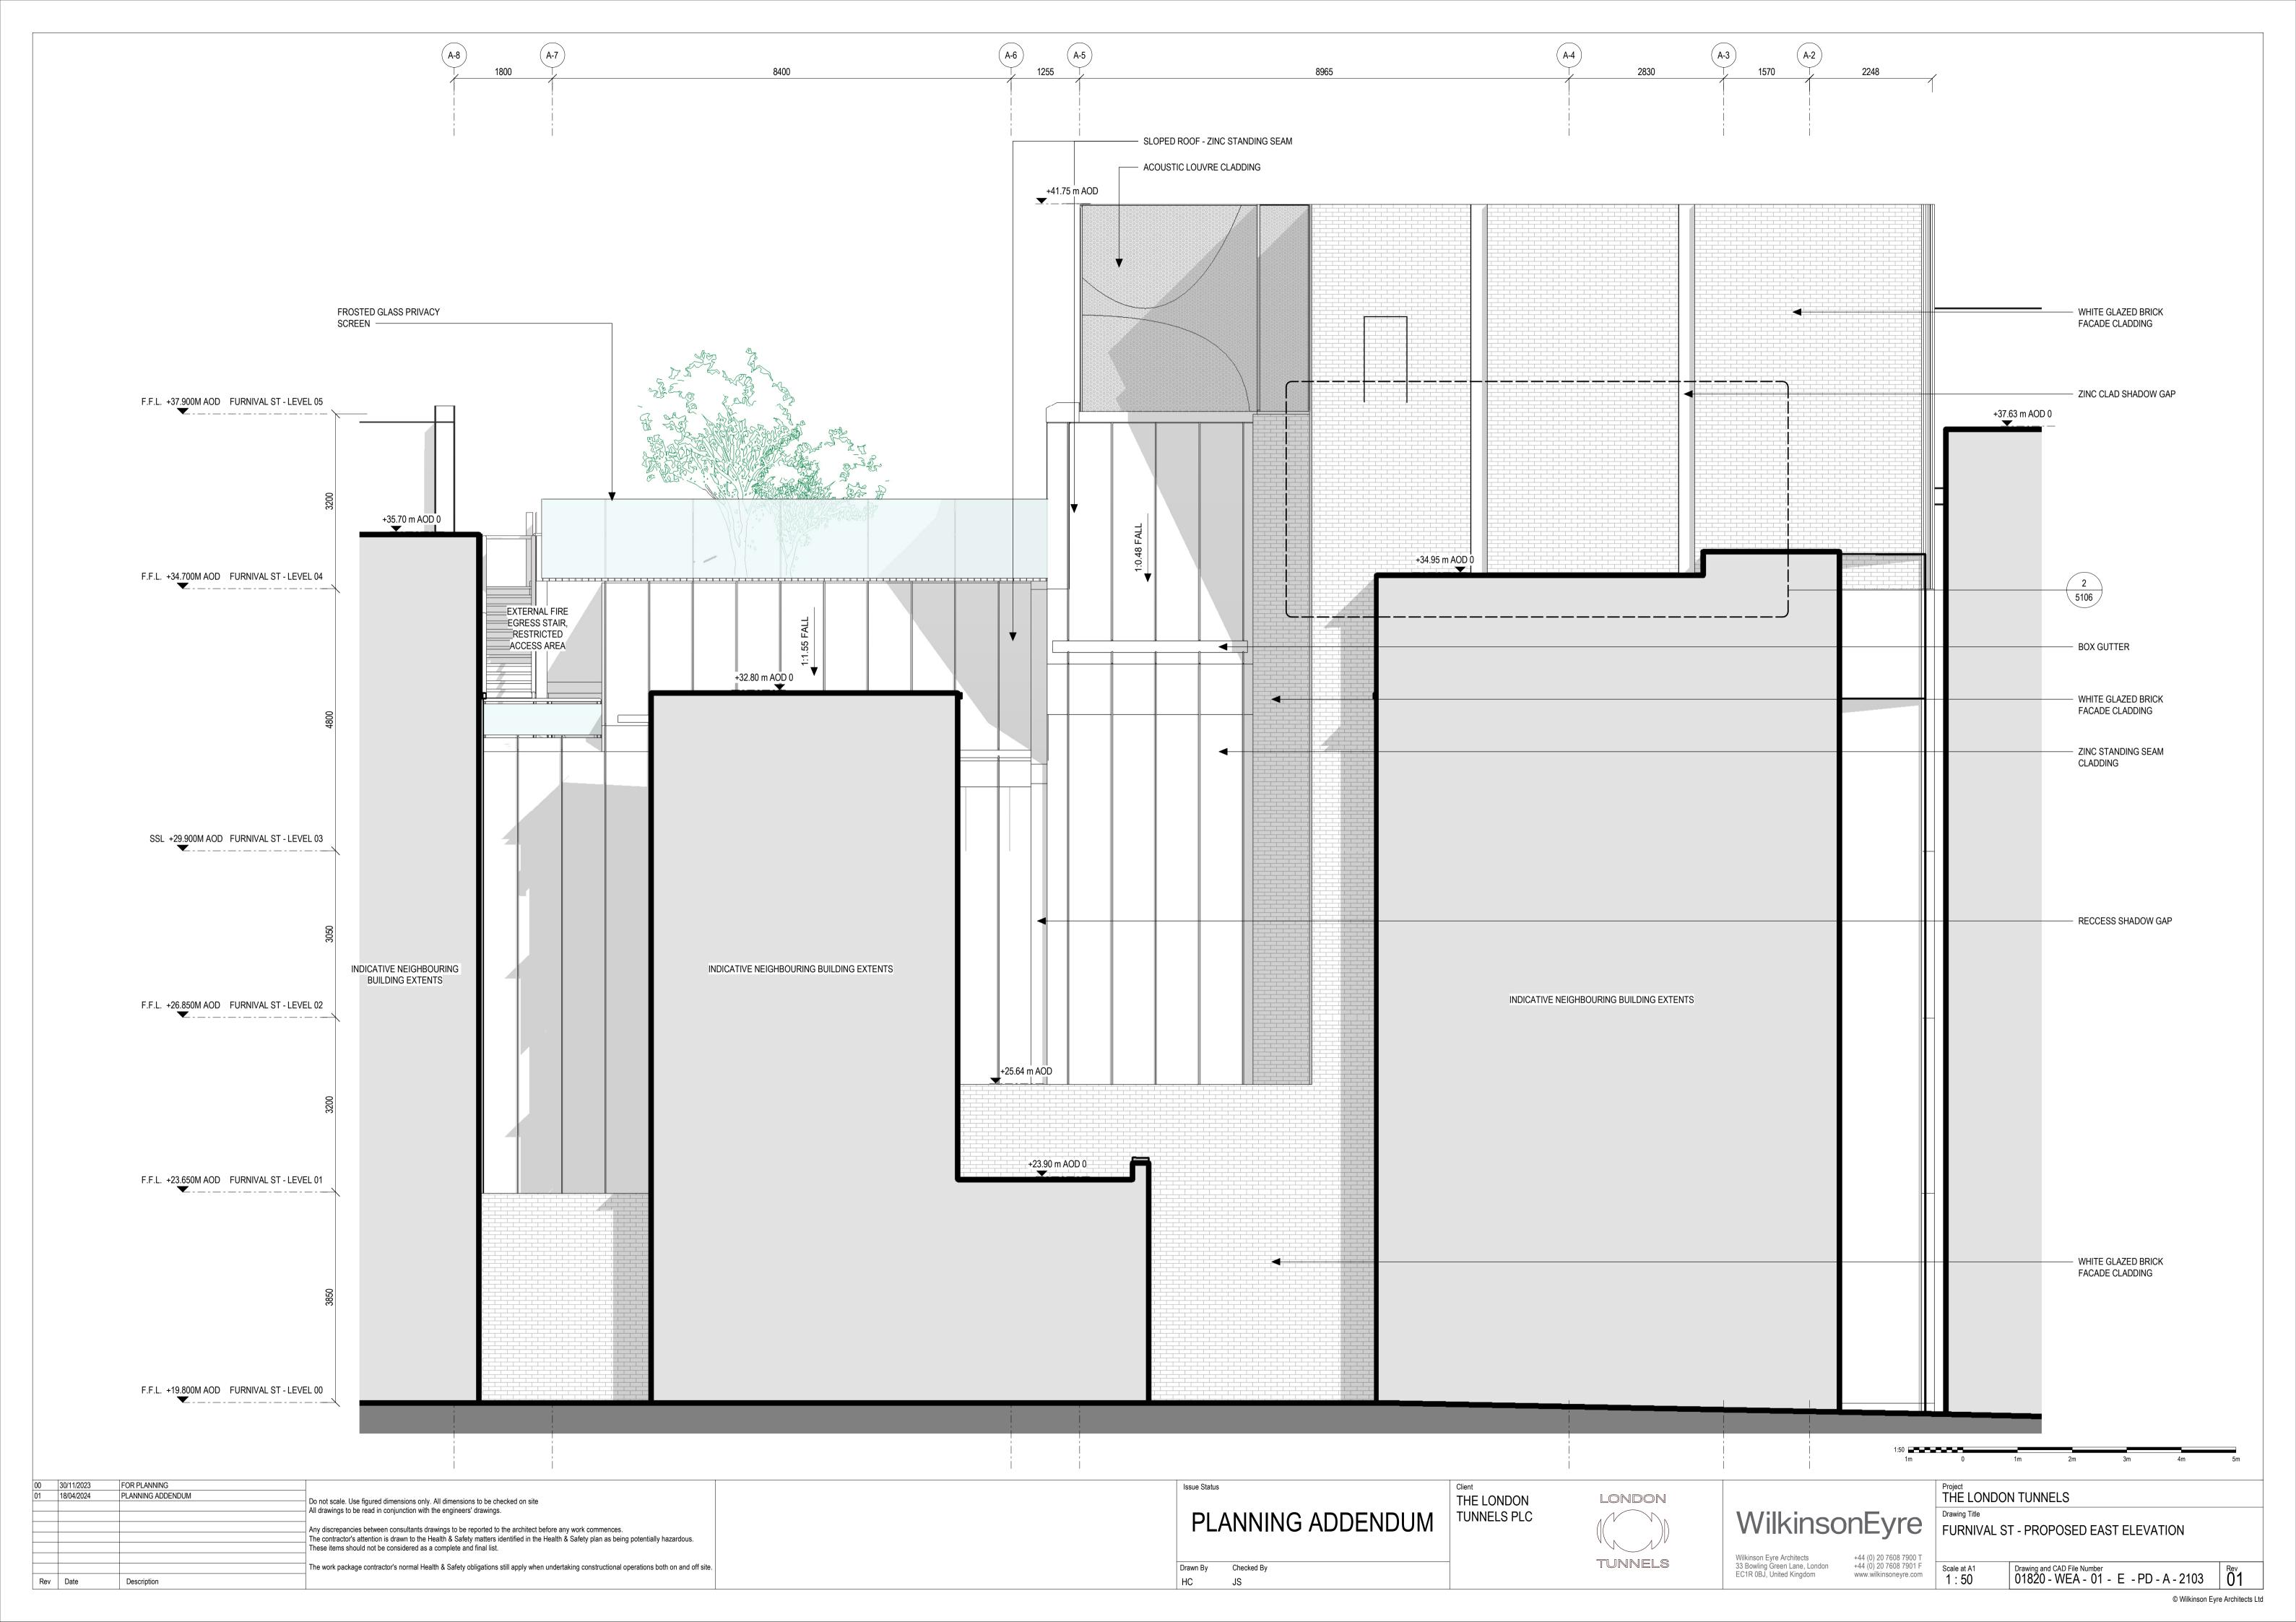

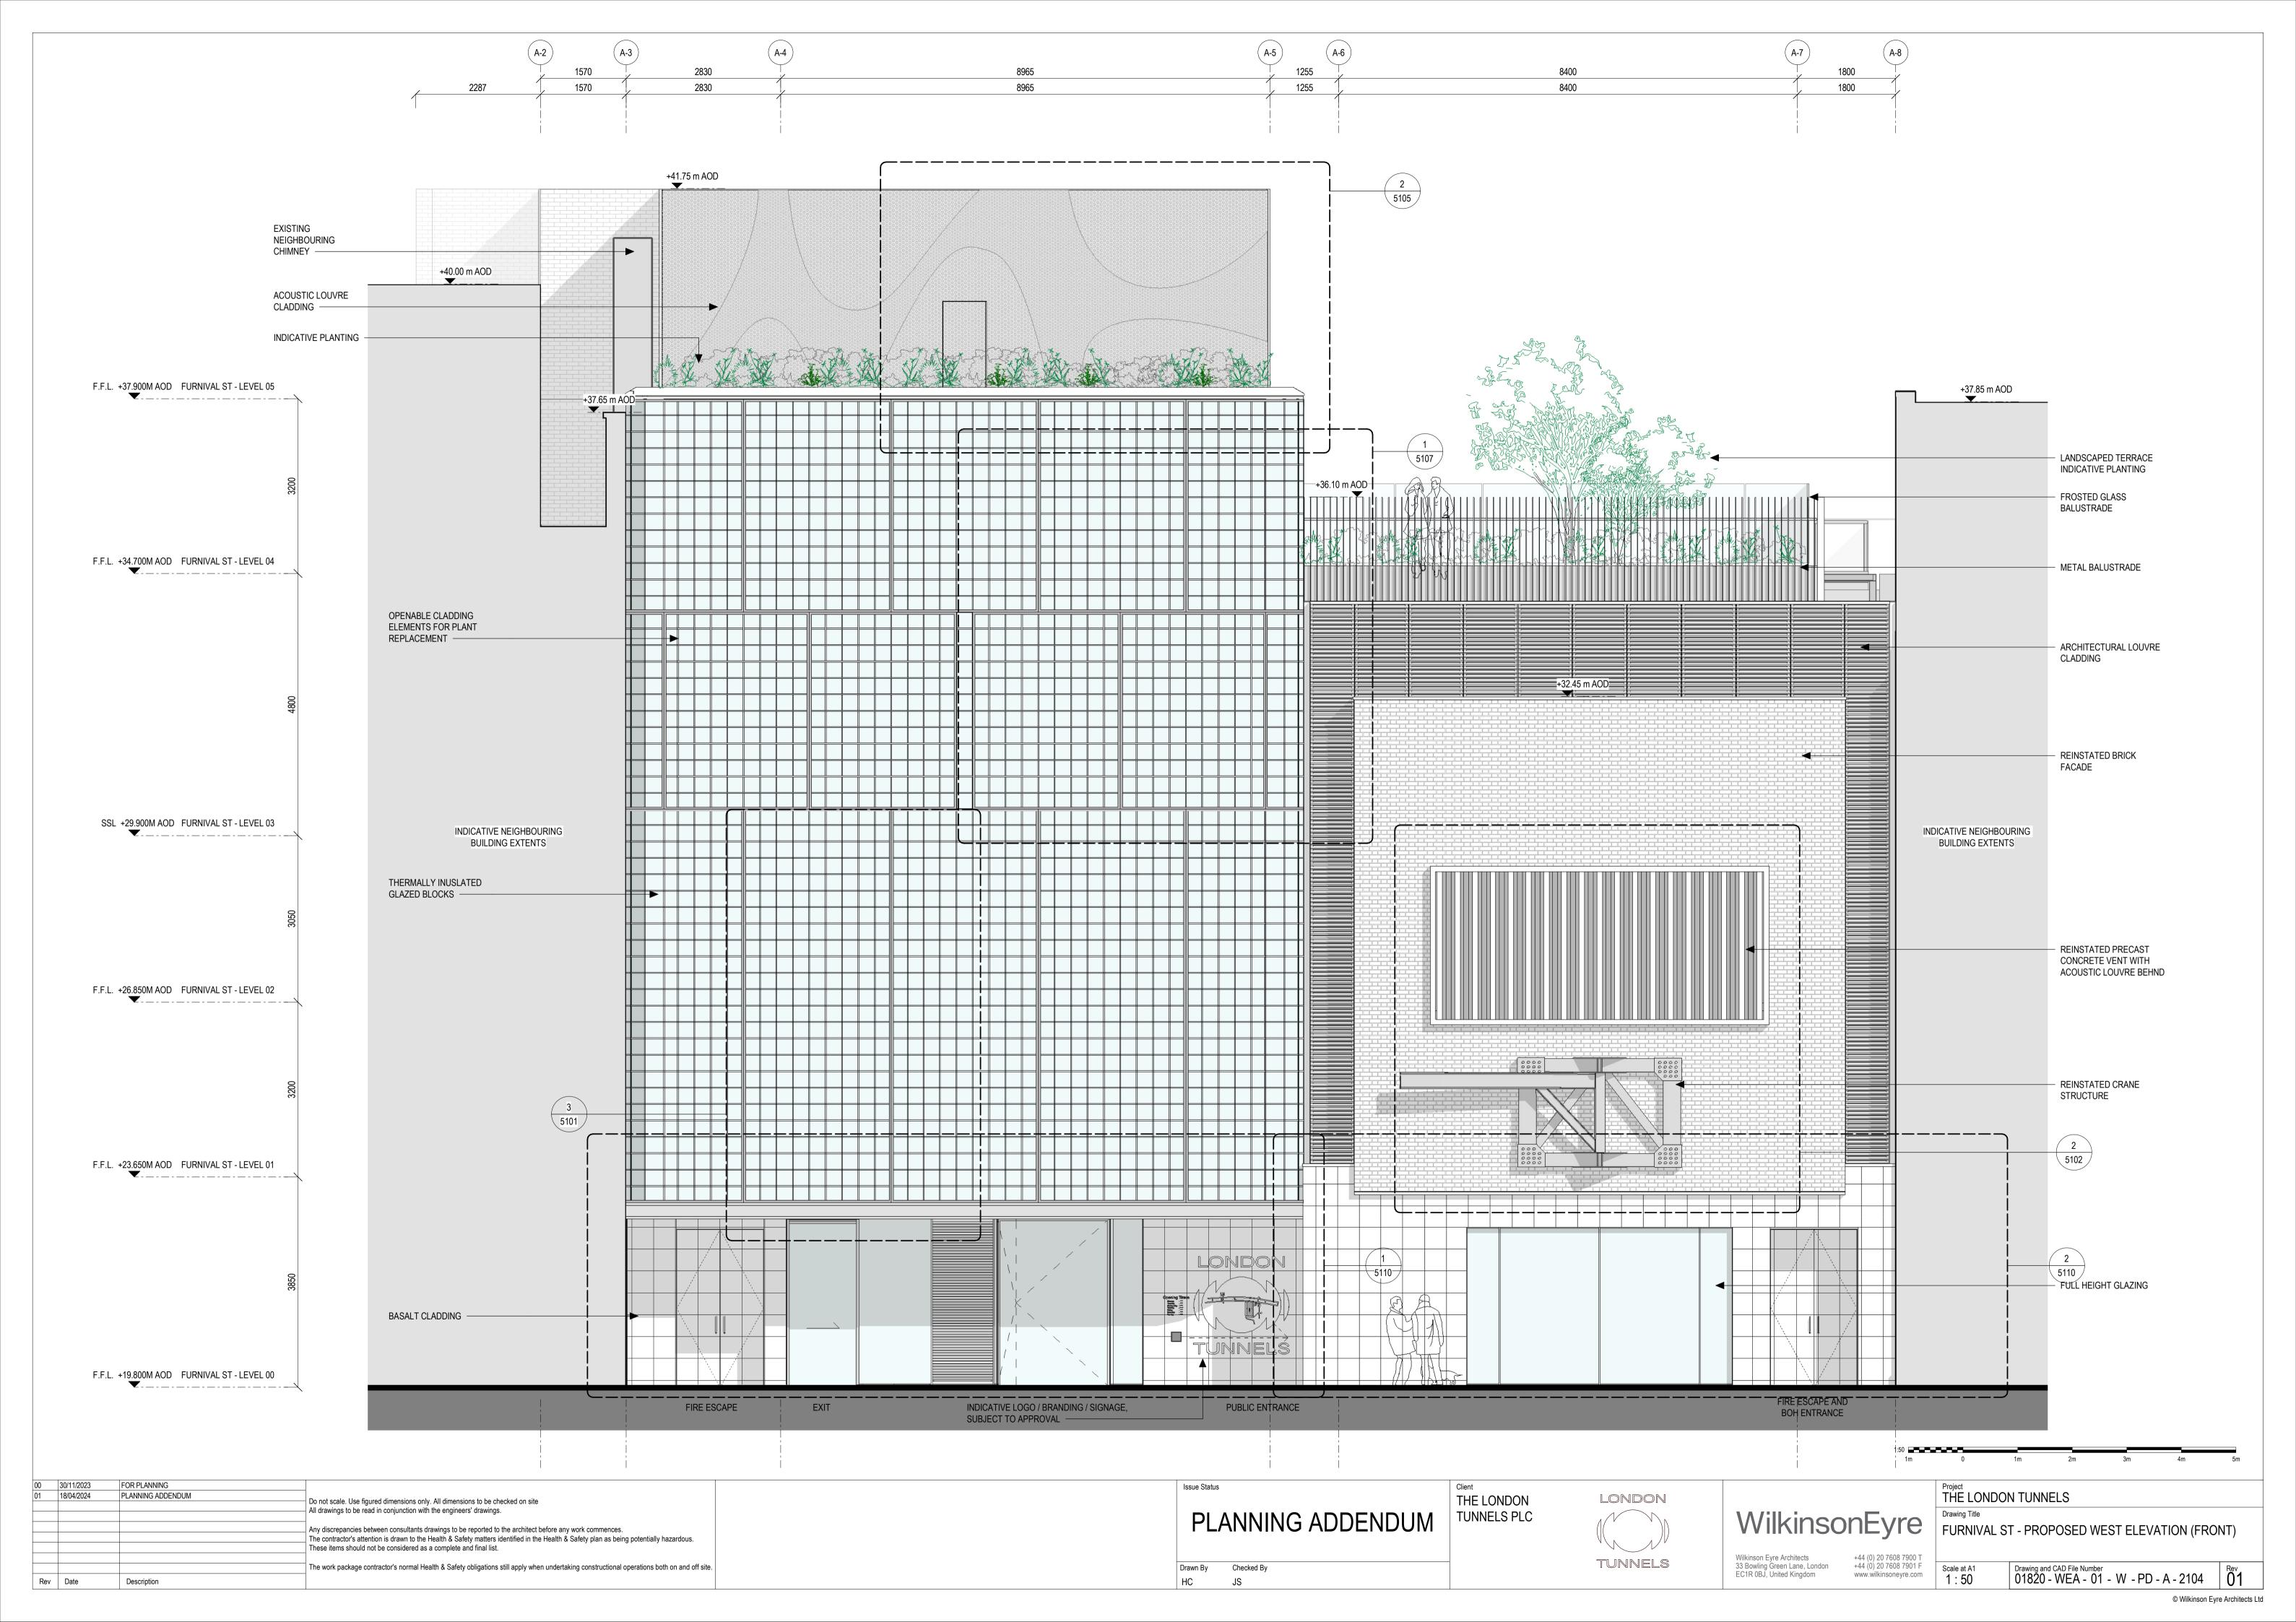

WilkinsonEyre

Wilkinson Eyre Architects 33 Bowling Green Lane London, EC1R 0BJ

E: info@wilkinsoneyre.com T: + 44 (0) 20 7608 7900 F: + 44 (0) 20 7608 7901

www.wilkinsoneyre.com