
Materials Key. Red brickwork in english bond
Stone dressings
Slate tiled roof turret
Existing windows
Glazed entrance
Black cladding
White cladding
Tinted curtain wall
Louvres
Fire escape doors
Black metal walkways
Black metal walkways
Proposed signage above entrance
Proposed new double glazed units in existing circular openings
Proposed black PPC steel and glazed entrance
Proposed window replacing extisting entrance
Proposed window replacing extisting entrance
Proposed black colour backed glass
Proposed PPC metal cycle store
Proposed PPC metal and timber bin store
Proposed window wills lowered with new glazing

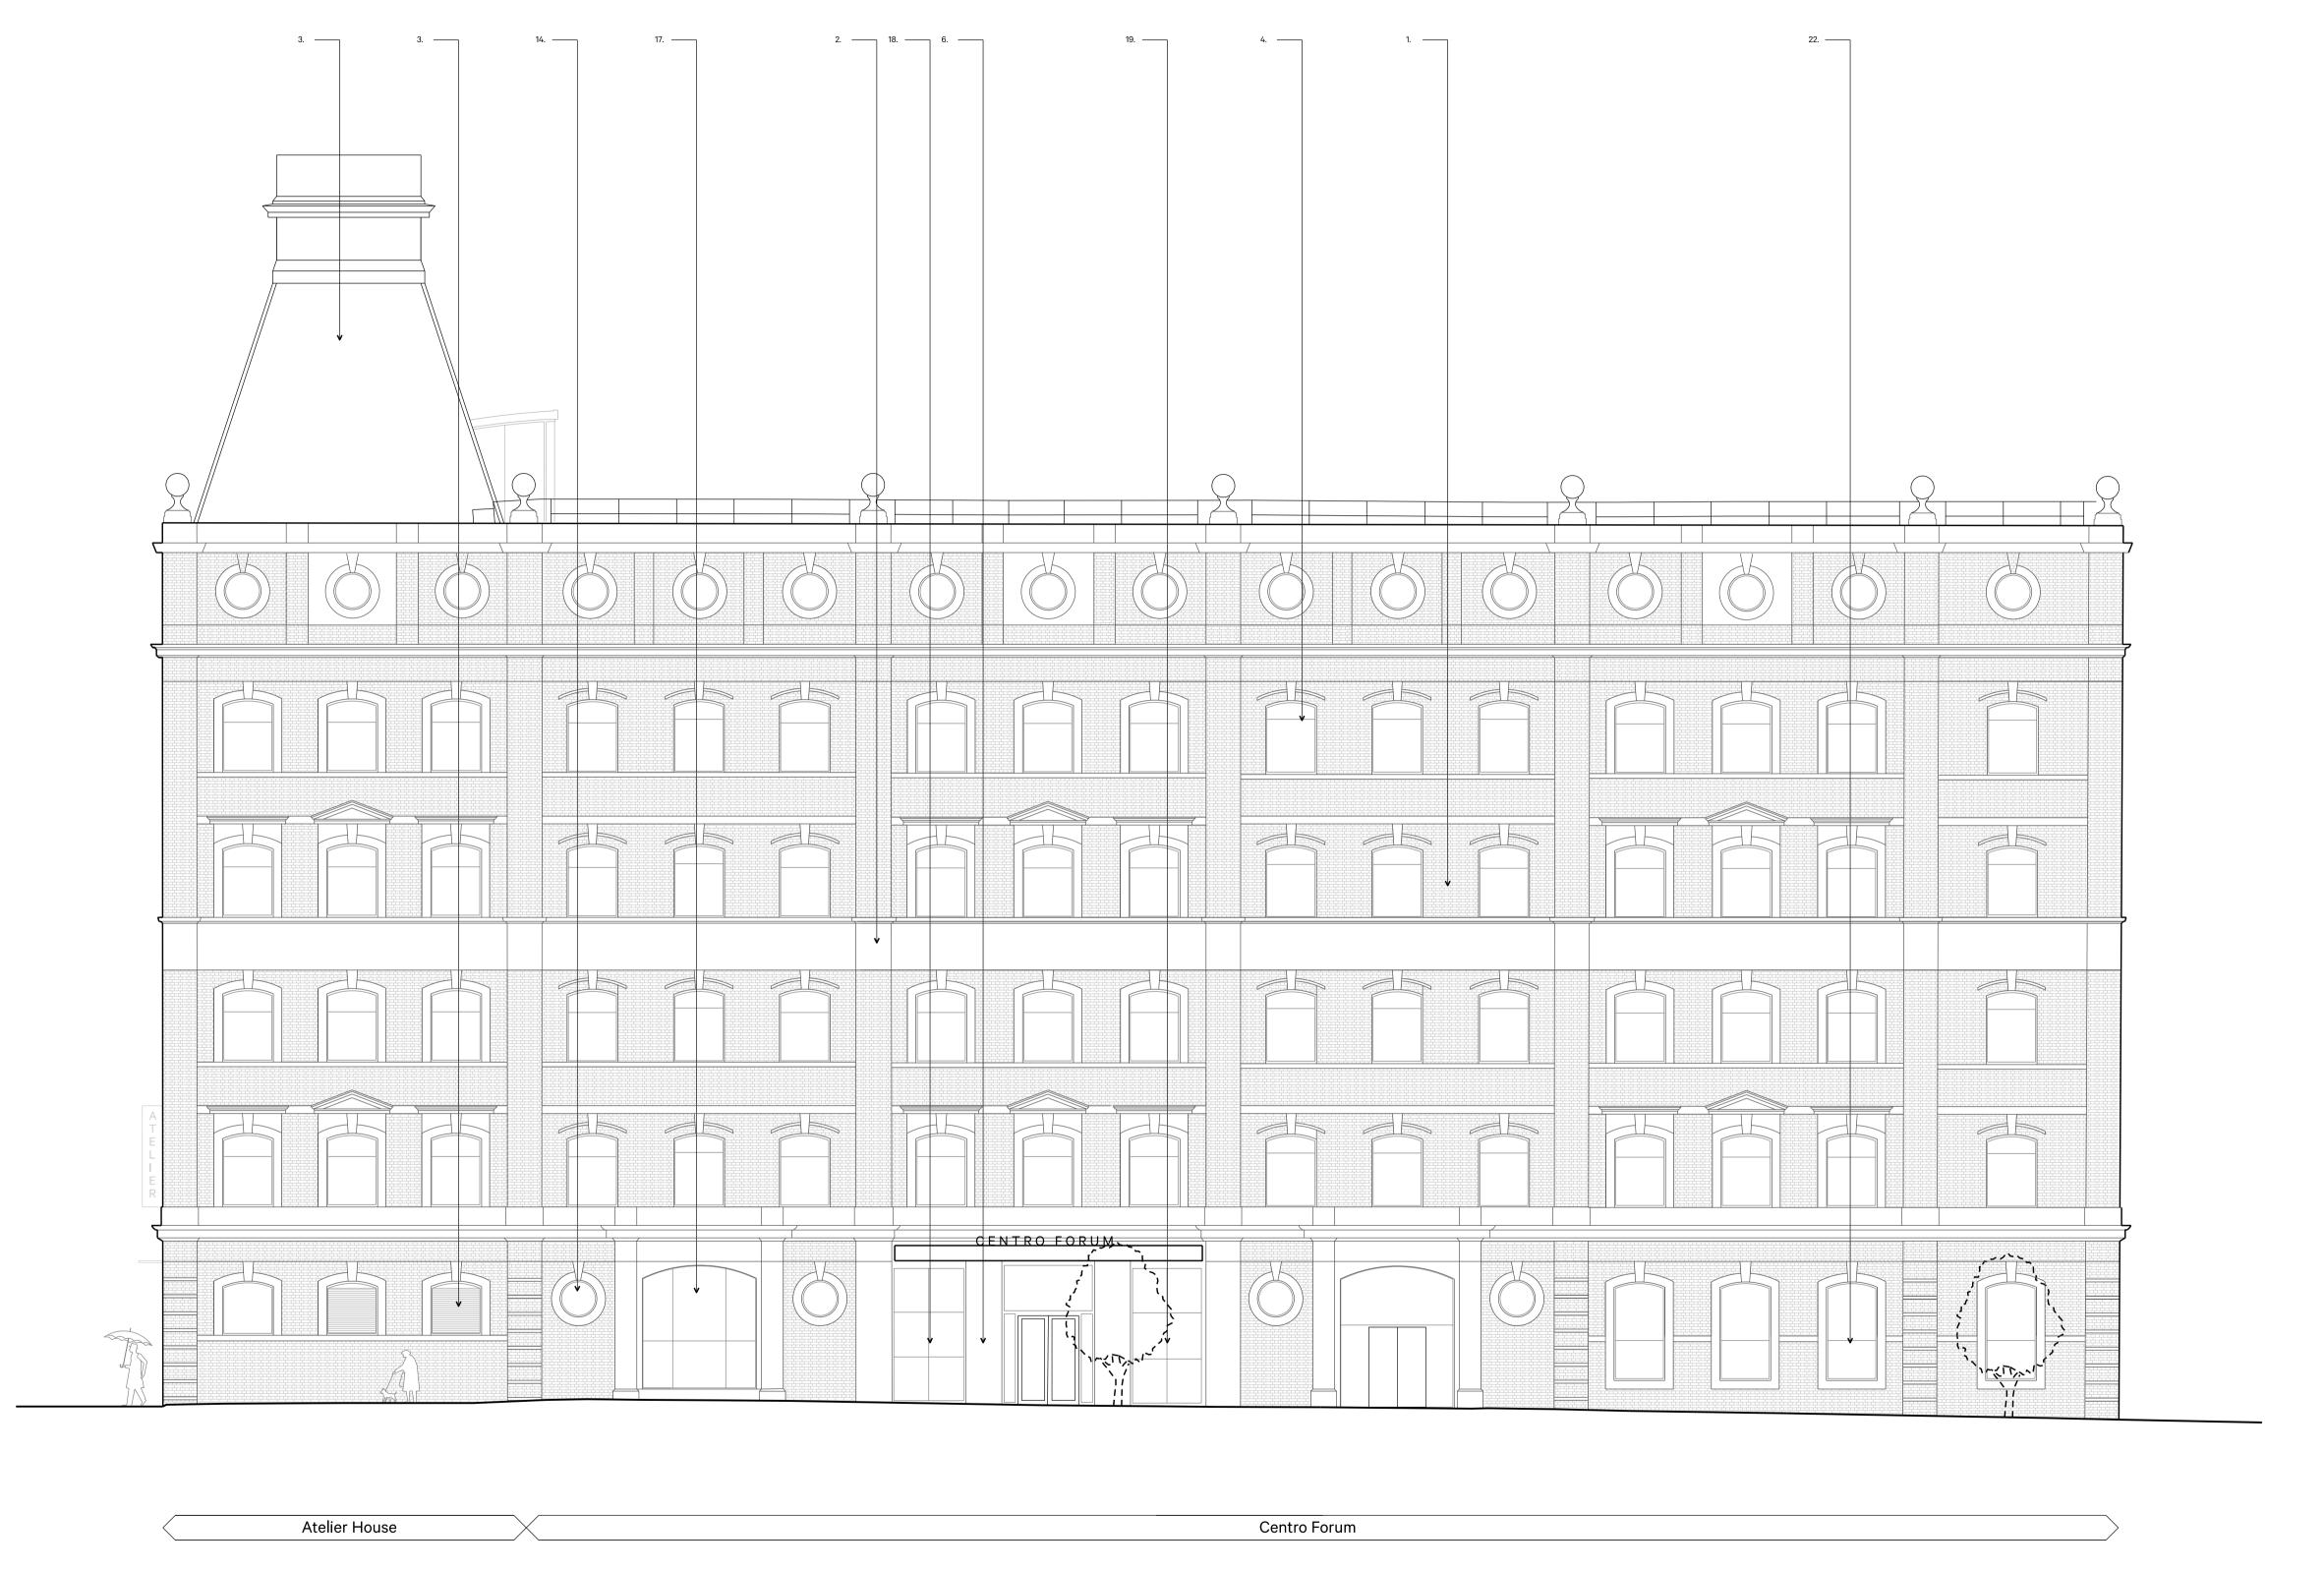

 (\mathbf{W}) West Elevation as Proposed

0 1 2 3 4 5

GENERAL NOTES

- All details and materials subject to approval from Building Control and Planning Application.
 All dimensions to be checked on site prior to ordering or manufacturing. Do not scale from these drawings.
 Drawings indicative only. Absolute site dimensions to be ascertained by the contractor for all measured items & installations.
 All items to be installed in accordance with manufacturers recommendations and standard installation details. Contractor to provide relevant information as part of O&M Manual for the client operation and maintenance.
 Refer to SE drawings for all structural items.
 M+E input to be obtained by main contractor for all relevant items.
 All discrepancies to be reported to the client/architect.
 Refer to Principle Designers information prior to commencement on site.
 Where building components are described as contractor or specialist designed "construction" information relating to those components on this drawing represents design intent only.
 Manufacturers recommendations and instructions on installation should always be followed.
 Drainage layout indicative only. To specialist contractor / structural engineers design / specification.

| Revisions | |
|------------------------------------------------------------------------------------------------------------------------------------------------------------------------------------------------------------------|--------------------------------------------|
| | |
| | |
| C 26.07.24 Planning update B 25.07.24 Planning update A 28.03.24 Planning Issue | JA JA |
| B 25.07.24 Planning update | JA JA JA |
| B 25.07.24 Planning update A 28.03.24 Planning Issue - 16.02.24 Stage 3 Preliminary Issue | JA JA JA |
| 8 2507.24 Planning update A 2803.24 Planning Issue Rev. Date Notes Project: Atelier House Client | JA JA JA |
| B | JA JA JA |
| B 25.07.24 Planning update A 28.03.24 Planning Issue Rev. Date Notes Project: Atelier House Client Workspace Group PLC | JA JA JA |
| B | JA JA Drawn |
| B 25.07.24 Planning update A 28.03.24 Planning Issue Planning Issue Rev. Date Notes Project: Atelier House Client Workspace Group PLC Drawing Title West Elevation as Proposed Scale 1:100.@A1 Drawing No. | JA JA Drawn |
| B | JA JA JA Drawn Date February 20 Revision |
| B | JA JA Drawn Date February 202 |

ArkleBoyce.