




DG-02 Glazed timber door Power operated door with pad controls

DG-01 Solid 2 panels timber front door Power operated door with pad controls

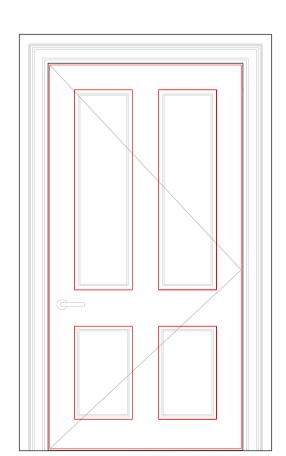


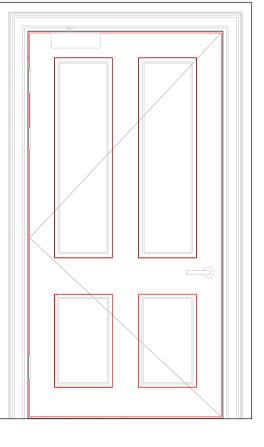


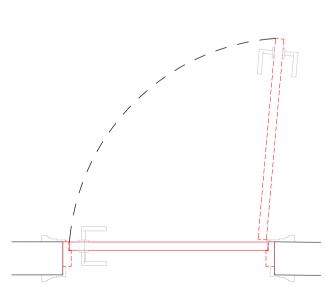


DG-05 Solid 4 panels fire rated timber door (Fd-30S)

PROPOSED Doors Schedule Scale 1:20

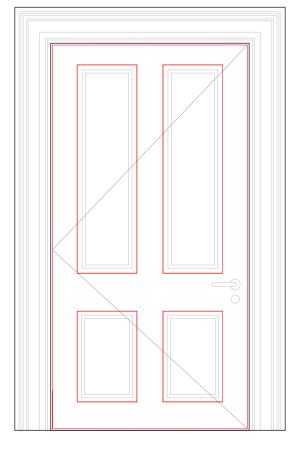


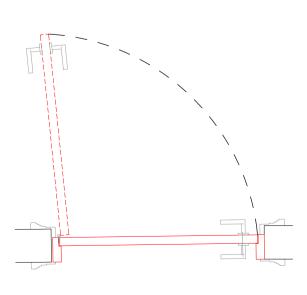



DG-07 Solid 4 panels fire rated timber door (Fd-30S)

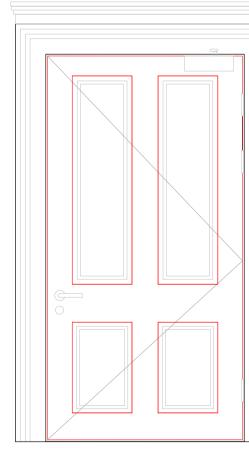





 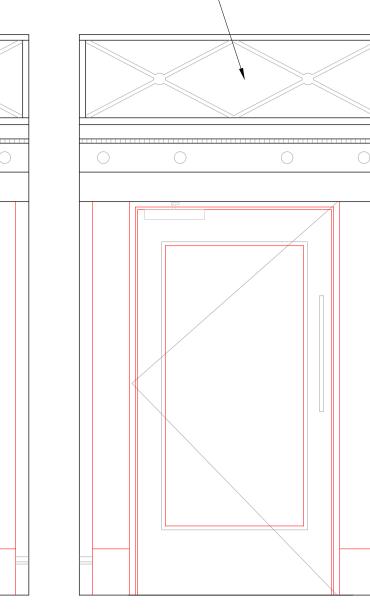


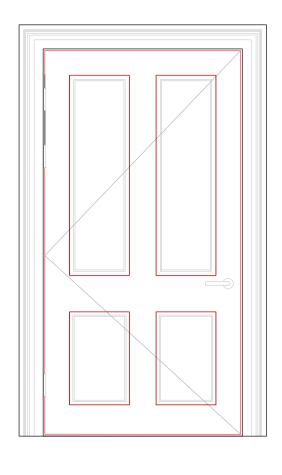


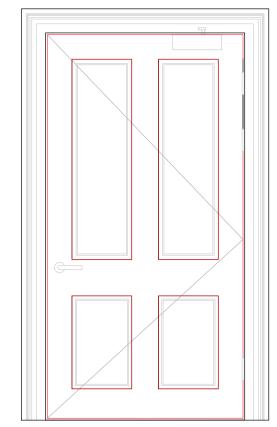


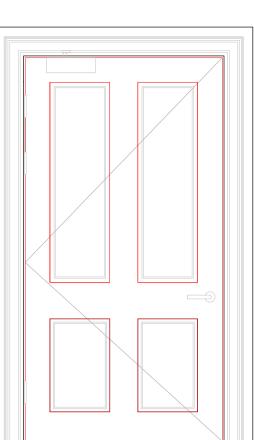


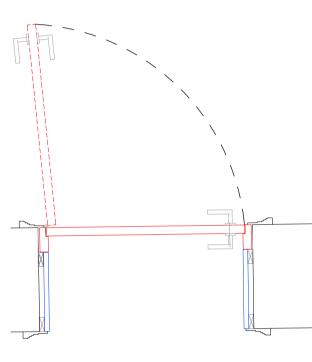





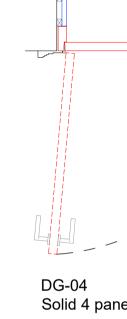


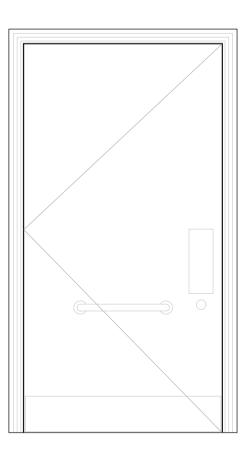

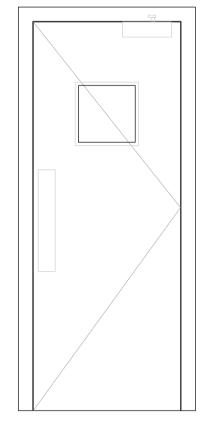


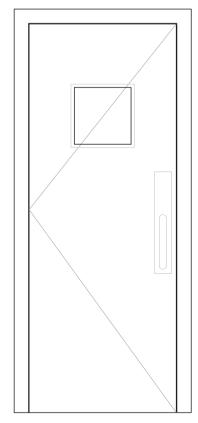

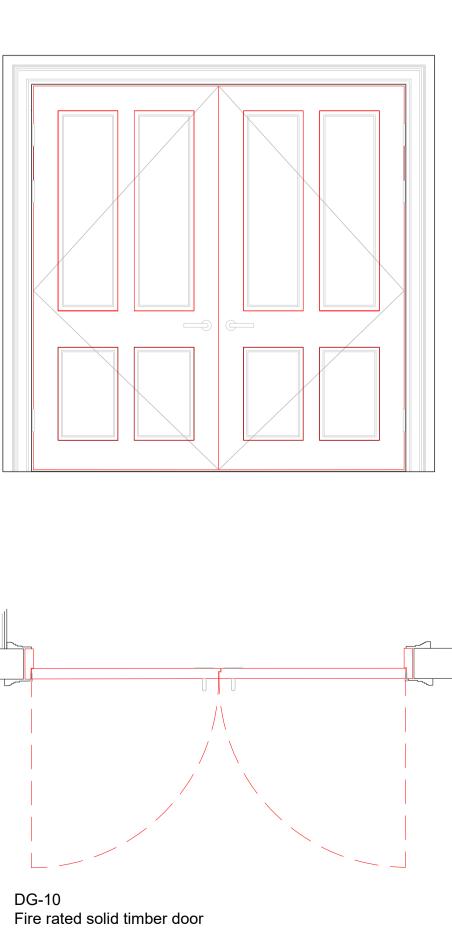


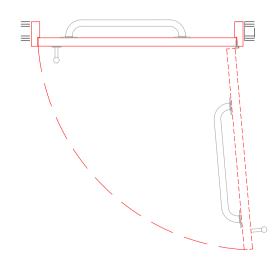

DG-08 Solid flush timber door Power operated door with pad controls

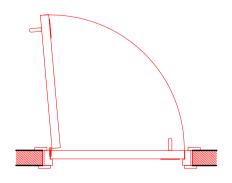

DG-09 Fire rated solid timber door with vision panel

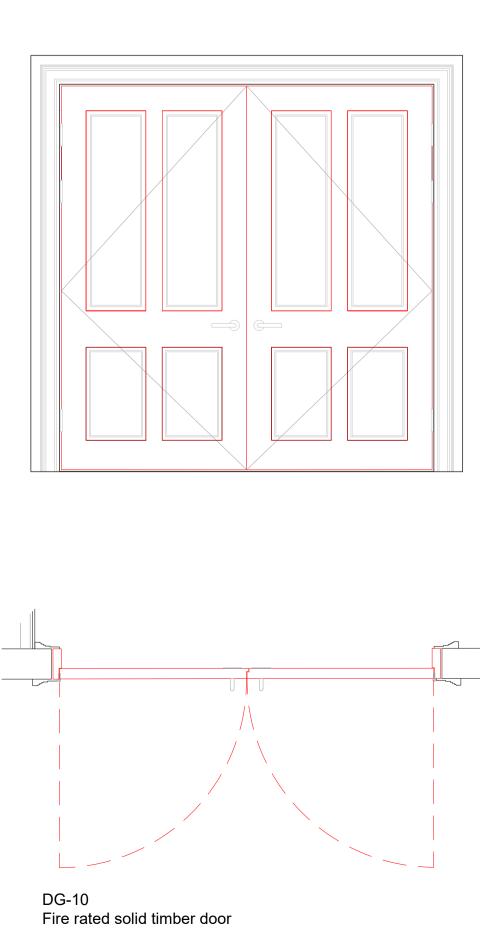

Power operated door with pad controls




NOTE: All new doors to be hold open and provided with Free-Motion door closers (or similar approved) linked to the fire alarm systemb(except DG-01 to be on actuators and DG-08).

© THIS DRAWING IS A COPYRIGHT OF BARKER ASSOCIATES.

NOTES: ALL LEVELS, ANGLES AND DIMENSIONS TO BE CHECKED ON SITE PRIOR TO COMMENCEMENT OF WORKS.

THIS DRAWING IS TO BE READ IN CONJUNCTION WITH ALL RELEVANT STRUCTURAL ENGINEERS AND MECHANICAL AND ELECTRICAL ENGINEERS DRAWINGS, DETAILS AND SPECIFICATIONS.

Scale 1:20 2 (metres) 0 0.2 0.4 0.6 0.8 1

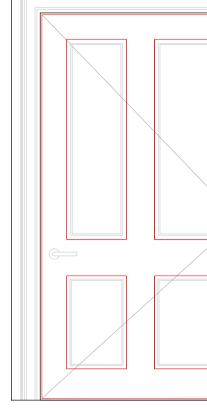

DG-04 Solid 4 panels fire rated timber door (Fd-30S)

Drawing Status: PLANNING and LBC					
P03	DG-08 & DG-09 Added			18/03/24	ЈМ
P02	LG doors omittted			08/03/24	JM
P01	Issued for comments		nents	04/03/24	JM
Rev Description				Date	Ву
Client Client MAJESTY HOUSE, AVENUE WEST SKYLINE 120, BRAINTREE ESSEX, CM77 7AA T: 01279 647111 W: www.barker-associates.co.uk E: mail@barker-associates.co.uk Client UNIVERSITY COLLEGE LONDON					
Accessibility Works at Political Sciences School, 36-38 Gordon Square, London, WC1H 0PD Drawing Title Proposed Doors Schedule					
Drawn J	JM		scale 1/20 @ A1	Date 01/03/2024	
ARCHITECTURAL					
				Project No.P24-0166	
Drawing Number				Status Revision	
P24-0166-BA-A1-XX-DR-A-7105 S0 P03					