


This drawing should be read in conjunction with all drawings and schedules prepared as part of the design package. Ensure site dimensions are checked prior to manufacture and installation. Ensure all joinery is restrained to structural envelope as necessary. All finishes to be applied as manufacturers instructions.

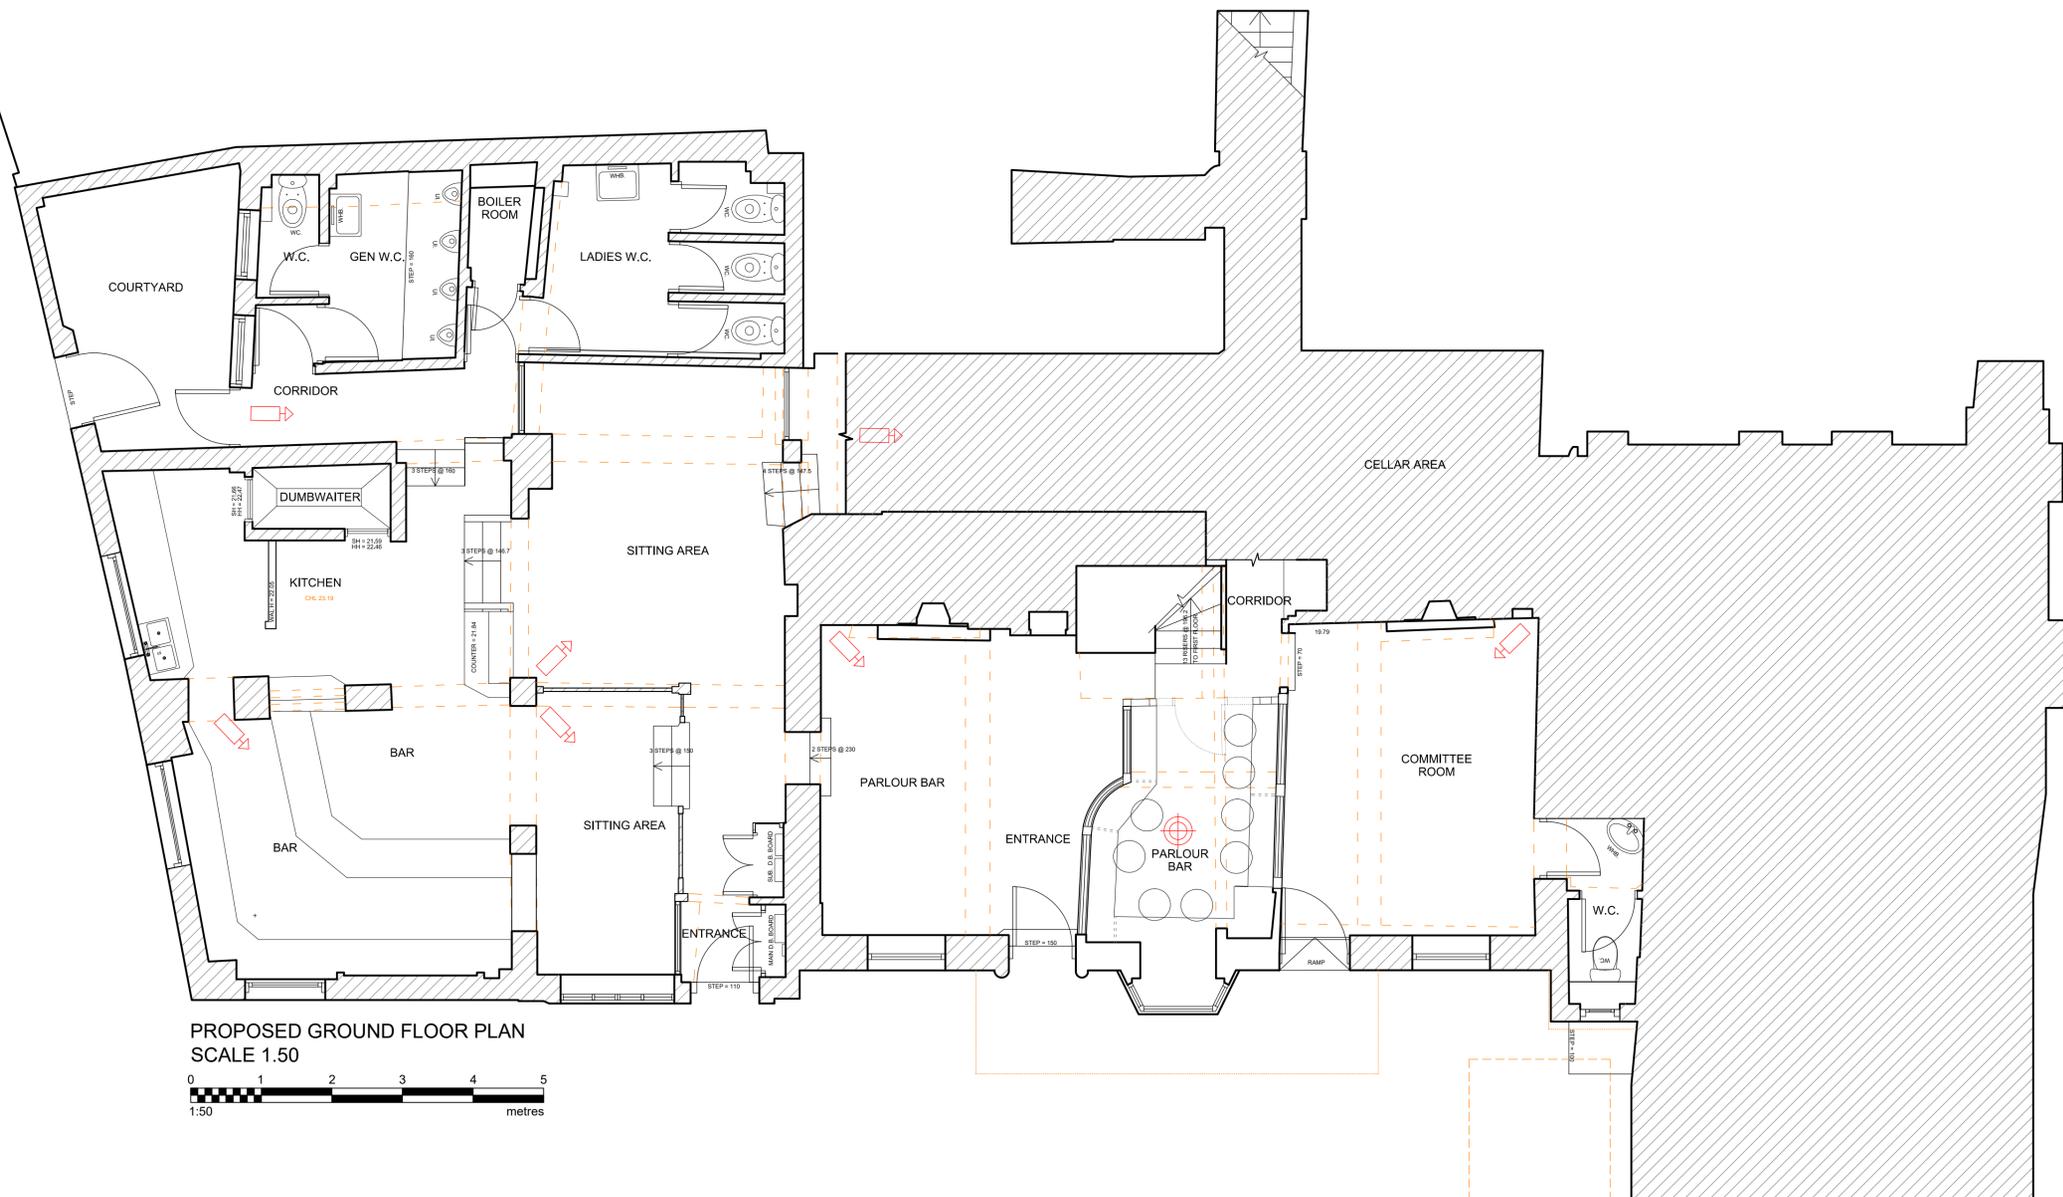

PROPOSED GROUND FLOOR PLAN
SCALE 1:50



 **CCTV CAMERA**
New CCTV camera installation. New data cable installed to each camera and wired back to office. See separate data sheet for camera specification.

Rev	Revision Details	Initials	Date
xx			00.00.00

newman|gauge
E.design@newmangaugue.com T. 0121 212 9800
47A George St Birmingham B3 1QA
newmangaugue.com



Project
**THE FLASK
HIGHGATE**
Drawing Title
**GROUND FLOOR PLAN
- CCTV INSTALLATION**

Project Type
LISTED BUILDING APP

Date	Scale	Drawn By
DEC'24	1:50@A1	RO
Project No.	Drawing No.	Revision
3111	202	

This drawing is the property of NEWMAN GAUGE DESIGN ASSOCIATES. Copyright is reserved by them and the drawing is issued on the condition that it is not copied, wholly or in part without the prior consent in writing of Newman Gauge Design Associates. All dimensions are to be checked on site prior to the commencement of any work or shop drawings. This drawing is to be read in conjunction with other drawings and specifications where existing.