 



- 1. DO NOT SCALE FROM THIS DRAWING. ALL DIMENSIONS INDICATED ARE IN MILLIMETRES
- 2. DRAWING TO BE READ IN CONJUNCTION WITH SPECIFICATION, DOCUMENTATION, DRAWINGS & ALL RELEVANT BRITISH STANDARD DOCUMENTS
- 3. ALL ELECTRICAL WORKS SHALL COMPLY WITH 18TH EDITION IEE WIRING REGS BS7671:2018+A2:2022, INCLUDING ALL CURRENT AMENDMENTS AND GUIDANCE NOTES AND THE CURRENT BUILDING STANDARDS REGULATIONS
- 4. THE INSTALLATION SHALL ONLY BE CERTIFIED BY A PERSON OR A COMPANY HAVING MEMBERSHIP TO S.E.L.E.C.T. OR N.I.C.E.I.C. OR SIMILAR ELECTRICAL SCHEMES
- 5. FINAL LOCATIONS OF ALL VISIBLE ELECTRICAL EQUIPMENT TO BE COORDINATED WITH ARCHITECT

<u>LEGEND</u>

🥏 E2	EMERGENCY ESCAPE RECESSED LIGHTING
	ZUMTOBEL RESCILITE PRO MRCR RSC E3DG5 WH 42936332
e E1	EMERGENCY ANTI PANIC RECESSED EMERGENCY LIGHT
	ZUMTOBEL RESCLITE PRO MRCR ANT E3DG5 WH 42934755
e E3	EMERGENCY ESCAPE SURFACE MOUNTED LIGHTING
	PHILIP PAYNE LANTIS BULKHEAD L300
🥏 E4	EMERGENCY WALL MOUNTED LIGHTING
	GUIZINNI MOTUS ANTIPANIC QY39 LIGHT FITTING.
	WALL MOUNTED EXIT LIGHTS
	VIABIZZUNO MERCATO 230 GRUPPO 101 FITTING



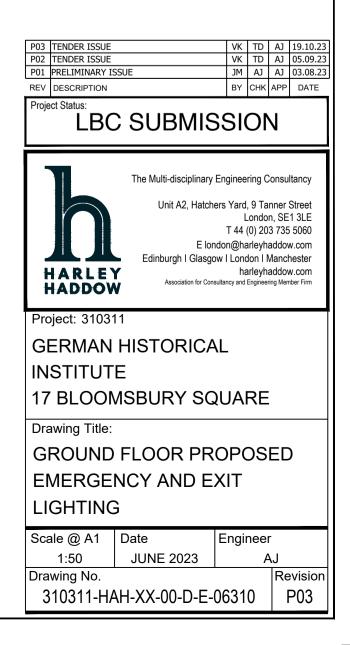





17




THIS DRAWING IS INDICATIVE AND REPRESENTS ONLY THE DESIGN INTENT, THE CONTRACTOR MUST PRODUCE FULLY CO-ORDINATED WORKING / INSTALLATION DRAWINGS AS REFERRED TO IN THE CONTRACT DOCUMENTATION LIGHTING NOTES


- 1. DO NOT SCALE FROM THIS DRAWING. ALL DIMENSIONS INDICATED ARE IN MILLIMETRES
- 2. DRAWING TO BE READ IN CONJUNCTION WITH SPECIFICATION, DOCUMENTATION, DRAWINGS & ALL RELEVANT BRITISH STANDARD DOCUMENTS
- 3. ALL ELECTRICAL WORKS SHALL COMPLY WITH 18TH EDITION IEE WIRING REGS BS7671:2018+A2:2022, INCLUDING ALL CURRENT AMENDMENTS AND GUIDANCE NOTES AND THE CURRENT BUILDING STANDARDS REGULATIONS
- 4. THE INSTALLATION SHALL ONLY BE CERTIFIED BY A PERSON OR A COMPANY HAVING MEMBERSHIP TO S.E.L.E.C.T. OR N.I.C.E.I.C. OR SIMILAR ELECTRICAL SCHEMES
- 5. FINAL LOCATIONS OF ALL VISIBLE ELECTRICAL EQUIPMENT TO BE COORDINATED WITH ARCHITECT

<u>LEGEND</u>

O E2	EMERGENCY ESCAPE RECESSED LIGHTING
	ZUMTOBEL RESCILITE PRO MRCR RSC E3DG5 WH 42936332
e E1	EMERGENCY ANTI PANIC RECESSED EMERGENCY LIGHT
	ZUMTOBEL RESCLITE PRO MRCR ANT E3DG5 WH 42934755
e E3	EMERGENCY ESCAPE SURFACE MOUNTED LIGHTING
	PHILIP PAYNE LANTIS BULKHEAD L300
e E4	EMERGENCY WALL MOUNTED LIGHTING
	IGUIZINNI MOTUS ANTIPANIC QY39 LIGHT FITTING.
EXIT	WALL MOUNTED EXIT LIGHTS
	VIABIZZUNO MERCATO 230 GRUPPO 101 FITTING
●E-X	EMERGENCY LIGHTING TO BE PROVIDE AS A MINIMUM AT THIS POSITION INTEGRATED INTO THE ARCHITECTURAL LIGHTING DESIGNERS FITTING. REFER TO LIGHTING DESIGNERS PACKAGE FOR FURTHER INFORMATION.

P03 TENDER ISSUE P02 TENDER ISSUE P01 PRELIMINARY IS REV DESCRIPTION	SUE	VK VK JM BY	TD TD AJ CHK	AJ AJ AJ	19.10.23 05.09.23 03.08.23 DATE
Project Status:	SUBMIS				DATE
harley HADDOW	 Edinburgh I Glasgov 	rs Yard I T 44 on@ha / I Lond ha	, 9 Ta Londo (0) 20 arleyh don I I arleyh	nner n, SE 3 735 addov Vancl addov	Street 1 3LE 5 5060 w.com hester w.com
INSTITUTI	HISTORICA	_	RE		
	DOR PROPO NCY AND EX		Đ		
Scale @ A1 1:50 Drawing No. 310311-HA	Date JUNE 2023 H-XX-01-D-E-0	Engi	A	λJ Re	evision P03

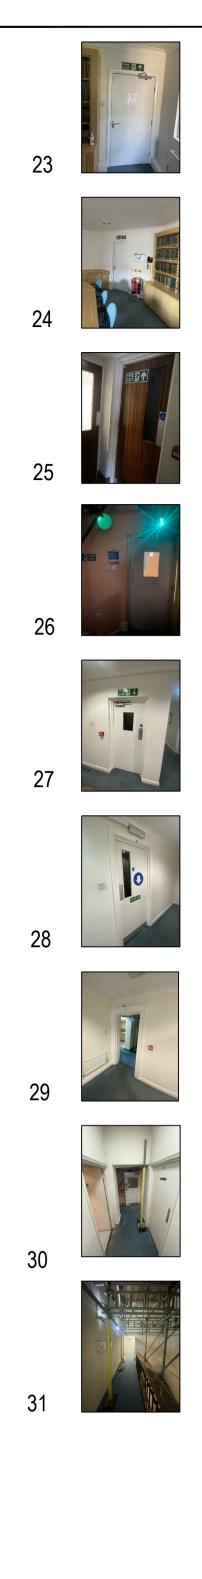


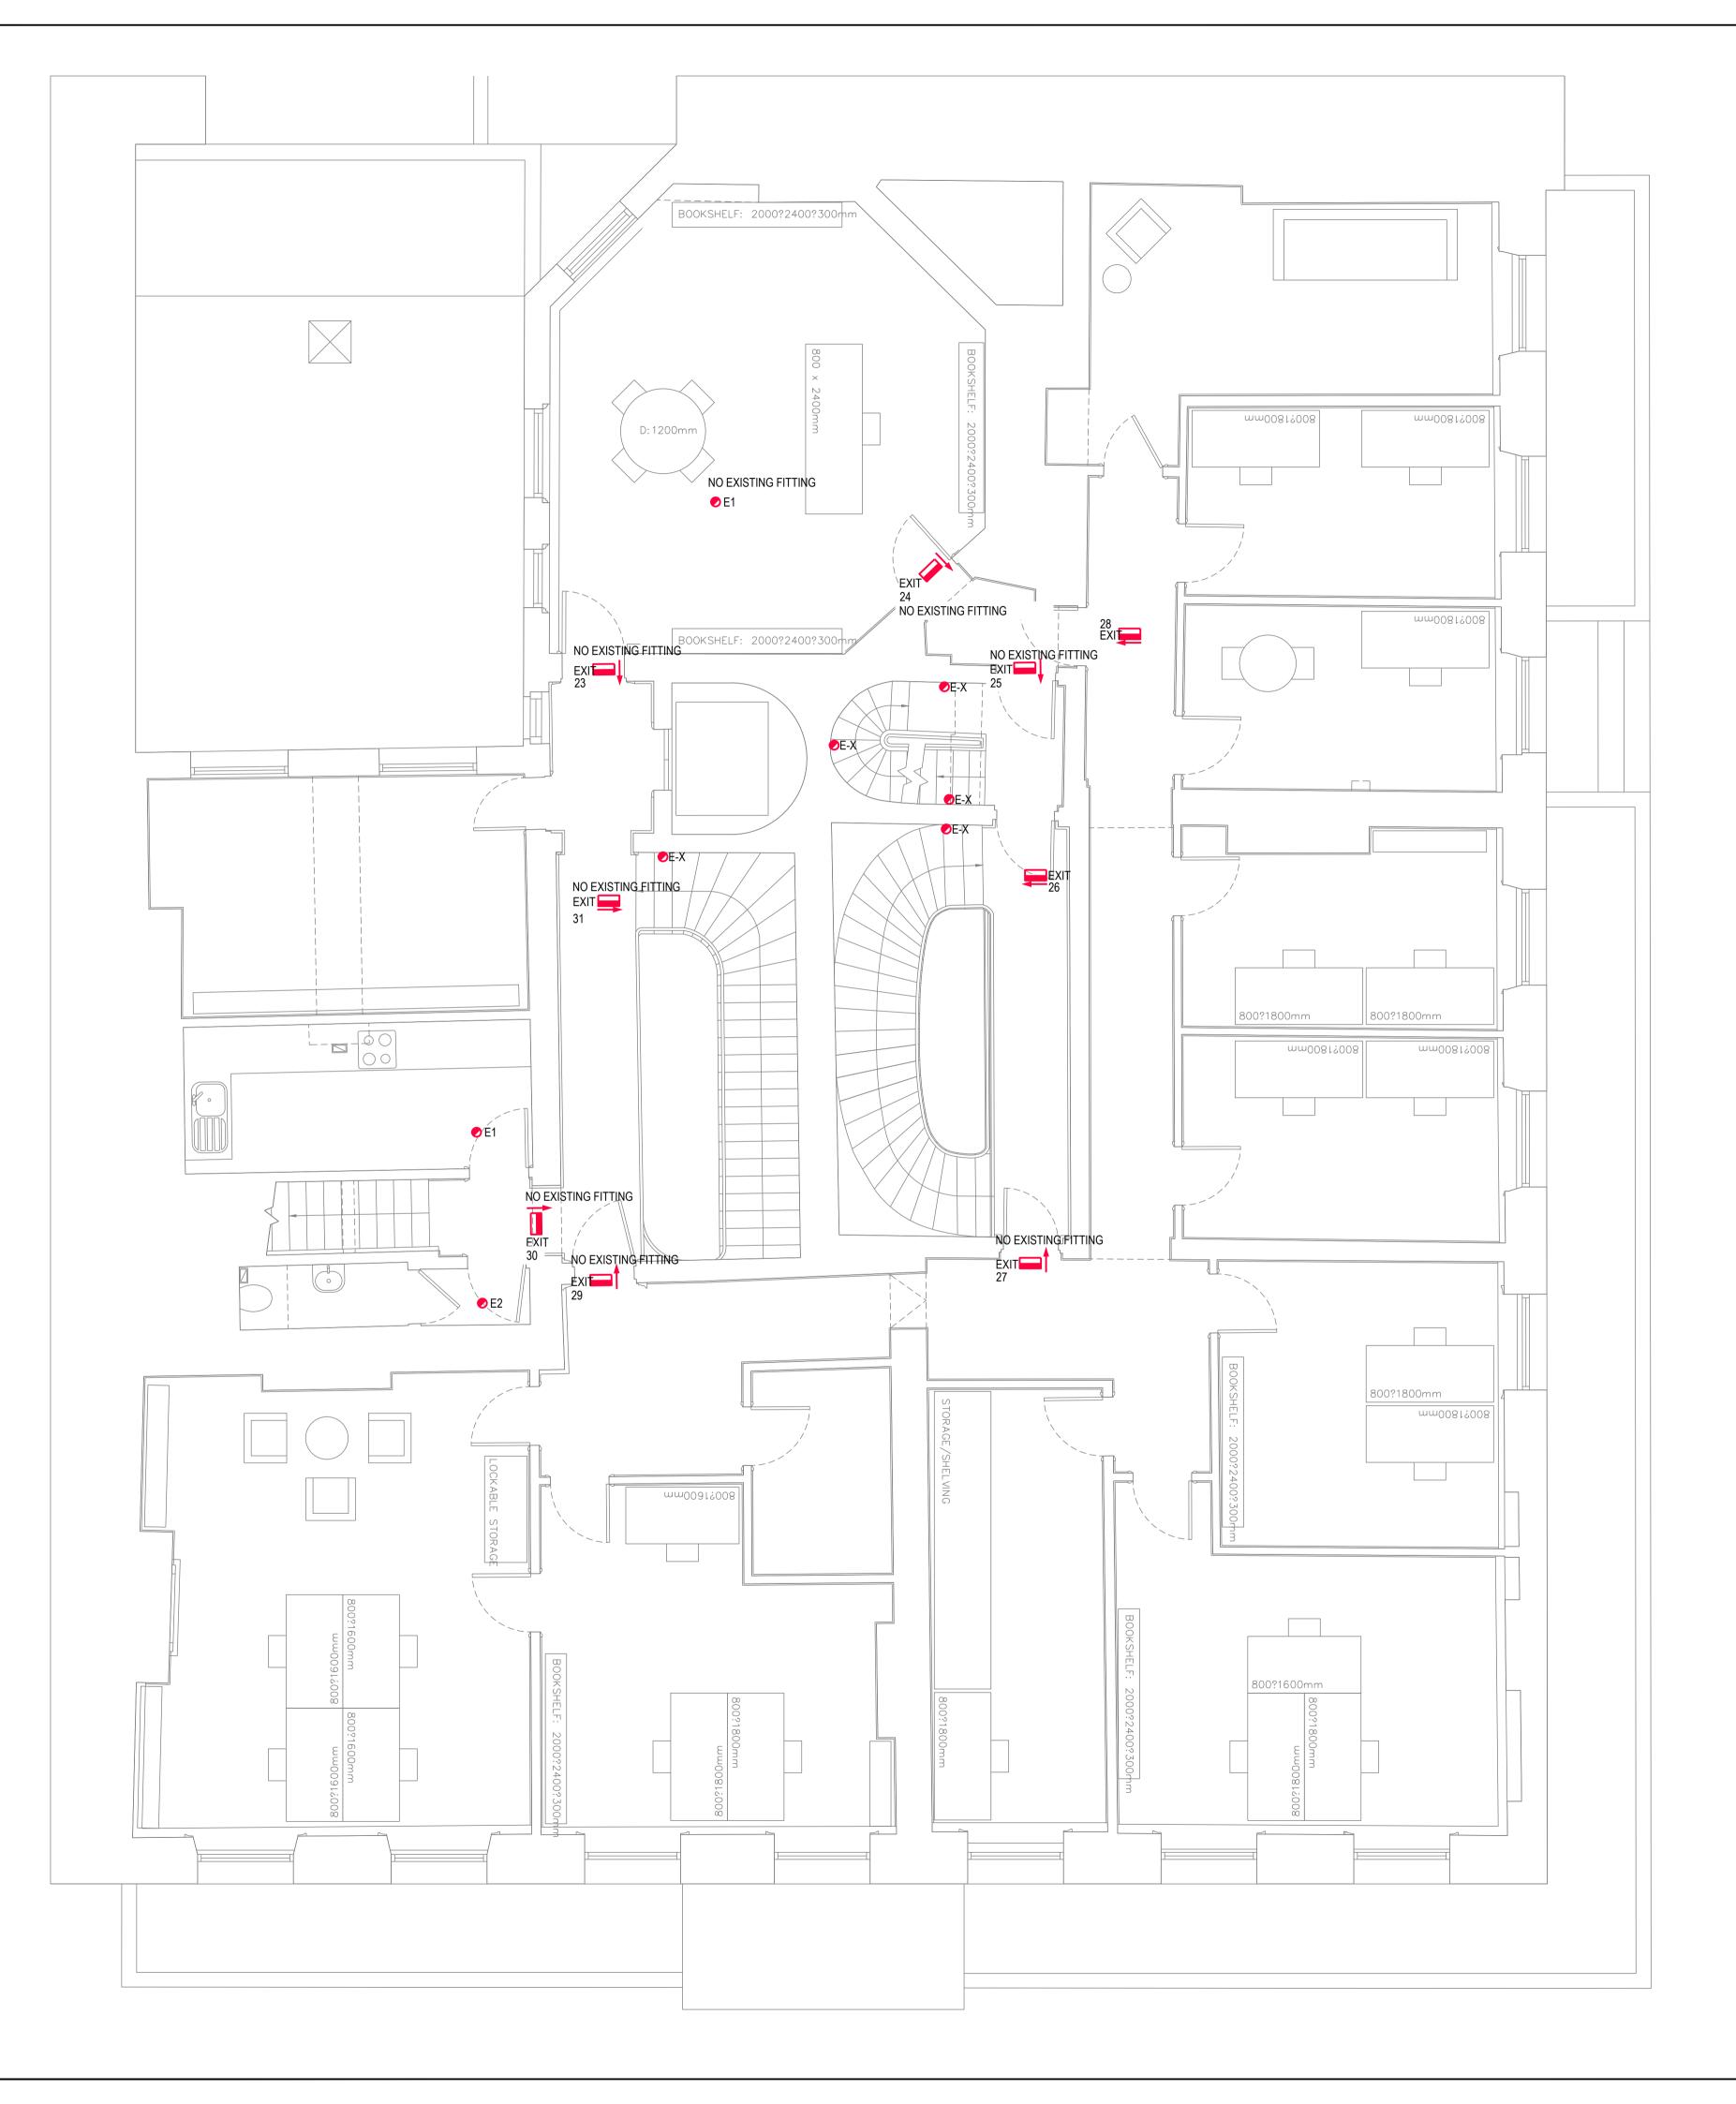


- 1. DO NOT SCALE FROM THIS DRAWING. ALL DIMENSIONS INDICATED ARE IN MILLIMETRES
- DRAWING TO BE READ IN CONJUNCTION WITH SPECIFICATION, DOCUMENTATION, DRAWINGS & ALL RELEVANT BRITISH STANDARD DOCUMENTS
- 3. ALL ELECTRICAL WORKS SHALL COMPLY WITH 18TH EDITION IEE WIRING REGS BS7671:2018+A2:2022, INCLUDING ALL CURRENT AMENDMENTS AND GUIDANCE NOTES AND THE CURRENT BUILDING STANDARDS REGULATIONS
- 4. THE INSTALLATION SHALL ONLY BE CERTIFIED BY A PERSON OR A COMPANY HAVING MEMBERSHIP TO S.E.L.E.C.T. OR N.I.C.E.I.C. OR SIMILAR ELECTRICAL SCHEMES
- 5. FINAL LOCATIONS OF ALL VISIBLE ELECTRICAL EQUIPMENT TO BE COORDINATED WITH ARCHITECT

LEGEND

🕑 E2	EMERGENCY ESCAPE RECESSED LIGHTING
	ZUMTOBEL RESCILITE PRO MRCR RSC E3DG5 WH 42936332
🕑 E1	EMERGENCY ANTI PANIC RECESSED EMERGENCY LIGHT
	ZUMTOBEL RESCLITE PRO MRCR ANT E3DG5 WH 42934755
e E3	EMERGENCY ESCAPE SURFACE MOUNTED LIGHTING
	PHILIP PAYNE LANTIS BULKHEAD L300
e E4	EMERGENCY WALL MOUNTED LIGHTING
	IGUIZINNI MOTUS ANTIPANIC QY39 LIGHT FITTING.
EXIT	WALL MOUNTED EXIT LIGHTS
	VIABIZZUNO MERCATO 230 GRUPPO 101 FITTING
●E-X	EMERGENCY LIGHTING TO BE PROVIDE AS A MINIMUM AT THIS POSITION INTEGRATED INTO THE ARCHITECTURAL LIGHTING DESIGNERS FITTING. REFER TO LIGHTING DESIGNERS PACKAGE FOR FURTHER INFORMATION.

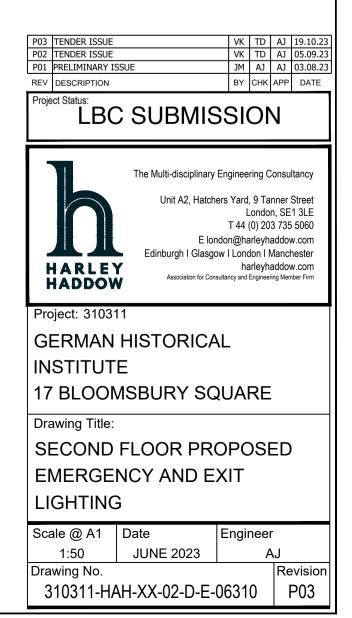


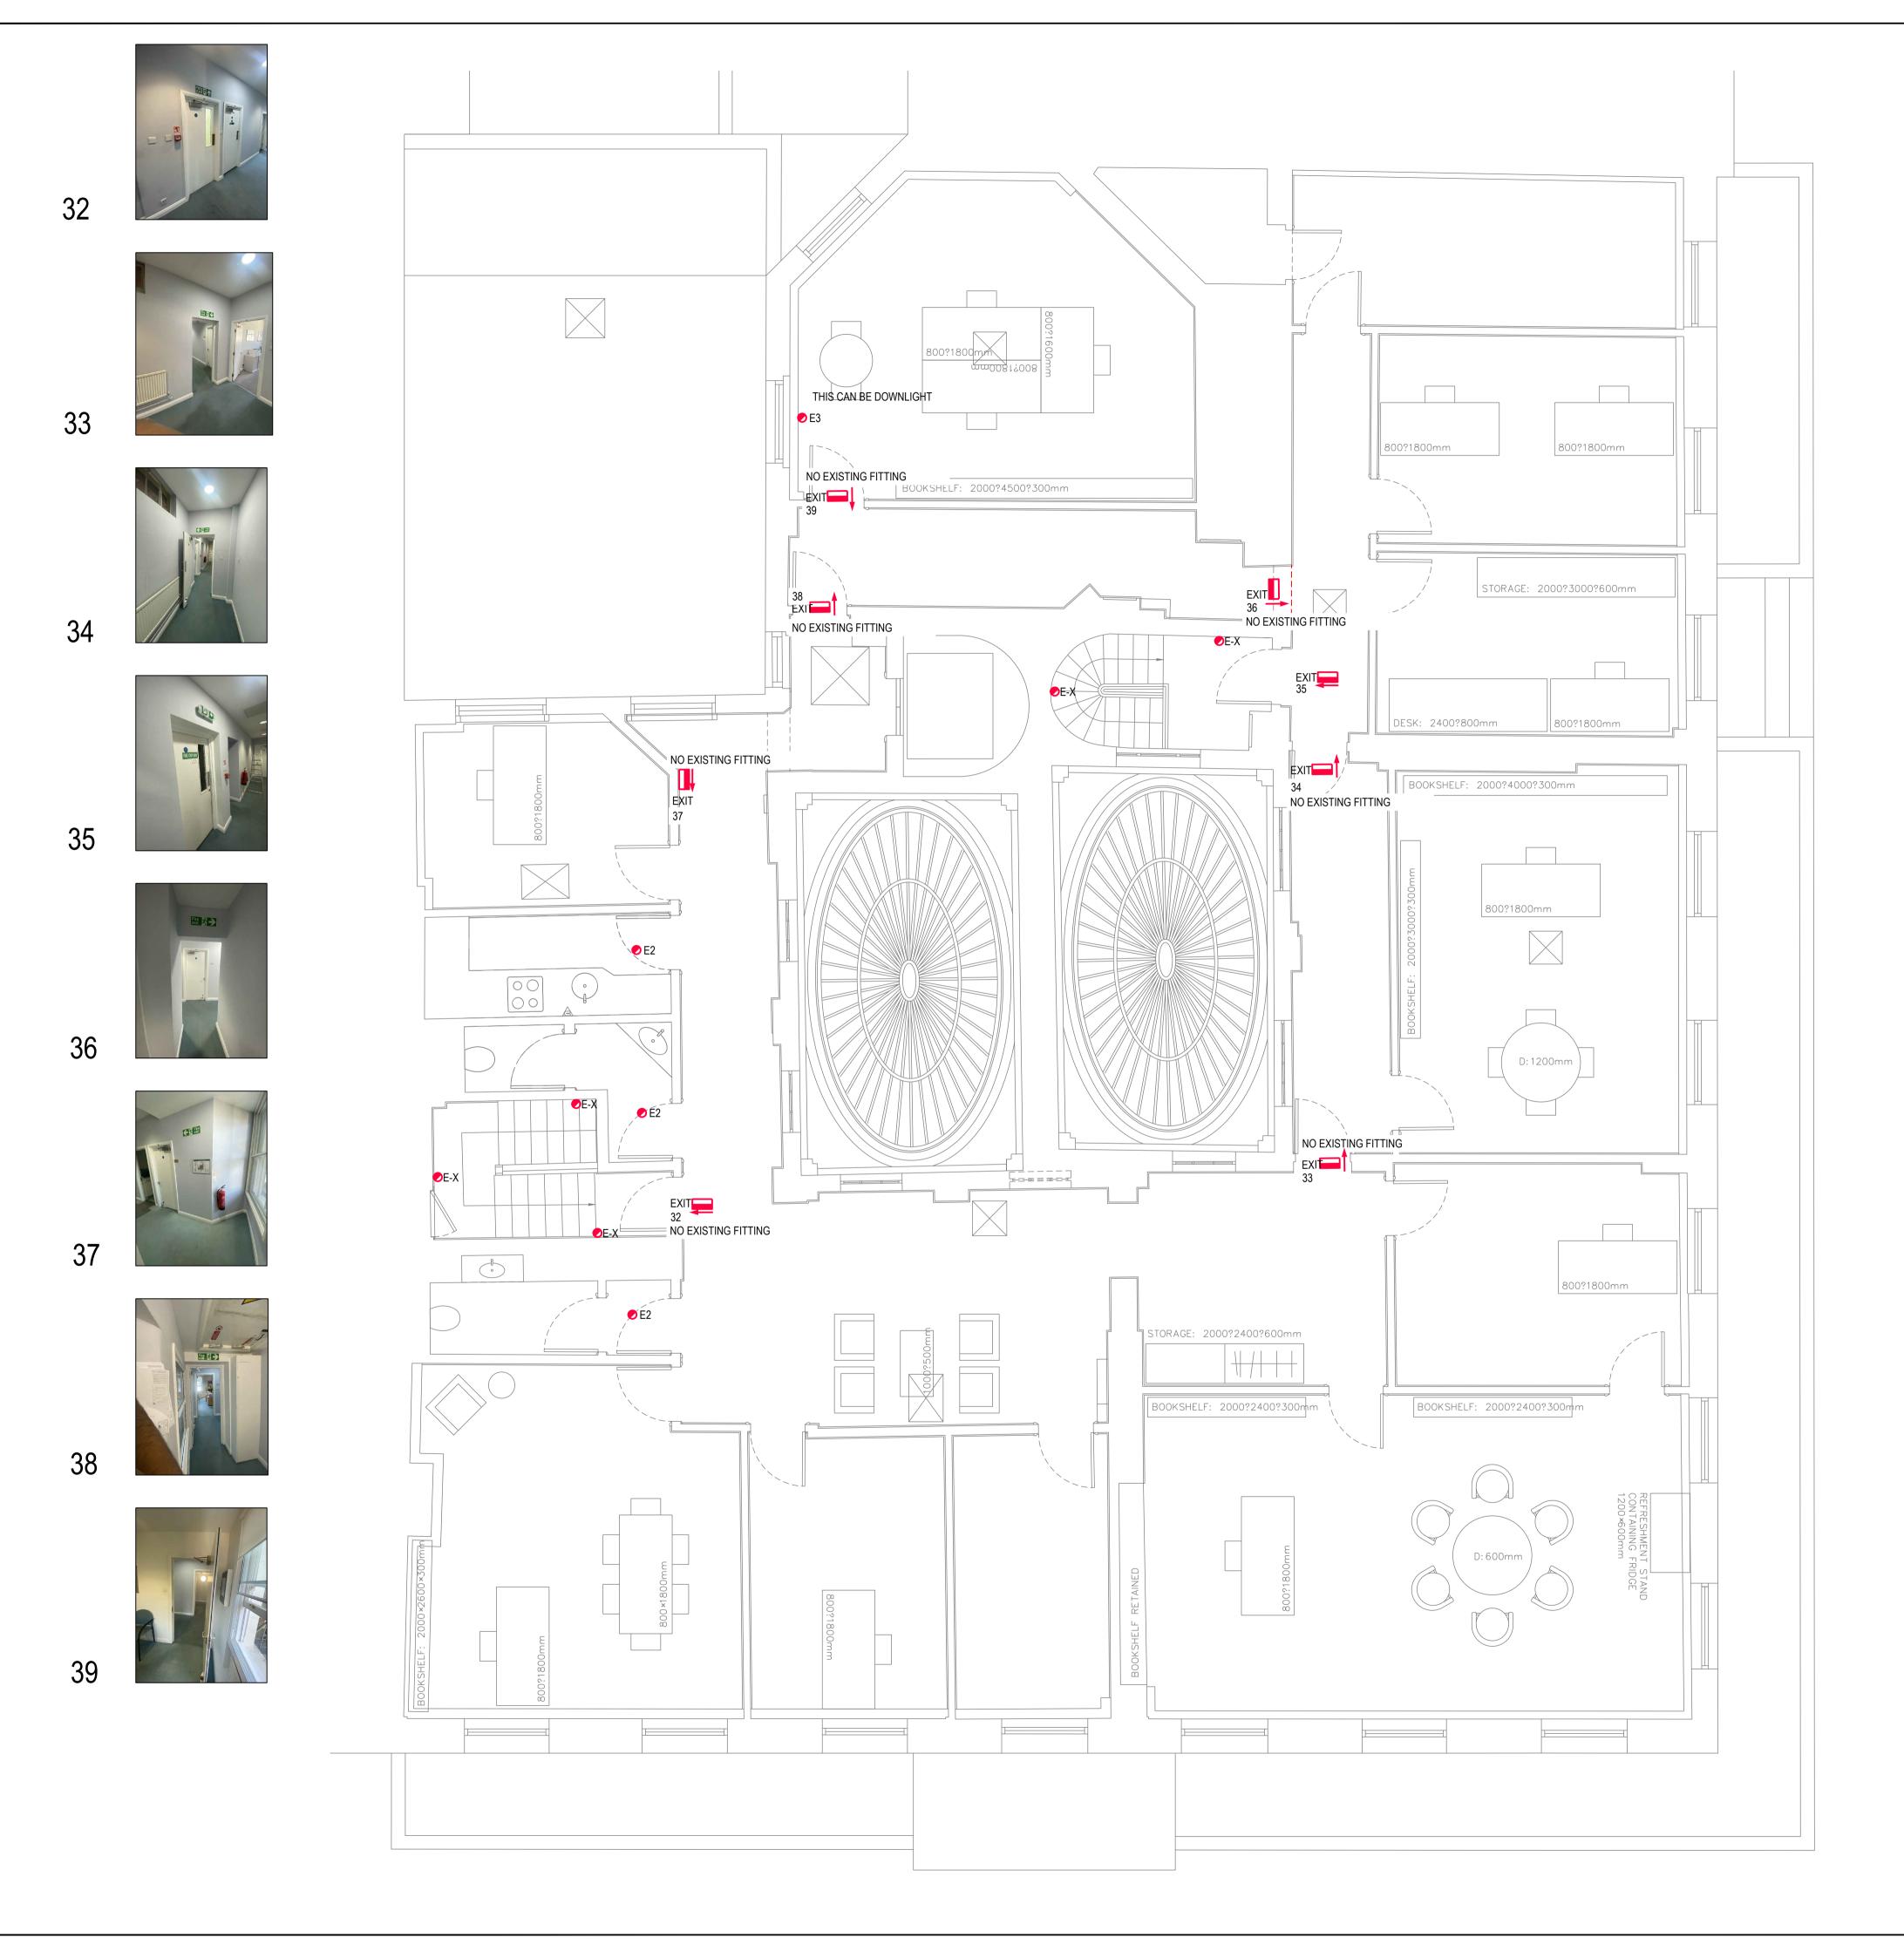


- 1. DO NOT SCALE FROM THIS DRAWING. ALL DIMENSIONS INDICATED ARE IN MILLIMETRES
- DRAWING TO BE READ IN CONJUNCTION WITH SPECIFICATION, DOCUMENTATION, DRAWINGS & ALL RELEVANT BRITISH STANDARD DOCUMENTS
- ALL ELECTRICAL WORKS SHALL COMPLY WITH 18TH EDITION IEE WIRING REGS BS7671:2018+A2:2022, INCLUDING ALL CURRENT AMENDMENTS AND GUIDANCE NOTES AND THE CURRENT BUILDING STANDARDS REGULATIONS
- 4. THE INSTALLATION SHALL ONLY BE CERTIFIED BY A PERSON OR A COMPANY HAVING MEMBERSHIP TO S.E.L.E.C.T. OR N.I.C.E.I.C. OR SIMILAR ELECTRICAL SCHEMES
- 5. FINAL LOCATIONS OF ALL VISIBLE ELECTRICAL EQUIPMENT TO BE COORDINATED WITH ARCHITECT

LEGEND

e E2	EMERGENCY ESCAPE RECESSED LIGHTING
	ZUMTOBEL RESCILITE PRO MRCR RSC E3DG5 WH 42936332
🕑 E1	EMERGENCY ANTI PANIC RECESSED EMERGENCY LIGHT
	ZUMTOBEL RESCLITE PRO MRCR ANT E3DG5 WH 42934755
e E3	EMERGENCY ESCAPE SURFACE MOUNTED LIGHTING
	PHILIP PAYNE LANTIS BULKHEAD L300
e E4	EMERGENCY WALL MOUNTED LIGHTING
	GUIZINNI MOTUS ANTIPANIC QY39 LIGHT FITTING.
EXIT	WALL MOUNTED EXIT LIGHTS
	VIABIZZUNO MERCATO 230 GRUPPO 101 FITTING
€E-X	EMERGENCY LIGHTING TO BE PROVIDE AS A MINIMUM AT

 

r					
P03 TENDER ISSUE P02 TENDER ISSUE		VK VK	TD TD	AJ AJ	19.10.23 05.09.23
P01 PRELIMINARY IS	SSUE	JM	AJ	AJ	03.09.23
REV DESCRIPTION		BY	снк	APP	DATE
Project Status: LBC	SUBMIS	SI	٩C	١	
harle HADDOV	Edinburgh I Glasgo	ers Yard L T 44 d don@ha w I Lond ha	, 9 Ta Londo (0) 20 arleyh don I I arleyh	nner n, SE 3 735 addov Vancl addov	Street 1 3LE 5 5060 w.com nester w.com
INSTITUT	HISTORICA		RE		
Drawing Title:					
THIRD FL	OOR PROP	OSE	ΞD		
EMERGE	NCY AND EX	хιт			
LIGHTING	3				
Scale @ A1	Date	Engii	nee	r	
1:50	JUNE 2023		A	٩J	
Drawing No.	I			Re	vision
-	AH-XX-03-D-E-()631	0	I	>03

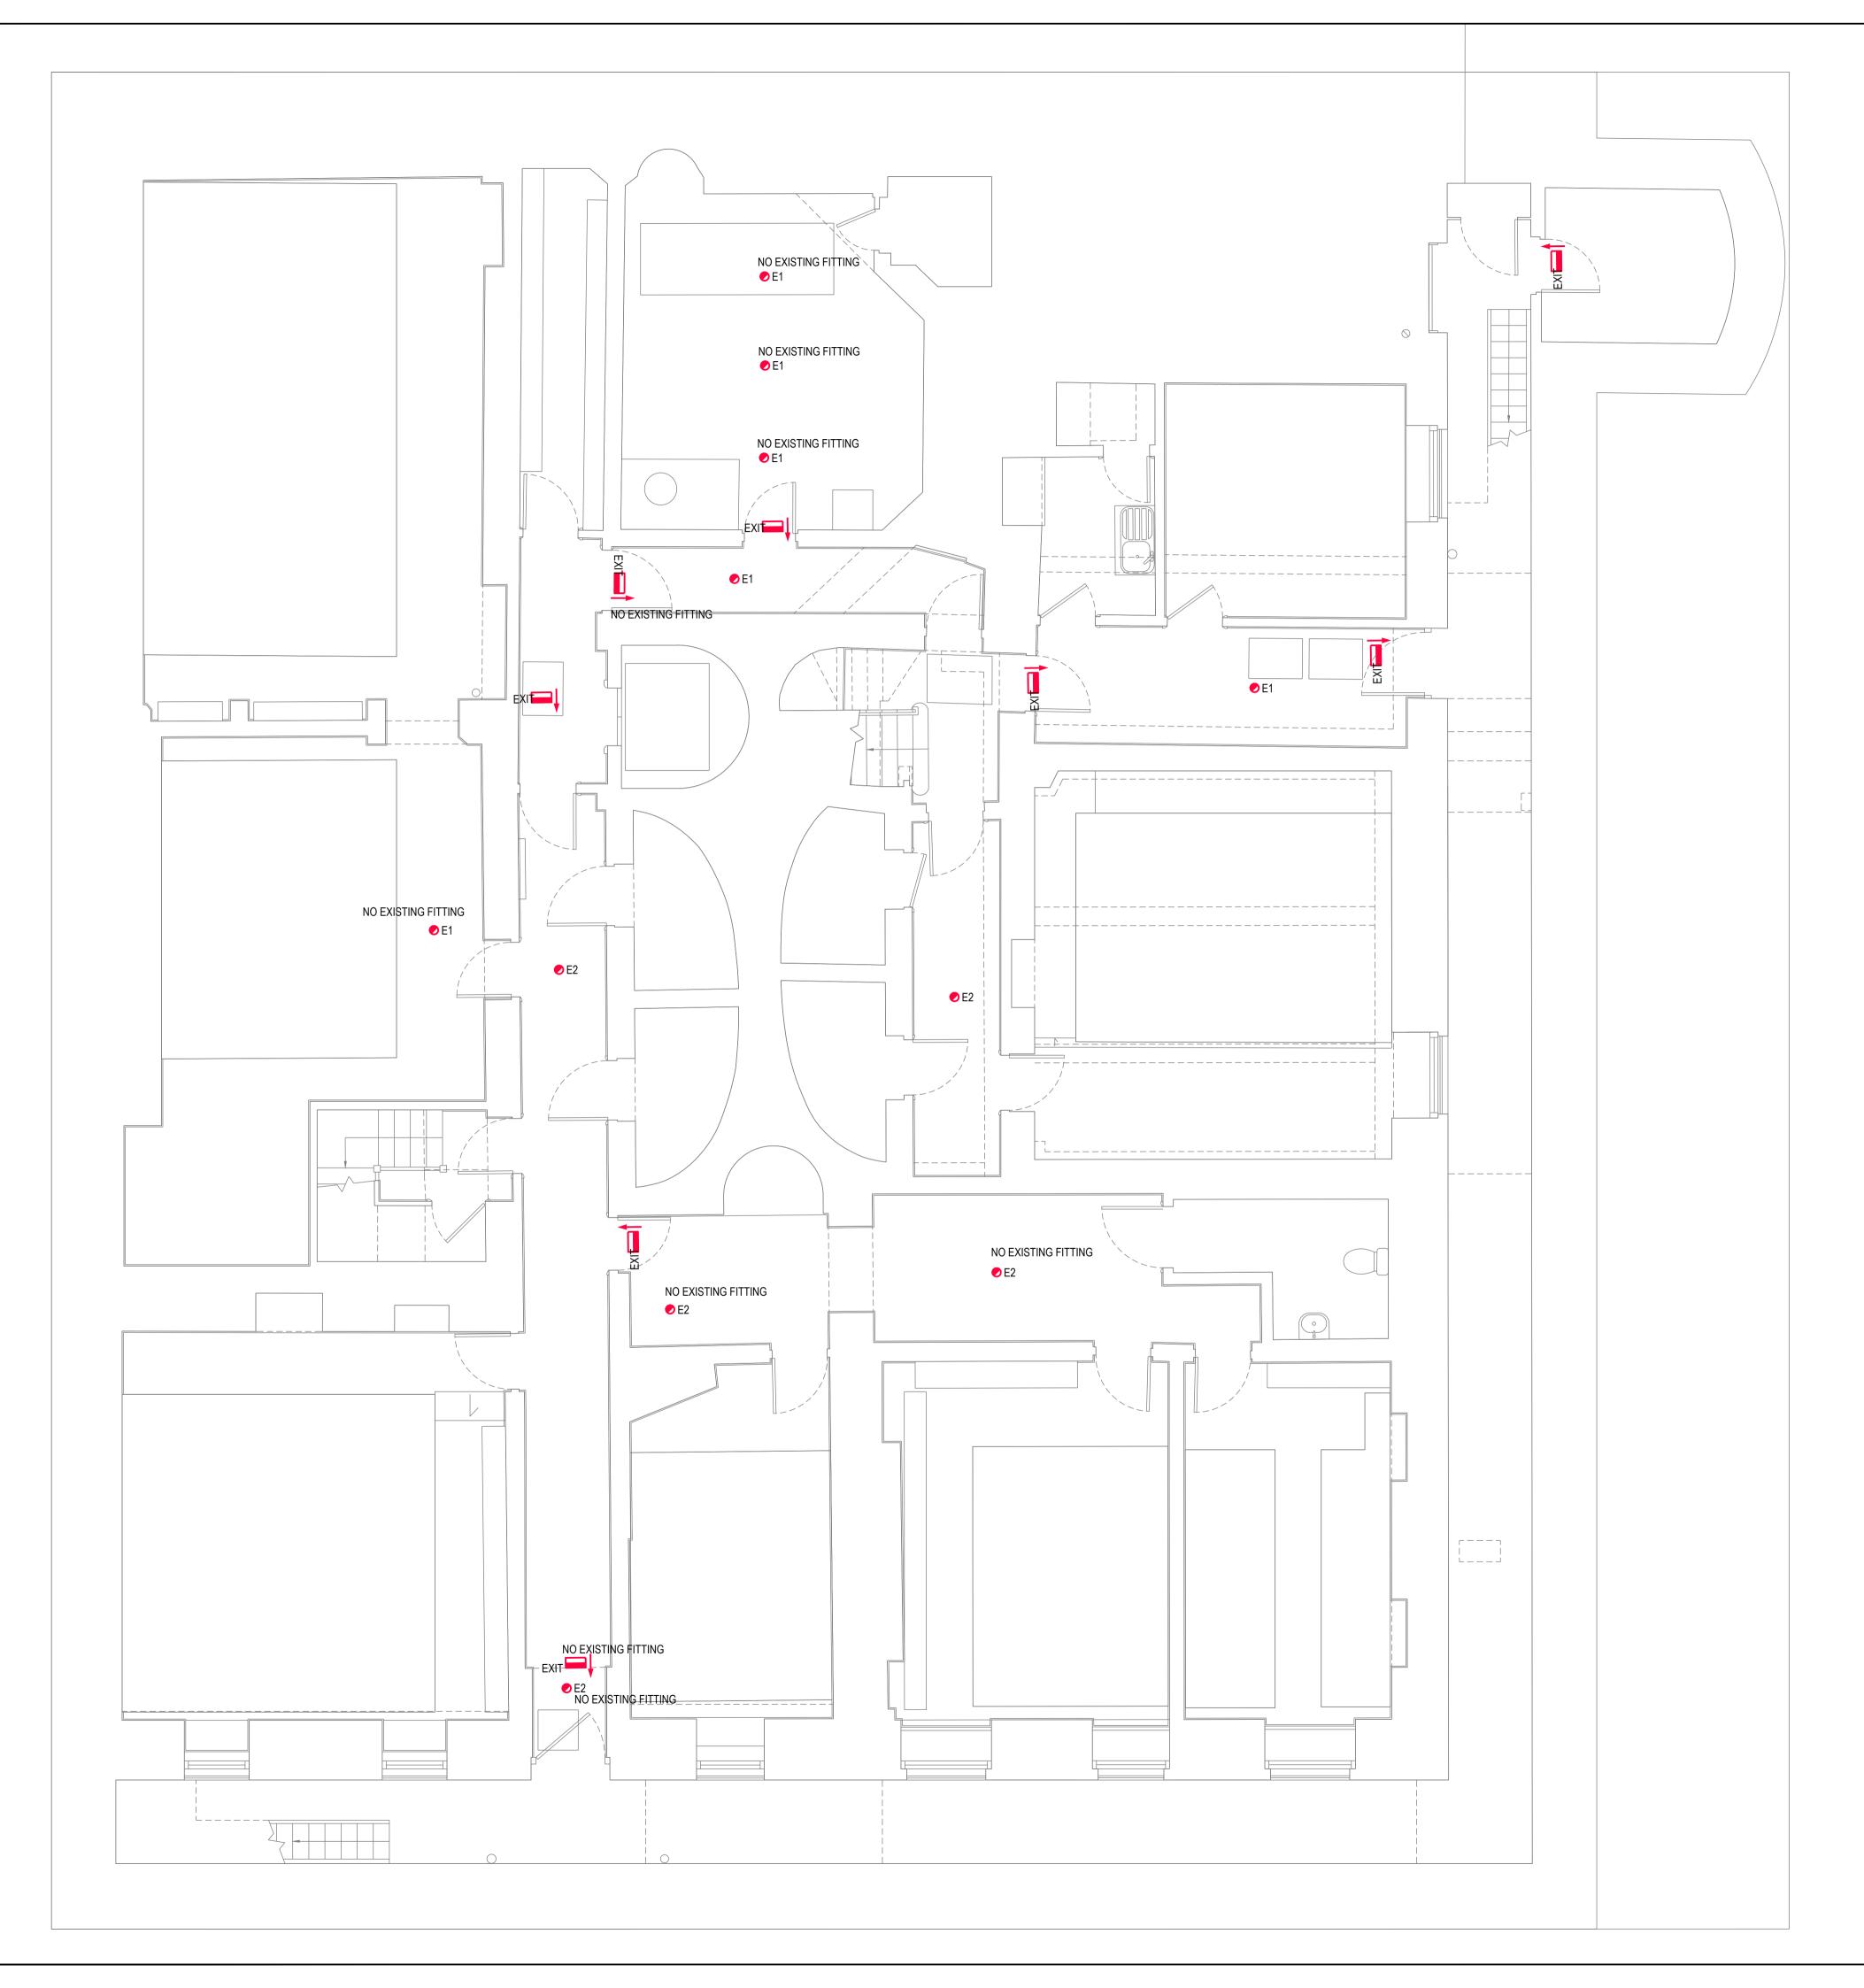

- 1. DO NOT SCALE FROM THIS DRAWING. ALL DIMENSIONS INDICATED ARE IN MILLIMETRES
- DRAWING TO BE READ IN CONJUNCTION WITH SPECIFICATION, DOCUMENTATION, DRAWINGS & ALL RELEVANT BRITISH STANDARD DOCUMENTS
- 3. ALL ELECTRICAL WORKS SHALL COMPLY WITH 18TH EDITION IEE WIRING REGS BS7671:2018+A2:2022, INCLUDING ALL CURRENT AMENDMENTS AND GUIDANCE NOTES AND THE CURRENT BUILDING STANDARDS REGULATIONS
- 4. THE INSTALLATION SHALL ONLY BE CERTIFIED BY A PERSON OR A COMPANY HAVING MEMBERSHIP TO S.E.L.E.C.T. OR N.I.C.E.I.C. OR SIMILAR ELECTRICAL SCHEMES
- 5. FINAL LOCATIONS OF ALL VISIBLE ELECTRICAL EQUIPMENT TO BE COORDINATED WITH ARCHITECT

LEGEND

🥏 E2	EMERGENCY ESCAPE RECESSED LIGHTING
	ZUMTOBEL RESCILITE PRO MRCR RSC E3DG5 WH 42936332
🕑 E1	EMERGENCY ANTI PANIC RECESSED EMERGENCY LIGHT
	ZUMTOBEL RESCLITE PRO MRCR ANT E3DG5 WH 42934755
e E3	EMERGENCY ESCAPE SURFACE MOUNTED LIGHTING
	PHILIP PAYNE LANTIS BULKHEAD L300
> E4	EMERGENCY WALL MOUNTED LIGHTING
	IGUIZINNI MOTUS ANTIPANIC QY39 LIGHT FITTING.
EXIT	WALL MOUNTED EXIT LIGHTS

VIABIZZUNO MERCATO 230 GRUPPO 101 FITTING

P03 TENDER ISSUE	VK	TD	AJ	19.10.23
P02 TENDER ISSUE P01 PRELIMINARY ISSUE	VK JM	TD AJ	AJ AJ	05.09.23
REV DESCRIPTION	BY	СНК	APP	DATE
Project Status:				
	SSI		1	
The Multi-disciplinary	y Enginee	ring C	onsu	Itancy
Unit A2, Hatcl				
			, -	1 3LE 5 5060
	ndon@ha	arleyh	addov	w.com
Edinburgh I Glasg				hester w.com
HARLEY HADDOW Association for Co				
Project: 310311				
Project: 310311 GERMAN HISTORICA	4L			
GERMAN HISTORIC	۹L			
GERMAN HISTORICA				
GERMAN HISTORIC		RE		
GERMAN HISTORICA INSTITUTE 17 BLOOMSBURY SC		RE		
GERMAN HISTORICA INSTITUTE 17 BLOOMSBURY SC Drawing Title:	QUA			
GERMAN HISTORICA INSTITUTE 17 BLOOMSBURY SC	QUA			ED
GERMAN HISTORICA INSTITUTE 17 BLOOMSBURY SC Drawing Title:				ED
GERMAN HISTORICA INSTITUTE 17 BLOOMSBURY SC Drawing Title: BASEMENT FLOOR EMERGENCY AND E				ED
GERMAN HISTORICA INSTITUTE 17 BLOOMSBURY SC Drawing Title: BASEMENT FLOOR				ED
GERMAN HISTORICA INSTITUTE 17 BLOOMSBURY SC Drawing Title: BASEMENT FLOOR EMERGENCY AND E		PC	DS	ED
GERMAN HISTORICA INSTITUTE 17 BLOOMSBURY SC Drawing Title: BASEMENT FLOOR EMERGENCY AND E LIGHTING	QUA PRO	PC	DS	ED
GERMAN HISTORICA INSTITUTE 17 BLOOMSBURY SC Drawing Title: BASEMENT FLOOR EMERGENCY AND E LIGHTING Scale @ A1 Date	QUA PRO	PC	DS T	ED