X	Surface mounted wall lamp
کھ	Surface mounted Emergency wall lamp
ĉ	Surface mounted spotlight
EXIT	Surface mounted emergency exit signage
ில்க	Multiple light switch
o	Light switch


Colour Legend



Blue colour indicates new fittings cabled to existing power position, and with no need of new fixing points.



Purple colour indicates new fittings cabled to new power provisions, or to existing power but needing new fixing points.

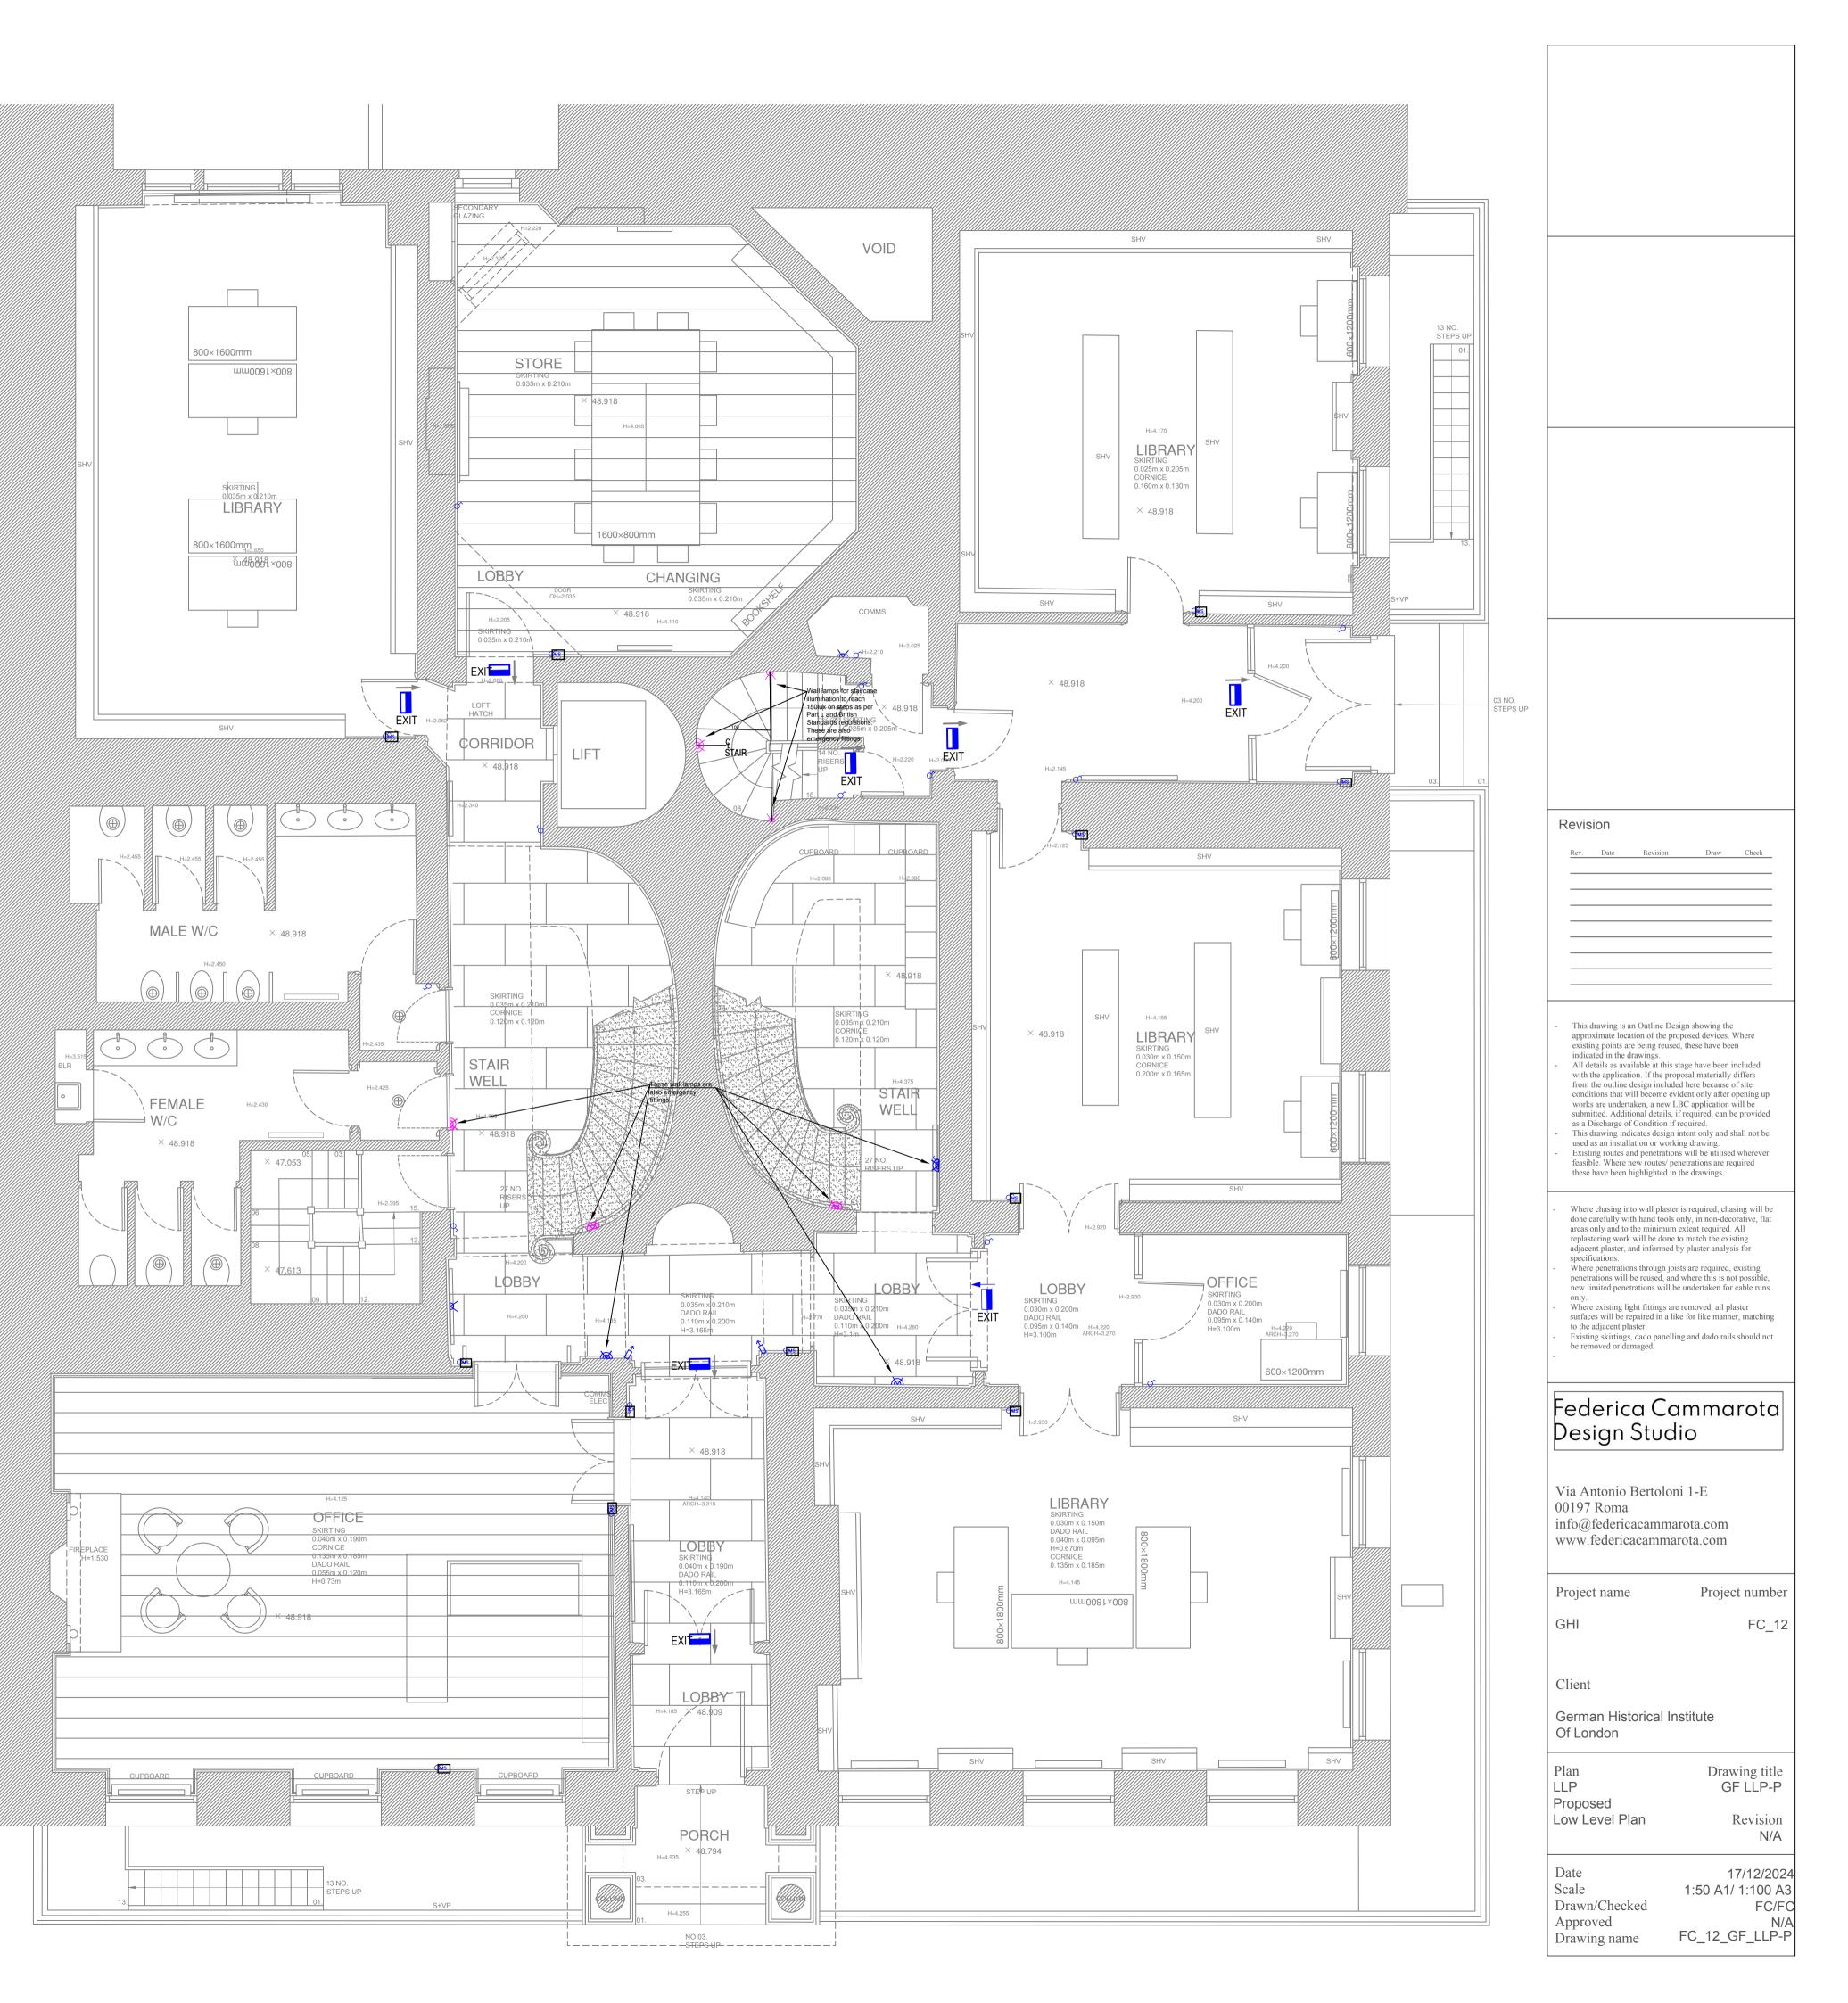

	Surface mounted track light for vertical libraries illumination. High light quality and colour rendering index, light intensity achieving 200lux on vertical surfaces as required by library lighting regulations. Track fixing points installed on timber joists, not on the lath.
	Suspended track light for vertical libraries illumination. High light quality and colour rendering index, light intensity achieving 200lux on vertical surfaces as required by library lighting regulations. Fixed to the ceiling as detail D2-H. Track fixing points installed on timber joists, not on the lath.
	Suspended track light for gallery illumination, with dedicated lights for artwork hanging on the walls. High light quality, high colour rendering index, optics adjustable to art dimension. Also providing door area illumination at entrances, and general lighting in the room as required by reception areas lighting regulations. Track fixing points installed on timber joists, not on the lath.
+	Surface mounted light
\oplus	Pendant light

 
Colour Legend

 



Blue colour indicates new fittings cabled to existing power position, and with no need of new fixing points.

Pink colour indicates new fittings cabled to existing power provisions, but needing new fixing points.

Purple colour indicates new fittings cabled to new power provisions.





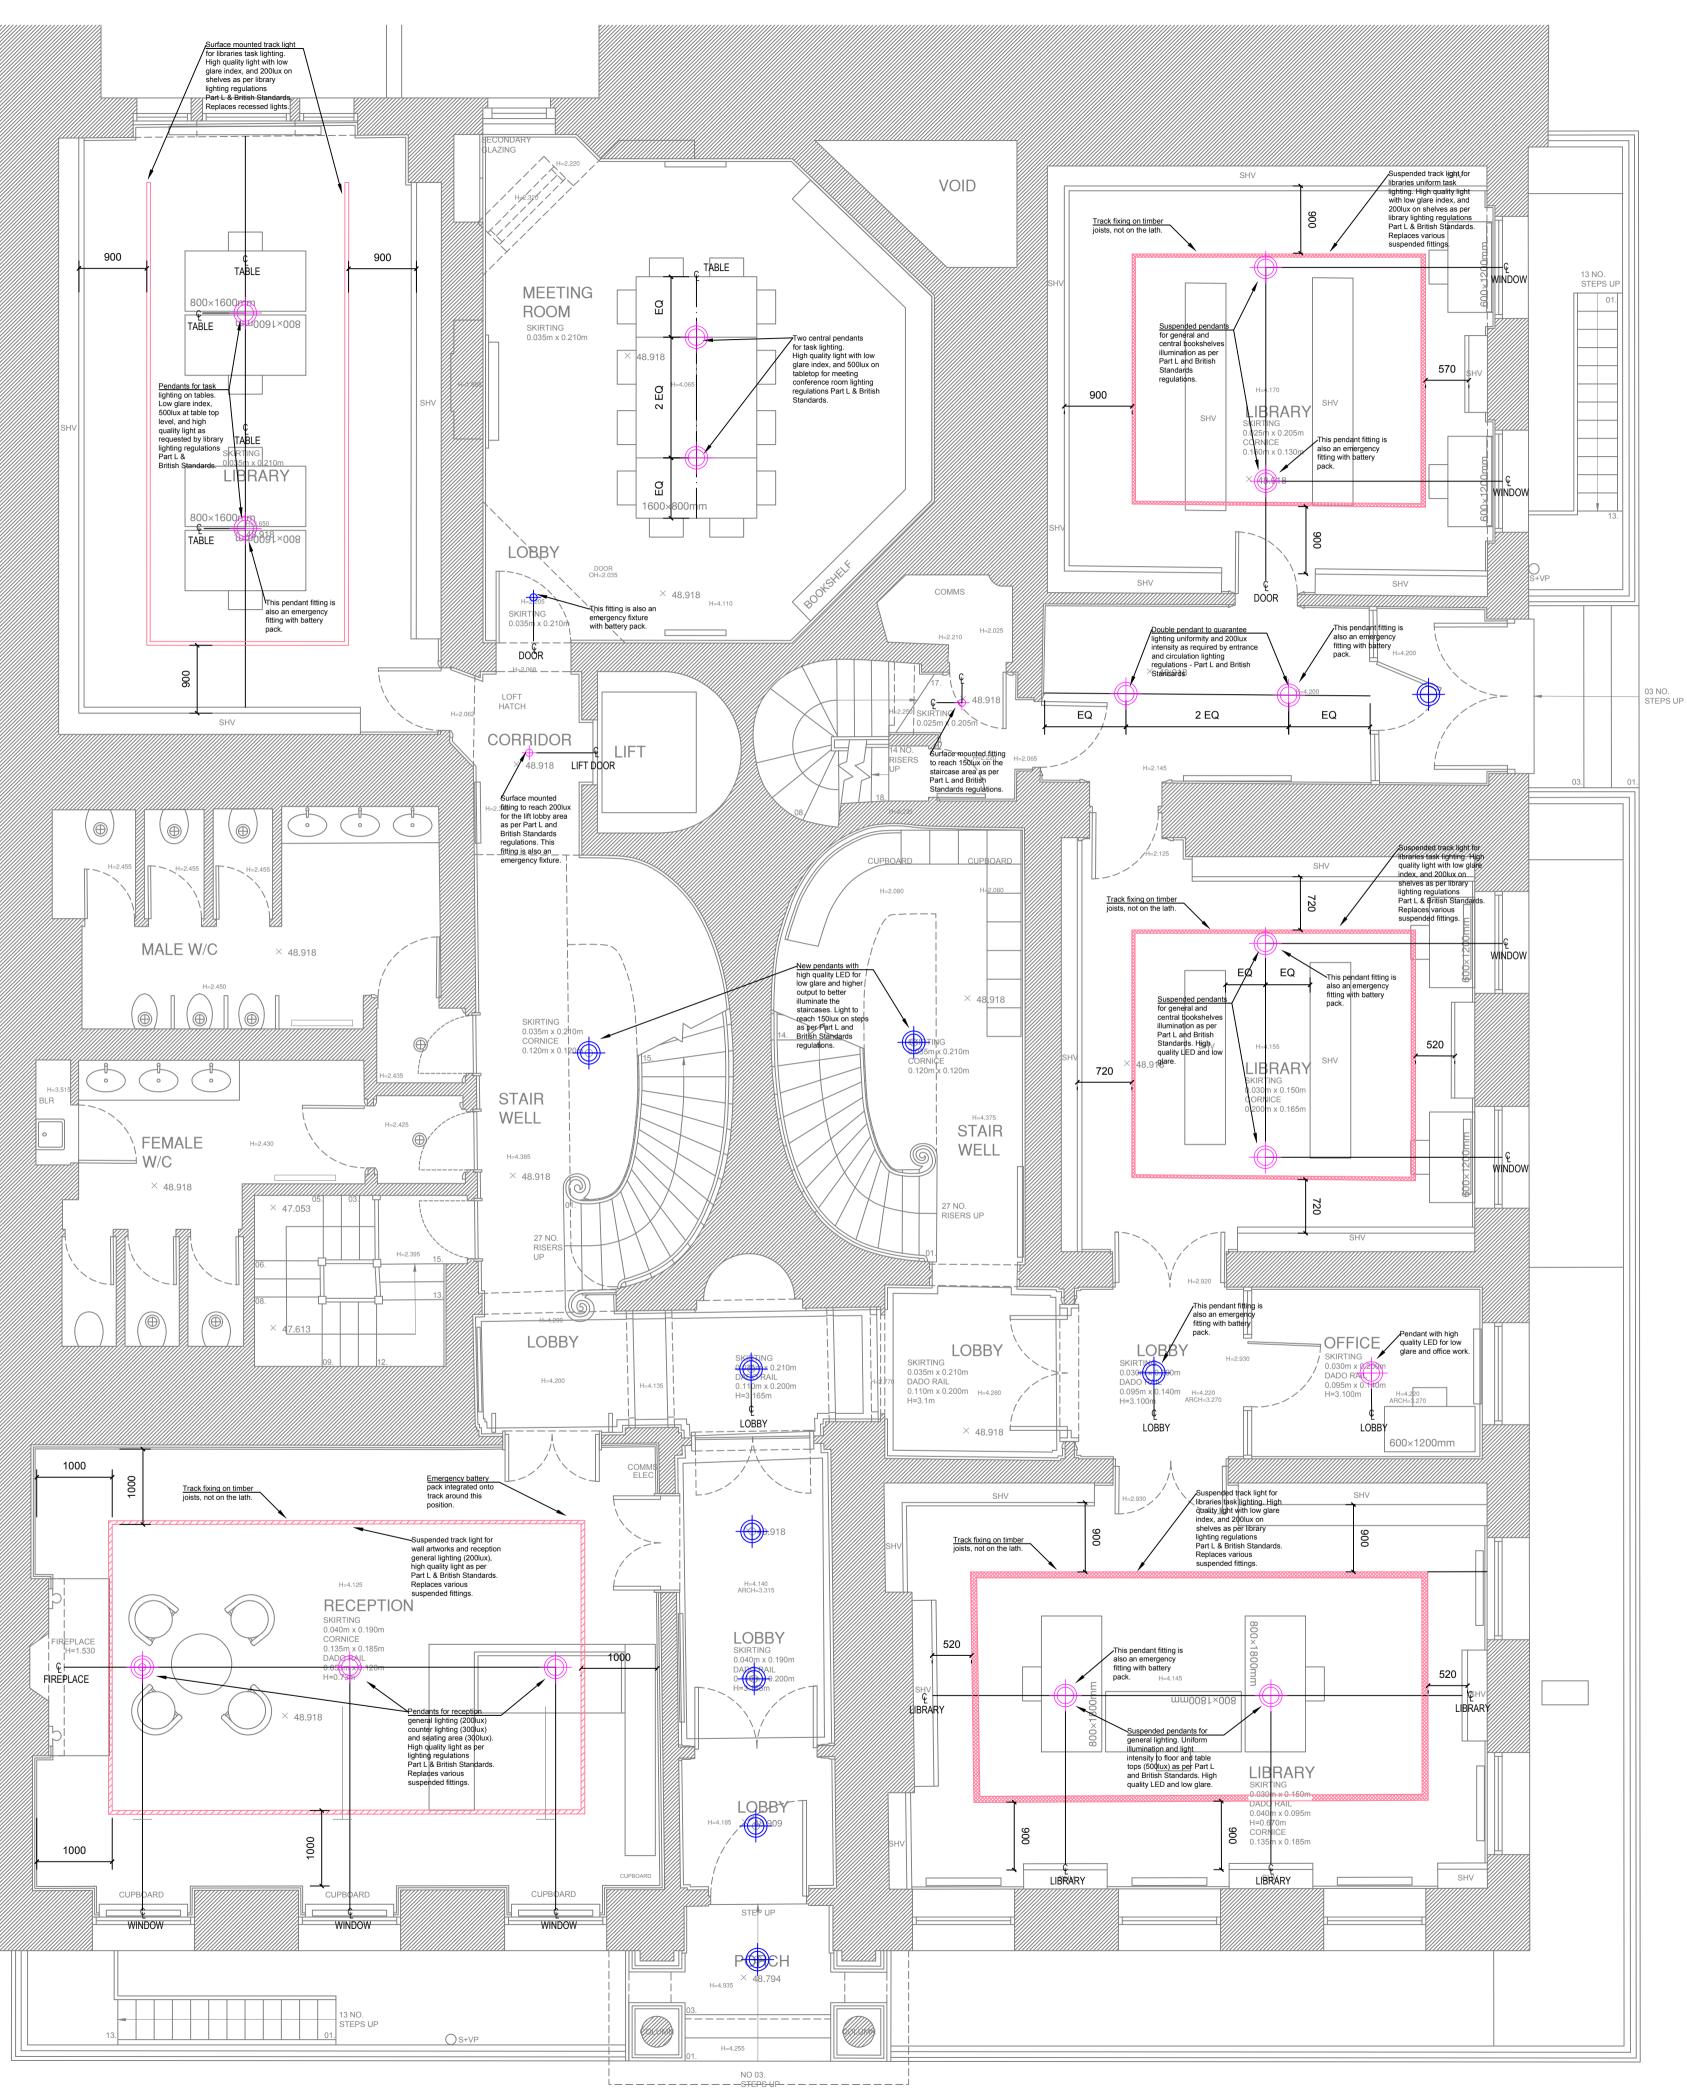

Revision	
Rev. Date Revision Dra	w Check
 approximate location of the proposed deviexisting points are being reused, these have indicated in the drawings. All details as available at this stage have be with the application. If the proposal mater from the outline design included here beec conditions that will become evident only a up works are undertaken, a new LBC apple be submitted. Additional details, if require provided as a Discharge of Condition if re This drawing indicates design intent only be used as an installation or working draw Existing routes and penetrations will be ut wherever feasible. Where new routes/pener required these have been highlighted in the 	re been been included ially differs ause of site after opening lication will ed, can be equired. and shall not ving. ilised terations are
 Where chasing into wall plaster is requir will be done carefully with hand tools or non-decorative, flat areas only and to the extent required. All replastering work wi match the existing adjacent plaster, and i plaster analysis for specifications. Where penetrations through joists are recevisting penetrations will be reused, and not possible, new limited penetrations wurdentaken for cable runs only. Where existing light fittings are removed surfaces will be repaired in a like for like matching to the adjacent plaster. Existing skirtings, dado panelling and da not be removed or damaged. 	lly, in e minimum Il be done to informed by quired, where this is ill be d, all plaster e manner,
Federica Camm	arota
Design Studio	
Via Antonio Bertoloni 1-E 00197 Roma info@federicacammarota.cor	
Via Antonio Bertoloni 1-E 00197 Roma	
Via Antonio Bertoloni 1-E 00197 Roma info@federicacammarota.com www.federicacammarota.com	
Via Antonio Bertoloni 1-E 00197 Roma info@federicacammarota.com www.federicacammarota.com	n
Via Antonio Bertoloni 1-E 00197 Roma info@federicacammarota.con www.federicacammarota.con Project name Proj	n ject number
Via Antonio Bertoloni 1-E 00197 Roma info@federicacammarota.com www.federicacammarota.com Project name Proj GHI	n ject number
Via Antonio Bertoloni 1-E 00197 Roma info@federicacammarota.com www.federicacammarota.com Project name Proj GHI Client German Historical Institute Of London	n ject number FC_12
Via Antonio Bertoloni 1-E 00197 Roma info@federicacammarota.com www.federicacammarota.com Project name Proj GHI Client German Historical Institute Of London Plan Dr	n ject number
Via Antonio Bertoloni 1-E 00197 Roma info@federicacammarota.com www.federicacammarota.com Project name Proj GHI Client German Historical Institute Of London Plan Dr RCP (n ject number FC_12 awing title GF RCP-P
Via Antonio Bertoloni 1-E 00197 Roma info@federicacammarota.com www.federicacammarota.com Project name Proj GHI Client German Historical Institute Of London Plan Dr RCP (Proposed Reflected Ceiling Plan Date	n ject number FC_12 rawing title GF RCP-P Revision

	Surface mounted wall-lamp
<u>کم</u>	Surface mounted Emergency wall-lamp
۲	Recessed uplight. Fitting installed as in detail D3-H
	High quality picture light of different lengths to follow the libraries layout in the room. High level light quality providing a vertical light wash of 4 meters. Light provides 200lux on vertical library plan for library use and work as required by the lighting libraries regulation. Fitting fixed to a rail positioned on top of the libraries as in detail D1-H.
↓ □	Surface mounted spotlight for conference lighting to the speaker Fitting installed as in detail D5-H
EXIT	Surface mounted emergency exit signage

Colour Legend




Blue colour indicates new fittings cabled to existing power position, and with no need of new fixing points.



Purple colour indicates new fittings cabled to new power provisions.




Pink colour indicates new fittings cabled to existing power provisions, but needing new fixing points.

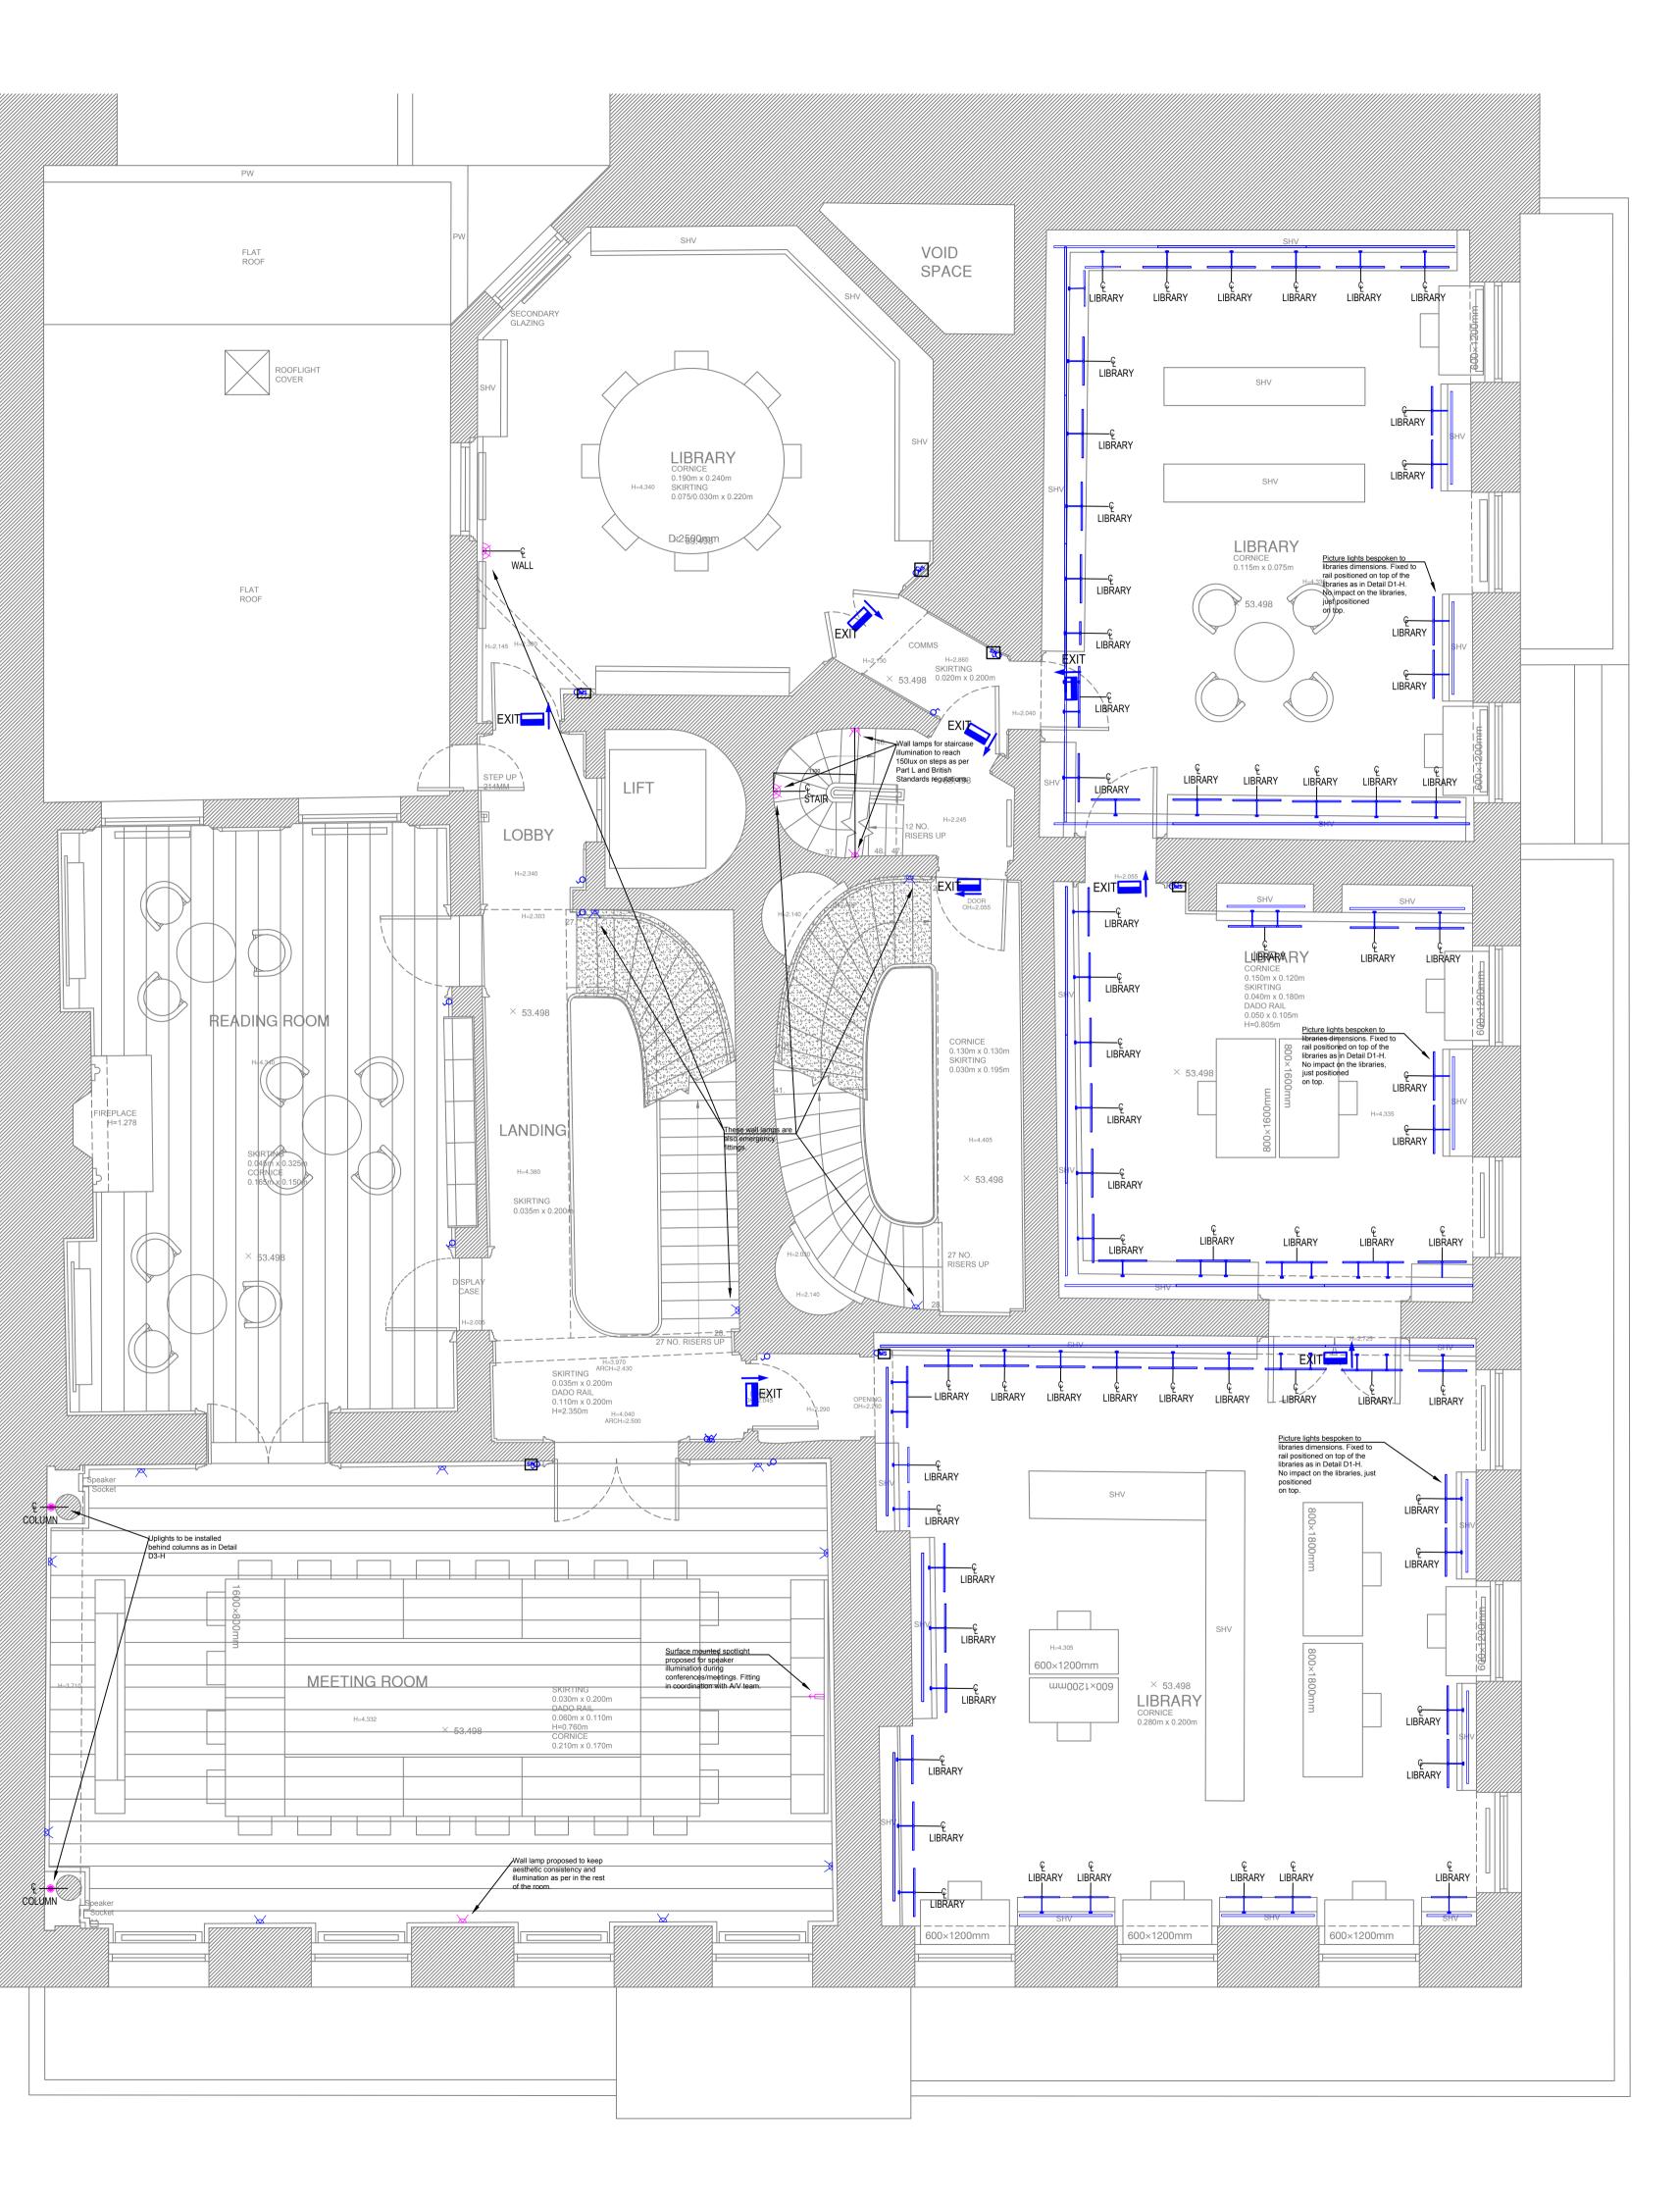

Revision	
Rev. Date Revisio	n Draw Check
with the application. If the from the outline design inc conditions that will becom works are undertaken, a ne submitted. Additional deta as a Discharge of Conditio - This drawing indicates des used as an installation or w	e proposed devices. Where eused, these have been his stage have been included proposal materially differs luded here because of site e evident only after opening up w LBC application will be ils, if required, can be provided n i frequired. ign intent only and shall not be vorking drawing. tions will be utilised wherever s/ penetrations are required
 done carefully with hand to areas only and to the minim replastering work will be duadjacent plaster, and inform specifications. Where penetrations through penetrations will be reused, new limited penetrations wonly. Where existing light fitting surfaces will be repaired in to the adjacent plaster. 	one to match the existing ned by plaster analysis for n joists are required, existing and where this is not possible, ill be undertaken for cable runs
Federica C Design Stu	Cammarota Idio
Via Antonio Bertol 00197 Roma info@federicacami www.federicacamr	narota.com
Project name GHI	Project number FC_12
Client	
German Historical Of London	Institute
Plan	Drawing title
LLP Proposed Low Level Plan	1F LLP-P Revision
Date	N/A 17/12/2024
Scale Drawn/Checked	1:50 A1/ 1:100 A3 NM/FC
Approved Drawing name	N/A FC_12_1F_LLP-P

000000000000000000000000000000000000000	Suspended track light for vertical libraries illumination. High light quality and colour rendering index, light intensity achieving 200lux on vertical surfaces as required by library lighting regulations. Fixed to the ceiling as detail D2-H
.	Surface mounted light
-	Pendant light. Some of these on the plan are also Emergency fittings.

 Colour Legend




Blue colour indicates new fittings cabled to existing power position, and with no need of new fixing points.

Purple colour indicates new fittings cabled to new power provisions.

Pink colour indicates new fittings cabled to existing power provisions, but needing new fixing points.



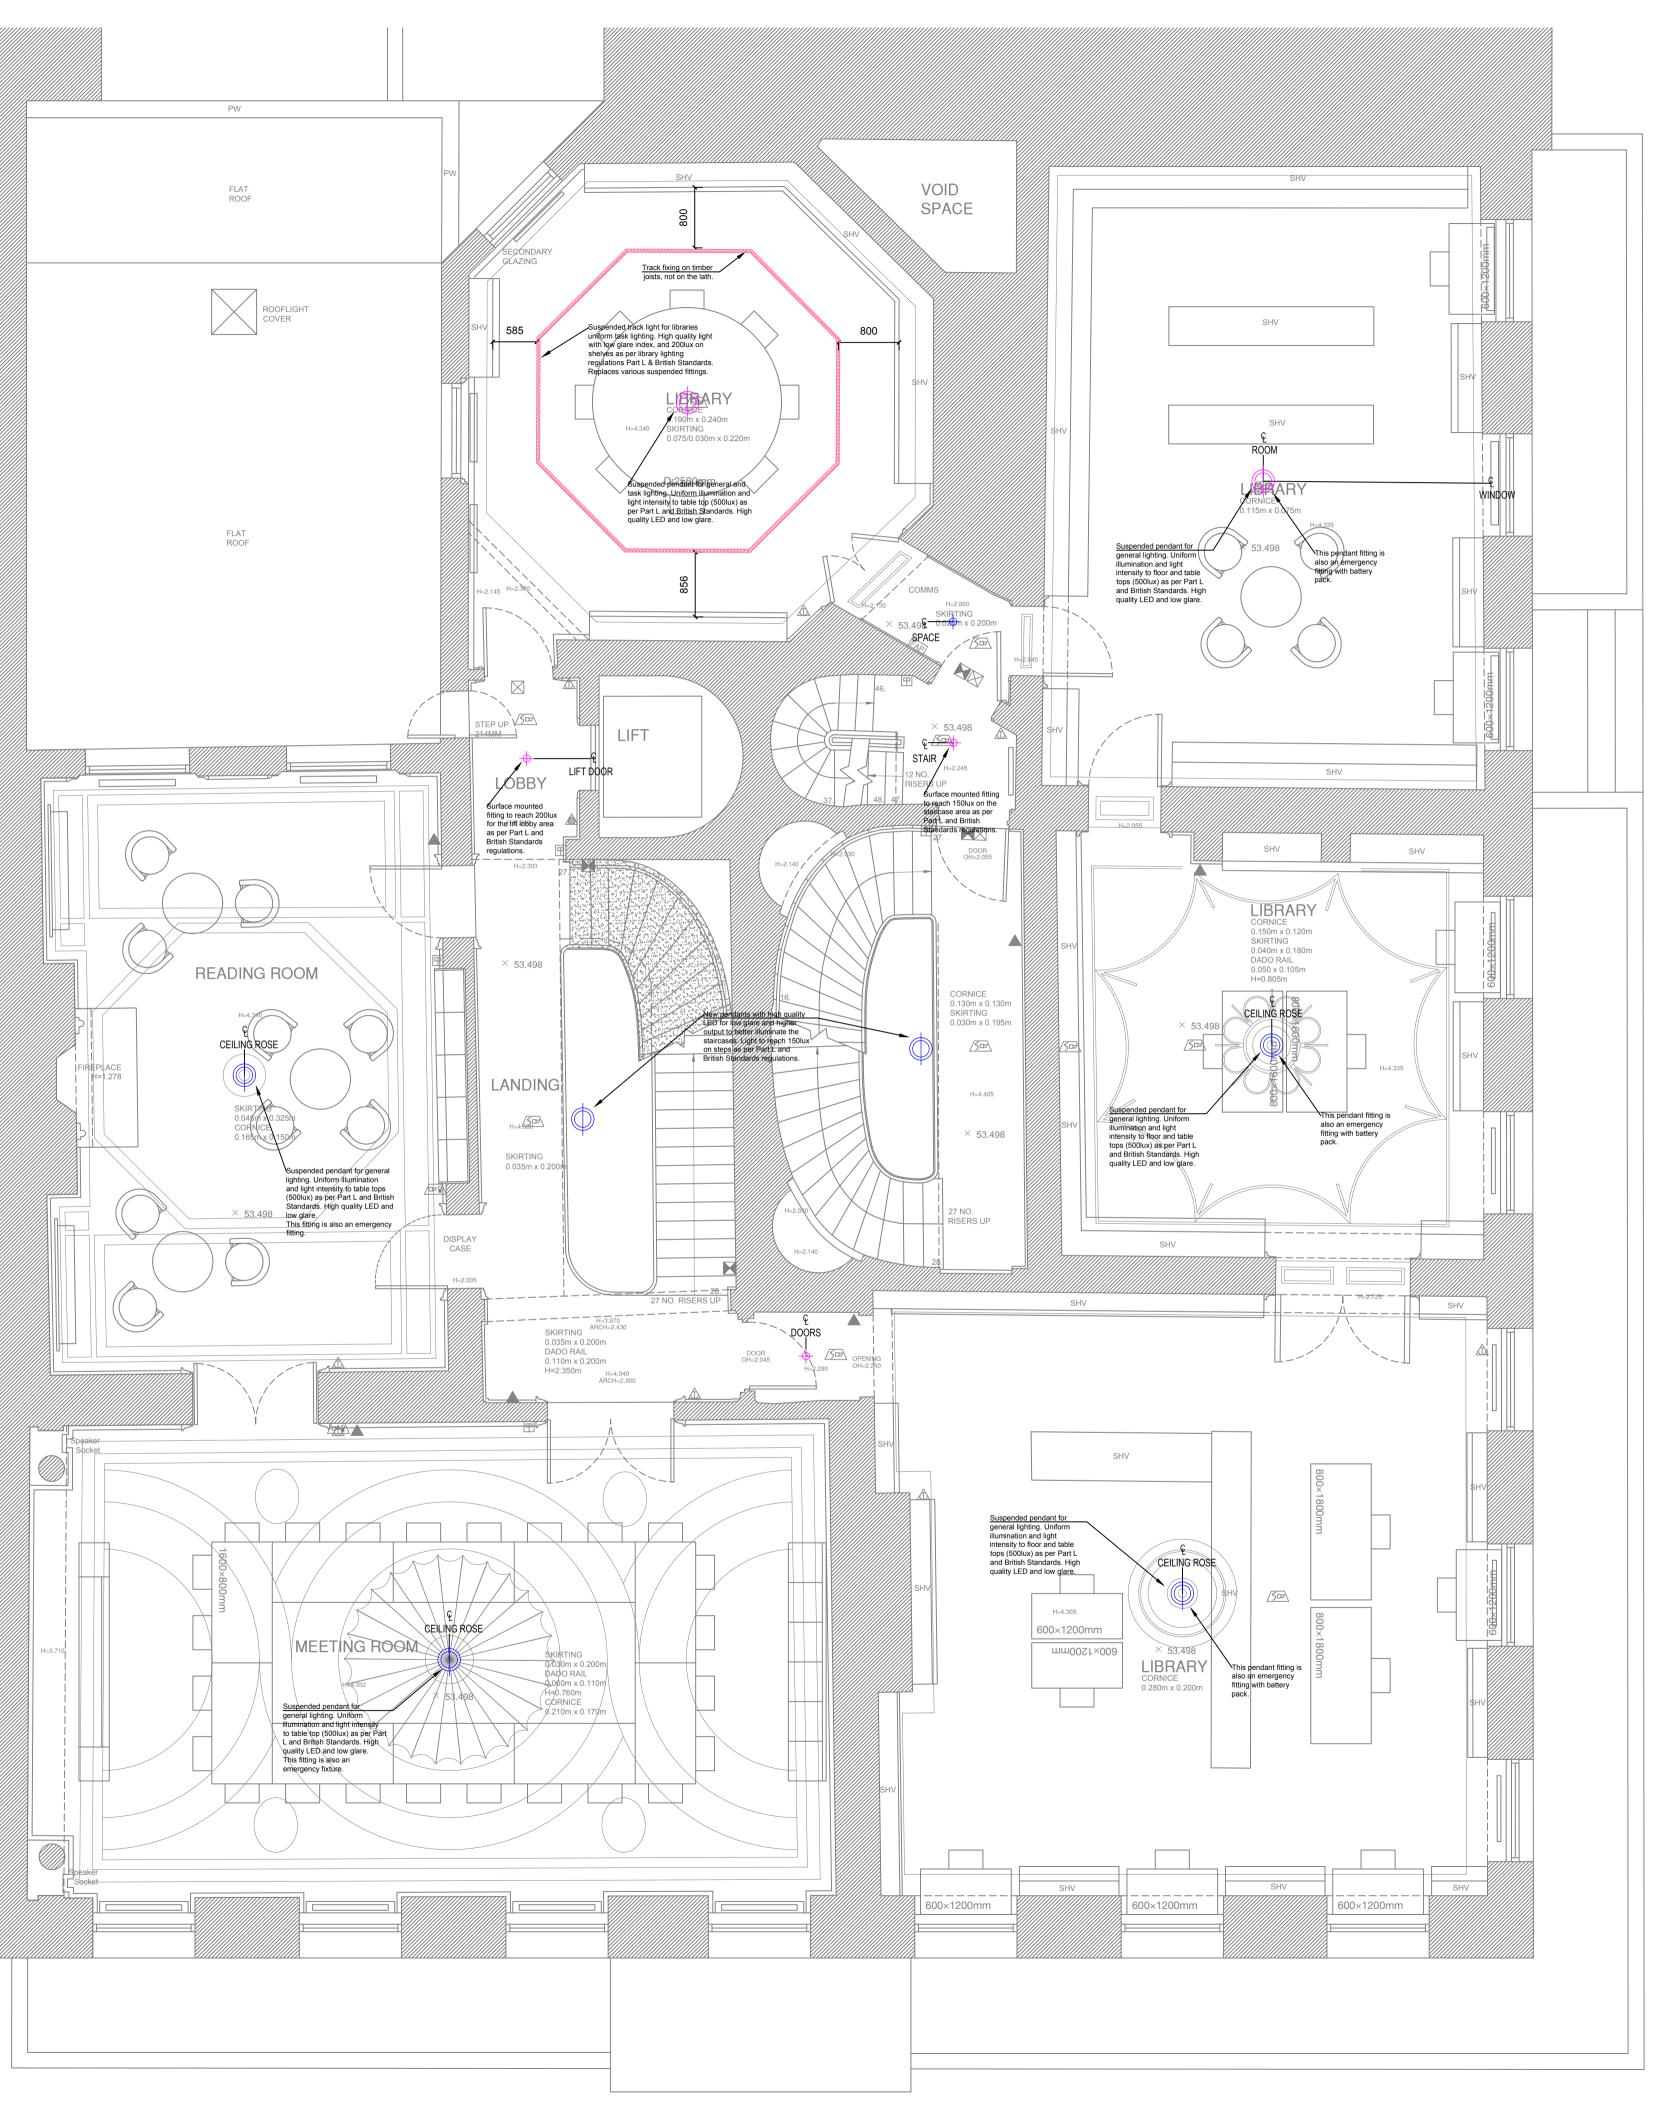

R	evision	Revision	Draw	Check
-	existing points ar indicated in the d All details as ava with the applicati from the outline of conditions that w up works are und be submitted. Ad provided as a Dis This drawing ind be used as an inst Existing routes an wherever feasible required these ha Where chasing i will be done car non-decorative,	rawings. ilable at this s ion. If the prop design include ill become evi ditional detail scharge of Cor icates design i tallation or wo nd penetration e. Where new ve been highli	tage have beer posal materiall d here becauss ident only afte v LBC applica s, if required, idition if requi ntent only and orking drawing s will be utilis routes/ penetra ghted in the d er is required, nd tools only, y and to the mi	n included y differs e of site r opening tion will can be red. I shall not g. ed ations are rawings.
-	extent required. match the existi plaster analysis Where penetrati existing penetrati existing penetrati not possible, ne- undertaken for of Where existing surfaces will be matching to the Existing skirting not be removed	All replasterin ng adjacent pl for specificati ons through jo tions will be r w limited peno- cable runs only light fittings a repaired in a l adjacent plast gs, dado panel	ng work will b aster, and info ons. pists are requir eused, and wh etrations will b y. re removed, a like for like ma er.	e done to rrmed by red, ere this is be Il plaster anner,
	ederic Pesign			arota
00 in	ia Antonio I 0197 Roma fo@federica ww.federica	acammar	ota.com	
Pr G	oject name		Projec	ct number FC_12
G	lient erman Histo f London	orical Ins	stitute	
Ex Pr	an CP tisting oposed eiling Plan		1F	ving title RCP-P Revision N/A
Da Sc	ate ale rawn/Check			7/12/2024 1:100 A3 MN/FC
	pproved rawing nam	e F	C 12 1	N/A F_RCP-P

X	Surface mounted wall lamp
<u>کم</u>	Surface mounted Emergency wall lamp
Ē	Surface mounted up-lighting spotlight to enhance the staircase corner decorations


SK RTING 0.130m x 0.210m

Colour Legend



Blue colour indicates new fittings cabled to existing power position, and with no need of new fixing points.

Purple colour indicates new fittings cabled to new power provisions, or to existing power but needing new fixing points.

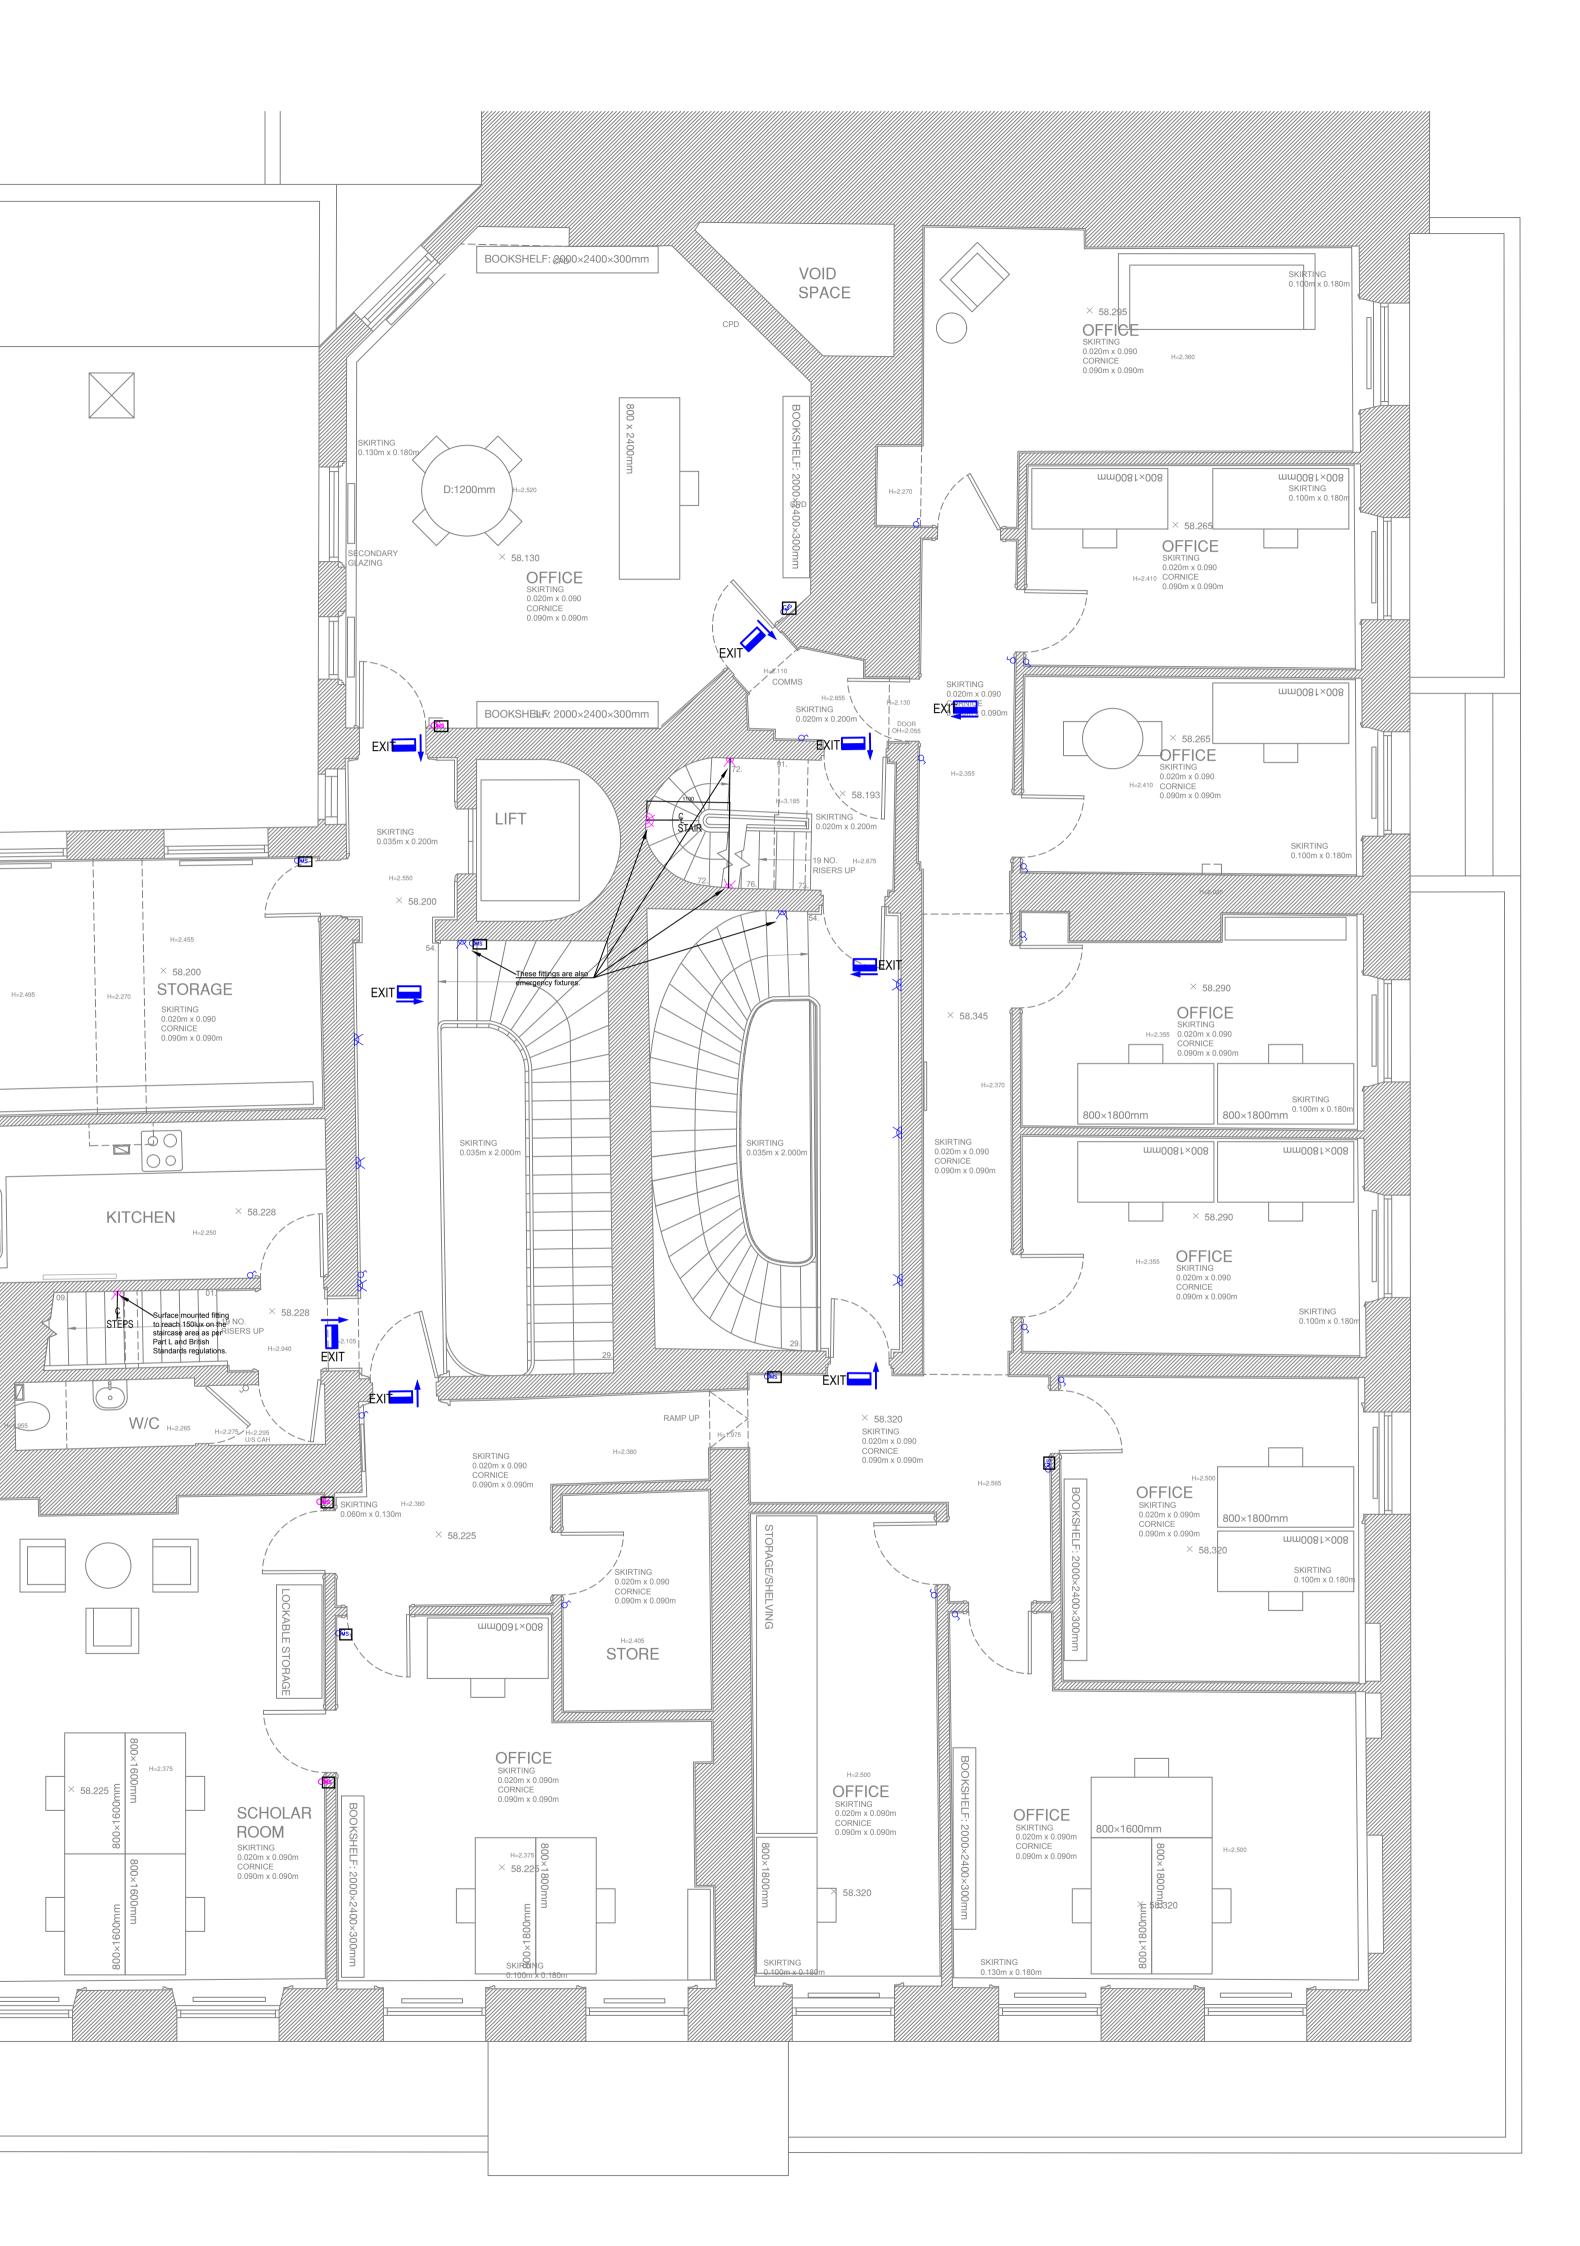

1				
Rev	rision			
Rev	r. Date	Revision	Draw	Check
- Th us - Ex fea thd doi are reper adj spe - Wi per nev onl	bmitted. Addi a Discharge c iis drawing im ed as an instal isting routes a usible. Where ese have been here chasing in the carefully w as only and to lastering worl acent plaster, cifications. here penetrations hetrations will w limited peno y.	taken, a new LBC tional details, if re of Condition if req dicates design inte lation or working and penetrations v new routes/ penet highlighted in the more voltes of the the minimum ext will be done to r and informed by p ons through joists be reused, and w trations will be u light fittings are re	equired, can be uired. ent only and sh drawing. vill be utilised rations are req e drawings. required, chas y, in non-deco tent required. / match the exist plaster analysis are required, e here this is not ndertaken for o	provided all not be wherever uired ing will be rative, flat All ing s for xisting possible, able runs
sur to t - Ex	faces will be in the adjacent p	repaired in a like f laster. s, dado panelling s	for like manner	, matching
		ca Car Studi		rota
		Studi	0	
	sign			
Via 0019 info(Antonio 07 Roma @federio	Bertoloni cacammarc	ota.com	
Via 0019 info(www	Antonio 07 Roma @federio	cacammarc	ota.com ota.com	t number FC_12
Via 0019 info(www	Antonio 07 Roma @federio v.federio	cacammarc	ota.com ota.com	
Via 0019 info(www Proj GHI Clie Gen	Antonio 07 Roma @federic v.federic ect name	cacammarc	ota.com ta.com Projec	
Via 0019 info(www Proj GHI Clie Gen	Antonio 07 Roma @federic v.federic ect name nt man His		ota.com ota.com Projec titute Draw	
Via 0019 info(www Proj GHI Clie Geri Of L Plan LLP Prop	Antonio 07 Roma @federic v.federic ect name nt man His	torical Inst	ta.com ta.com Projec titute Draw 2F	FC_12

 \bigcirc

	Surface mounted track light for vertical libraries illumination. High light quality and colour rendering index, light intensity achieving 200lux on vertical surfaces as required by library lighting regulations
- ф	Surface mounted light
\oplus	Pendant light
	Surface mounted downlight for general office lighting. Some of these on the plan are also Emergency fittings.
EXIT	Surface mounted emergency exit signage

Colour Legend



Blue colour indicates new fittings cabled to existing power position, and with no need of new fixing points.



Purple colour indicates new fittings cabled to new power provisions, or to existing power but needing new fixing points.

Pink colour indicates new fittings cabled to existing power provisions, but needing new fixing points.




Q	Surface mounted wall lamp
	Surface mounted Emergency wall lamp

Colour Legend



Blue colour indicates new fittings cabled to existing power position, and with no need of new fixing points.

Purple colour indicates new fittings cabled to new power provisions, or to existing power but needing new fixing points.

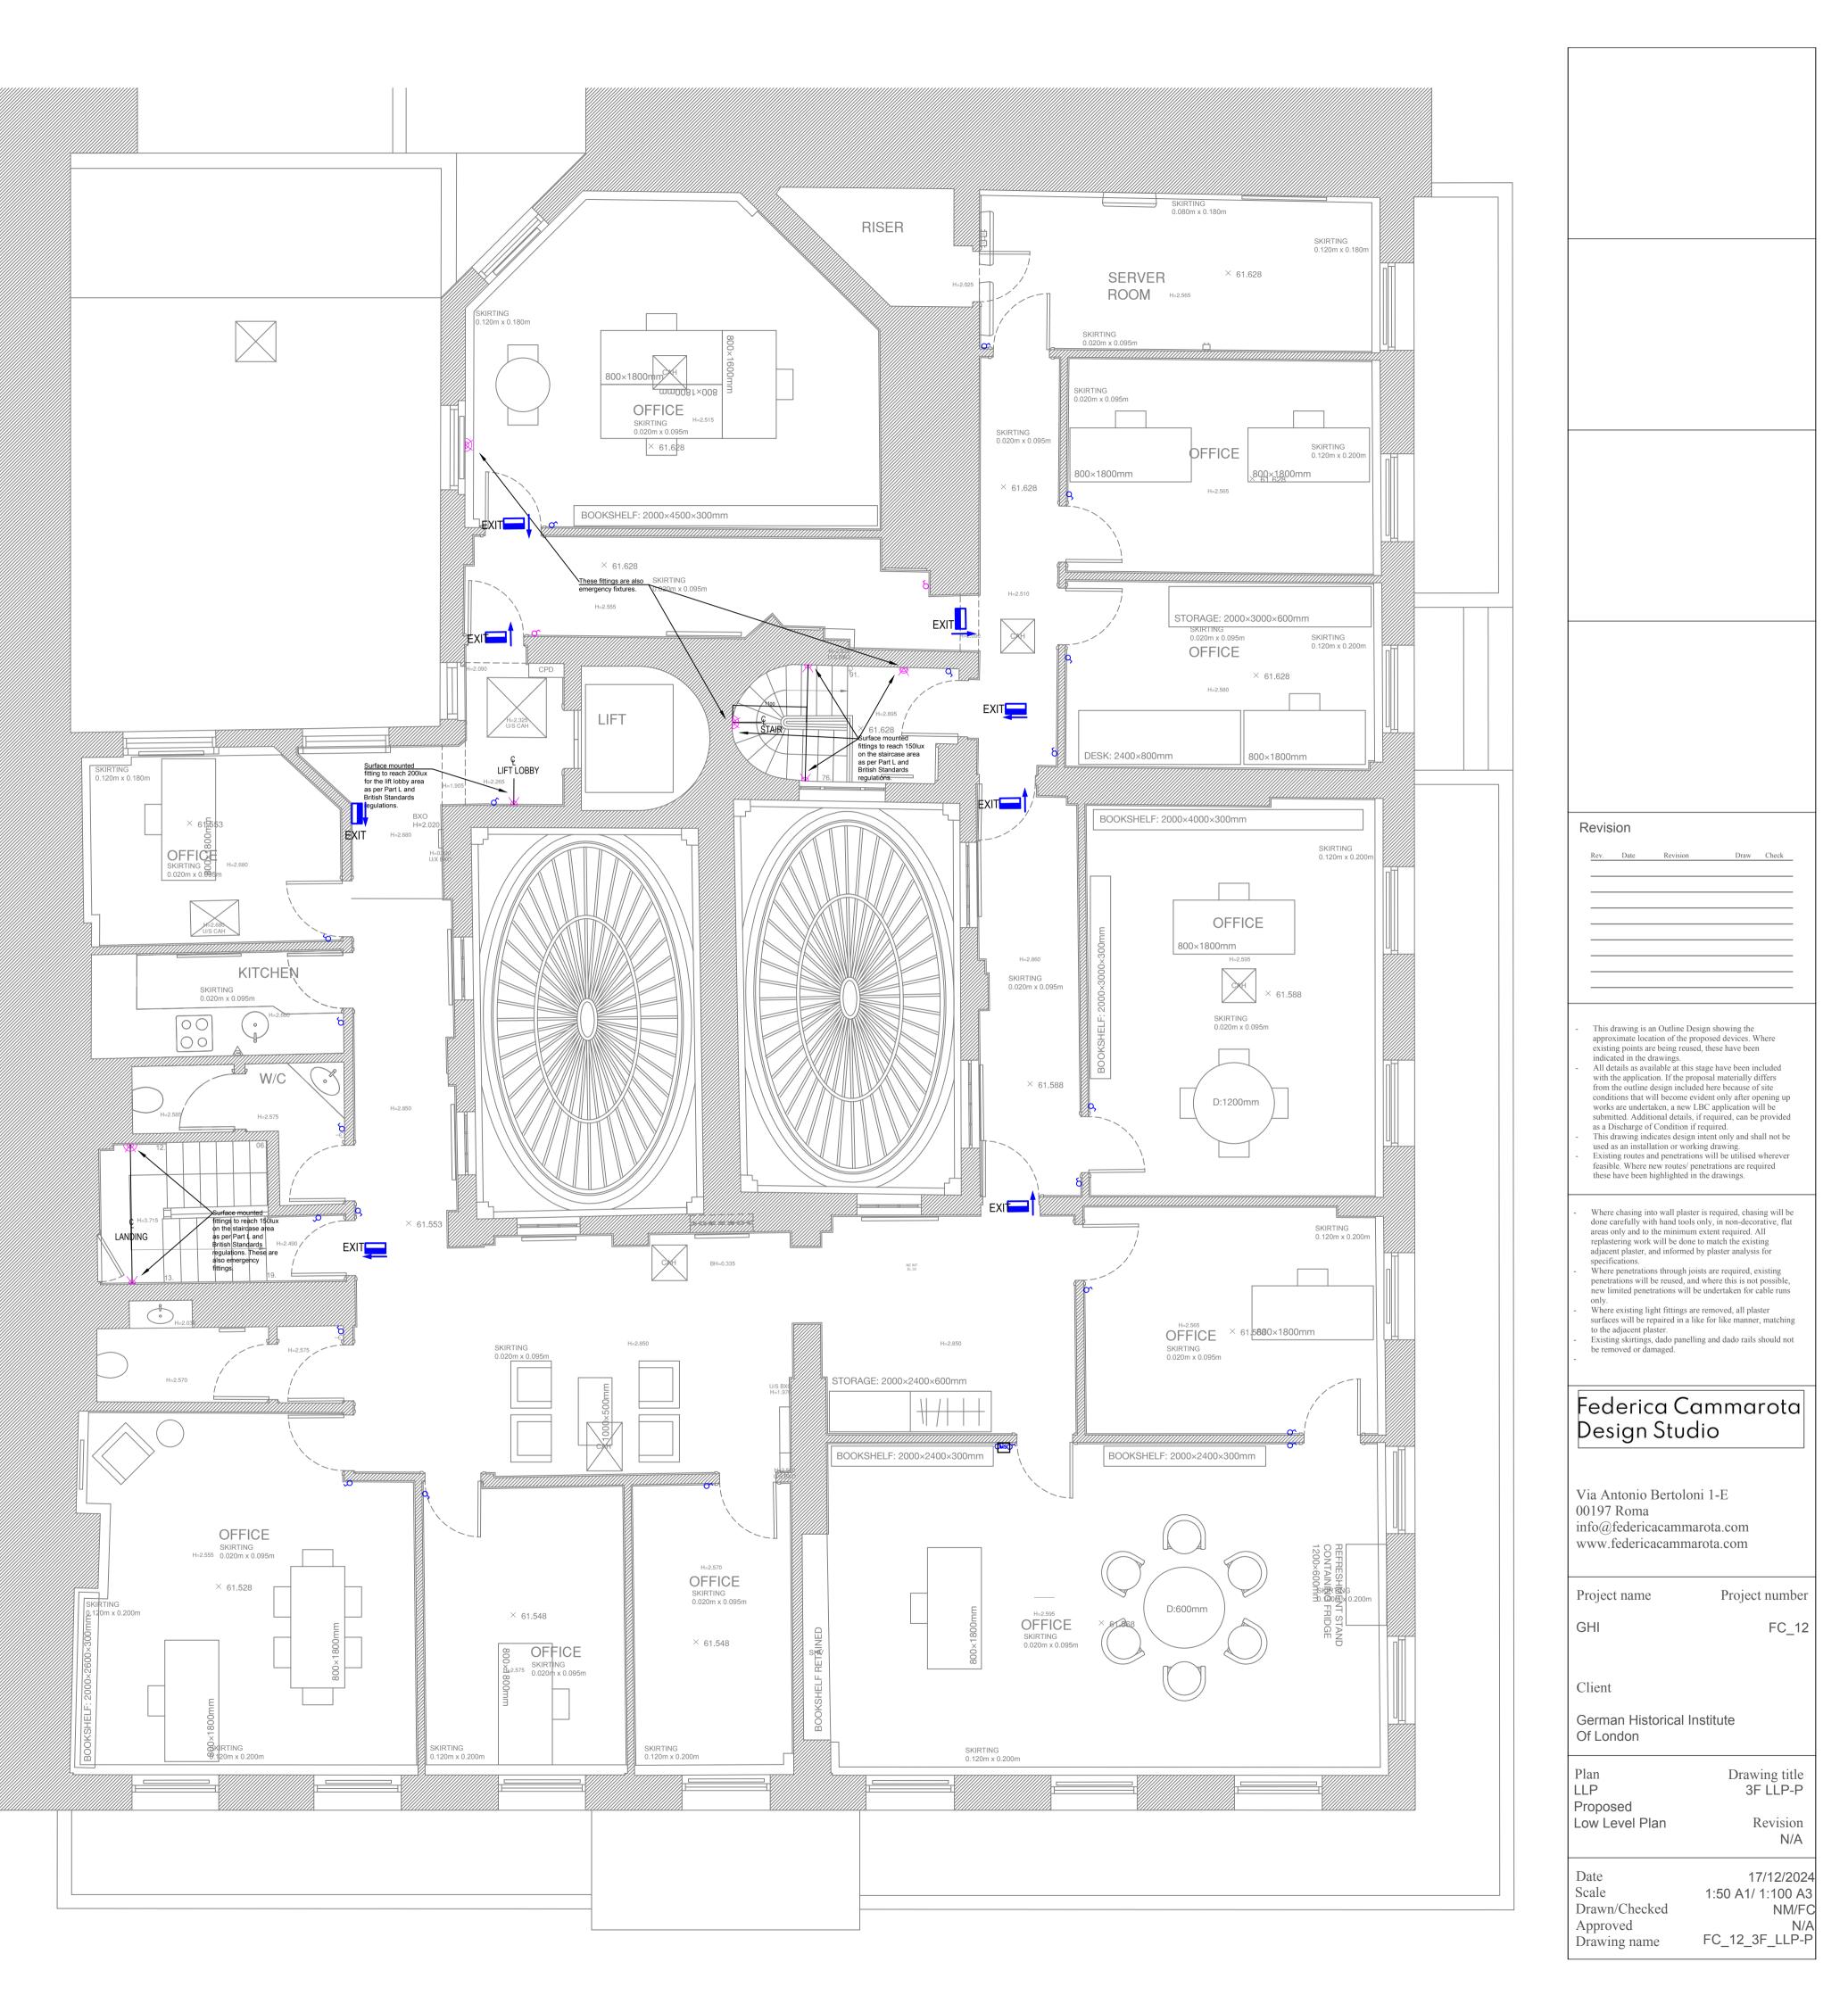

	Suspended linear pendant for task task lighting. Two suspension cables.
-	Surface mounted ceiling light. Some of these on the plan are also Emergency fittings
	Pendant light
	Surface mounted downlight for general office and corridor lighting. Some of these on the plan are also Emergency fittings.
0	Recessed small technical downlight for general office lighting
	Surface mounted linear light for enhancement of the glass domes
EXIT	Surface mounted emergency exit signage

Colour Legend

Blue colour indicates new fittings cabled to existing power position, and with no need of new fixing points.

Purple colour indicates new fittings cabled to new power provisions, or to existing power but needing new fixing points.

