

PROBLEMENT VIEW RESERVENCE VIEWER LEVEN ADDRESS VIEWER LEVEN ADDRESS SOURCE VIEWER ADDRESS DUCT INSURATION IN FORM AUTOMATION IN FORM AUTOMATION AUTOMA	No.8 DETAILS REFER TO DRG.	FOR STANLEY WRAP RISER				
SOUGO SUPPLY FROM ABOVE DUCT TERNINATION HIL FOR FUTURE TO HOUSE TO HOUSE TO HOUSE FUTURE TO HOUSE TO HOUSE FUTURE TO HOUSE TO HOUSE FOR STANLEY BULLON TO HOUSE TO HOUSE TO BULLON TO HOUS		No.3 DETAILS REFER TO DRG.		A		(
DUCT TERMINATION IN LEOR FUTURE TERMINATION IN LEOR DUCT TERMINATION IN LEOR FUTURE TERMINATION IN LEOR FUTURE TERMINATION IN LEOR CONCESSION EXTRACT DUCT CONCESSION EXTRACT TO ABOVE AND 4002020 DUCT FROM BELOW 150x100 SUPPLY 200x100 SUPPLY 200x100 SUPPLY 200x100 SUPPLY 200x100 SUPPLY 200x100 SUPPLY 200x100 SUPPLY 200x100 SUPPLY 200x100 SUPPLY			1			
DUCT TERMINATION HL FOR FUTURE TERMIN FIT OUT 8000/250 EXTRACT DUCT 2000/250 EXTRACT TO ABOVE 4000/250 EXTRACT TO ABOVE 4000/250 EXTRACT TO ABOVE 4000/250 EXTRACT TO ABOVE AND 400/250 DUCT FROM BELOW 150/100 EXTRACT TO ABOVE AND 50/100 EXTRACT TO ABOVE AND 50/100 EXTRACT TO ABOVE 150/100 EXTRACT TO ABOVE 2000/250 EXTRACT TO ABOVE AND 50/100 EXTRACT TO ABOVE 150/100 EVERTY FROM ABOVE 150/100 SUPPLY 150/100 SUP	DUCT TERMINATION HIL FOR FULURE TERMINATION HIL FOR COUCED EXTRACT COUCED EXTRACT COUCED EXTRACT COUCED EXTRACT COUCED EXTRACT COUCED EXTRACT 150/100 E	DUCT TERMINATION H/L FOR				
3 200x200 EXTRACT 405x000 EXTRACT TO ABOVE AND 400x200 DUCT FROM BELOW 150x100 EXTRACT 150x100 EXTRACT 150x100 EXTRACT 150x100 EXTRACT 150x100 EXTRACT 150x100 DUCT TO ABOVE AND 150x100 DUCT TO BELOW 200x150 SUPPLY FOR STANLEY BUILDING 150x100 SUPPLY 200x150 SUPPLY 200x150 SUPPLY 200x150 SUPPLY 150x100 SUPPLY 200x150 SUPPLY 150x100 SUPPLY 200x150 SUPPLY 150x100 SUPPLY 200x150 SUPPLY 200x15	3 3	DUCT TERMINATION H/L FOR				
3 2002200 EXTRACT 450x200 EXTRACT 150x100 EXTRACT 150x100 EXTRACT 150x100 EXTRACT 150x100 EXTRACT TO ABOVE AND 150x100 BELOW 200x150 SUPPLY FOR STANLEY BUILDING RISER DETAILS REFER TO DRG 4142/SERT TO BELOW 150x100 SUPPLY 200x150 SUPPLY FROM ABOVE AND 150x100 SUPPLY 150x100 SUPPLY 200x150 SUPPLY FROM ABOVE AND 150x100 SUPPLY	3 3 4 4 500200 EXTRACT TO ABOVE AND 400200 DUCT FROM BELOW 150x100 EXTRACT TO ABOVE 200150 SUPPLY HROM ABOVE 150x100 SUPPLY 200150 SUPPLY HROM ABOVE 200150 SUPPLY 200150 SUPPLY <		2		Lift Lobby	
AND 400/200 DUCT FROM BELOW	AND 400x200 DUCT FROM BELOW	450x300 EXTRACT TO ABOVE	3		WG015a Stair 2	
AND 150X100 DUPLY TO BELOW 150X100 SUPPLY FOR STANLEY BUILDING RISER DETAILS REFER TO DRG. 4142/SERV/301 150X100 SUPPLY 200X150 SUPPLY FROM ABOVE AND 150X100 SUPPLY 150X100 SUPPLY 200X150 SUPPLY 2	AND 150/100 DUCT TO BLOW 150/100 SUPPLY FOR STANLEY BUILDING RISER DETAILS REFER TO DRG. 4142/SERVI3301 150/100 SUPPLY 200/150 SUPPLY 150/100 SUPPLY 150/100 SUPPLY 200/150 SUPPLY 2	150x100 EXTRACT				
150x100 SUPPLY	DNG-4 HASSEN0301 150x100 SUPPLY FROM ABOVE AND 150x100 SUPPLY 150x100 SUPPLY 200x150 SUPPLY FROM ABOVE AND 150x100 SUPPLY 200x150 SUPPLY 200x150 SUPPLY 150x100 SUPPLY 200x150 SUPPLY 150x100 SUPPLY 200x150 SUPLY 200x150 SUPLY 20	AND 150x100 DUCT TO BELOW 150x100 SUPPLY — FOR STANLEY BUILDING — RISER DETAILS REFER TO		``````````````````````````````````````	S115 Office	
150x100 SUPPLY — 200x150 SUPPLY FROM ABOVE AND 150x100 DUCT TO BELOW	150x100 SUPPLY	150x100 SUPPLY		· · · · · · · · · · · · · · · · · · ·	SD/03	S113
200x150 SUPPLY FROM ABOVE	200x150 SUPPLY FROM ABOVE AND 150x100 DUCT TO BELOW 150x100 SUPPLY					JIIICE
150X100 SUPPLY	DO NOT SCALE FROM THIS DRAWING.	200x150 SUPPLY FROM ABOVE AND 150x100 DUCT TO BELOW			· 	
	DO NOT SCALE FROM THIS DRAWING.	150x100 SUPPLY ————				

Q:\01 - Projects\4142 - Kings Cross Zone B - Building E1\04 - Services\01 - Mechanical\13 - Drawings\AutoCAD\Drawings\4142-SERV-3110 HIGH LEVEL GROUND FLOOR STANLEY WRAP & FIRST FLOOR STANLEY BUILDING VENTILATION LAYOUT.dwg

SPECIFICATION.

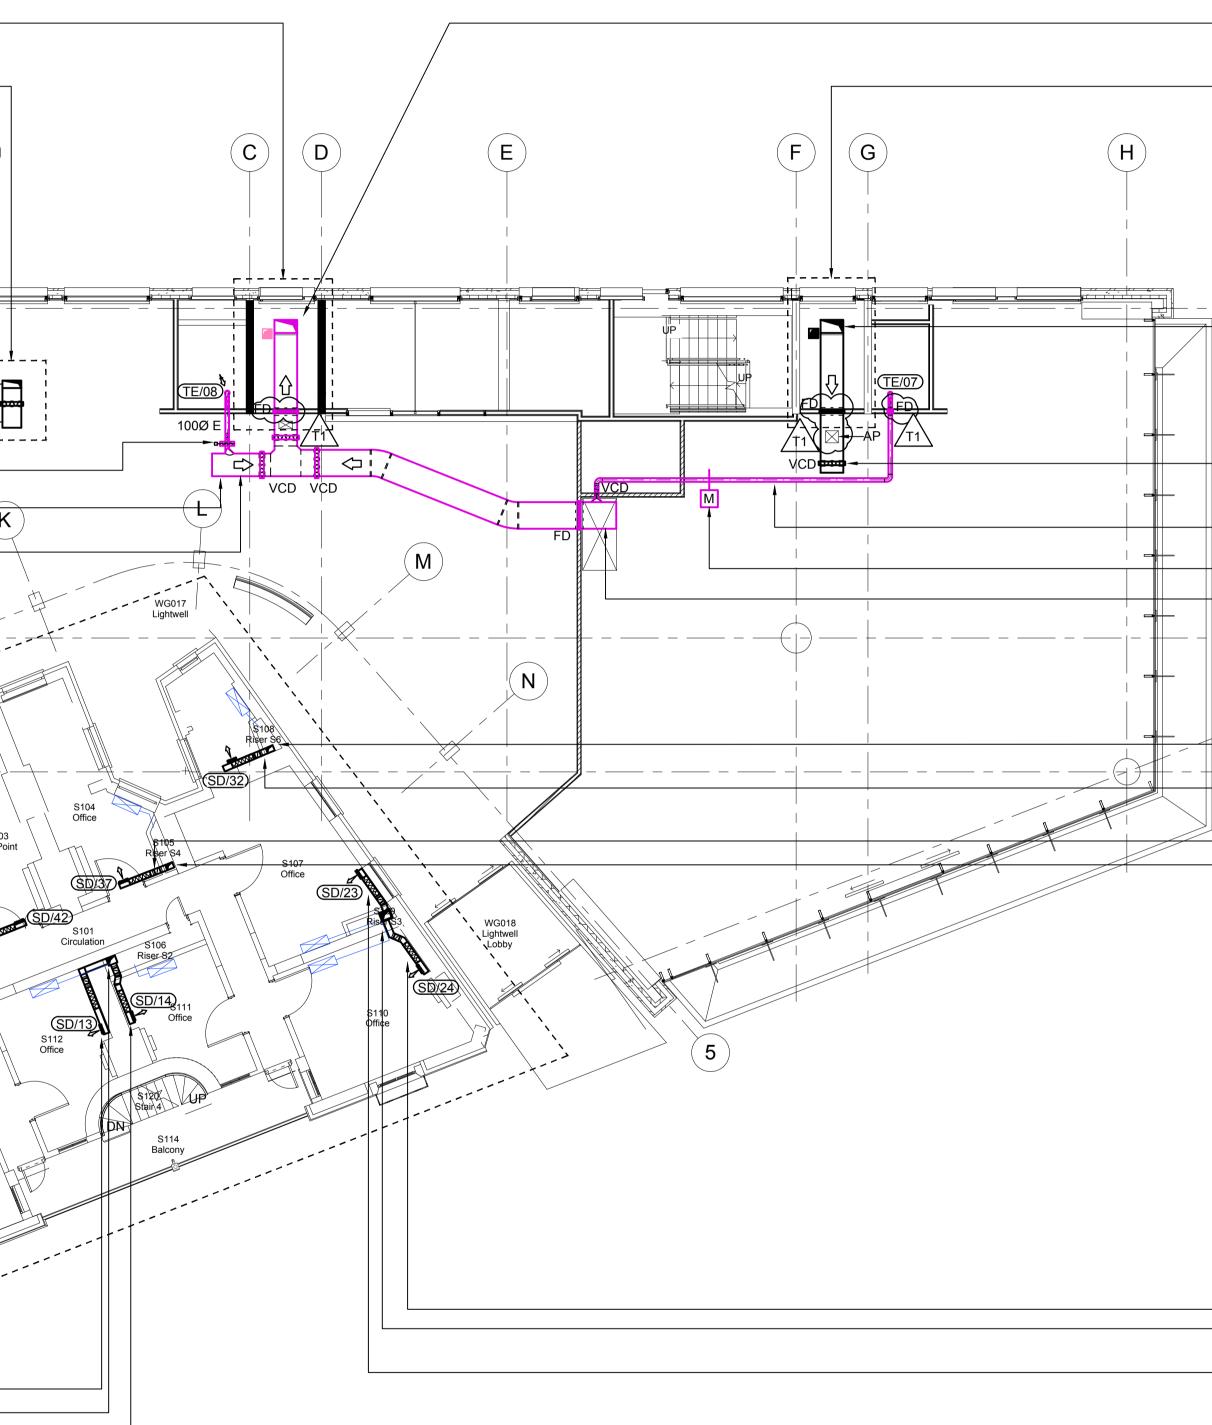

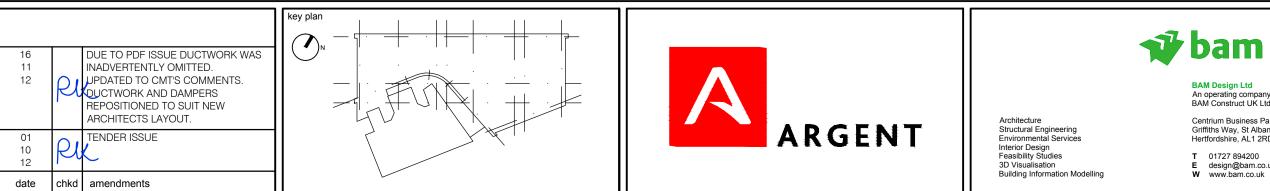

rev by

600x350	EXTRACT	DUCT	ΤΟ Α	BOVE

FOR STANLEY WRAP RISER
 No.3 DETAILS REFER TO DRG.
 4142/SERV/3300.

600x350 SUPPLY DUCT FROM ABOVE.

> - 600x350 SUPPLY DUCT FOR RETAIL UNIT. DUCT TERMINATES AT HIGH LEVEL FOR FUTURE TENANT FIT OUT.

— 100Ø WC EXTRACT

- AUTOMATIC SHUT OFF DAMPER

- 700x200 EXTRACT DUCT FOR RETAIL UNIT. DUCT TERMINATES AT HIGH LEVEL FOR FUTURE TENANT FIT OUT.

6 -(3)

(2)

—(**1**)

- 150x150 SUPPLY FROM ABOVE AND 150x100 DUCT TO BELOW – 150x100 SUPPLY

150x100 SUPPLY

150x150 SUPPLY FROM ABOVE AND 150x100 DUCT TO BELOW

150x100 SUPPLY 200x150 SUPPLY FROM ABOVE AND 150x150 DUCT TO BELOW - 150x100 SUPPLY

	project	drawing status		TENDER	2	
	Kings Cross Zone B - Building E1	contract no.		scale	1:100 @	A1
l npany of IK Ltd	title	client ref.		date	October.	'12
ss Park Albans 1 2RD 00	HIGH LEVEL GROUND FLOOR STANLEY WRAP AND FIRST FLOOR STANLEY	drawn by	DJC	checke	d by PK	_
n.co.uk p.uk	BUILDING VENTILATION LAYOUT	drawing no.	4142	SERV	3110	T1