
FOR STANLEY WRAP RISER No.2 DETAILS REFER TO DRG. 4142/SERV/3303. T1 FOR STANLEY WRAP RISER				
No.3 DETALS REFER TO DRG. 4142/SERV/3303. 		A		
	1			
500x300 SUPPLY FROM ABOVE — AND 500x200 SUPPLY TO BELOW DUCT TERMINATION H/L FOR — FUTURE TENANT FIT OUT 200Ø EXTRACT —				
AUTOMATIC SHUT OFF DAMPER —— DUCT TERMINATION H/L FOR ——— FUTURE TENANT FIT OUT 600X250 EXTRACT DUCT —————		W114 W114 Office		
	2	W116 Lift 4		
200x200 EXTRACT	3			
450x300 EXTRACT TO ABOVE AND 450x300 DUCT FROM BELOW	<b>4</b>			
200x150 EXTRACT TO ABOVE AND 150x100 DUCT FROM BELOW 200x150 SUPPLY FROM ABOVE AND 150x100 DUCT TO BELOW 150x100 SUPPLY		Schement Sch		
150x100 SUPPLY		SZ10 Office SD/05 S216 Riser S1 S1		
150x100 SUPPLY				


PARTICULAR SPECIFICATION & PLANT

EQUIPMENT SCHEDULES & AECOM

SPECIFICATION.

Creaser, Daniel 16/11/2012 08:44:20

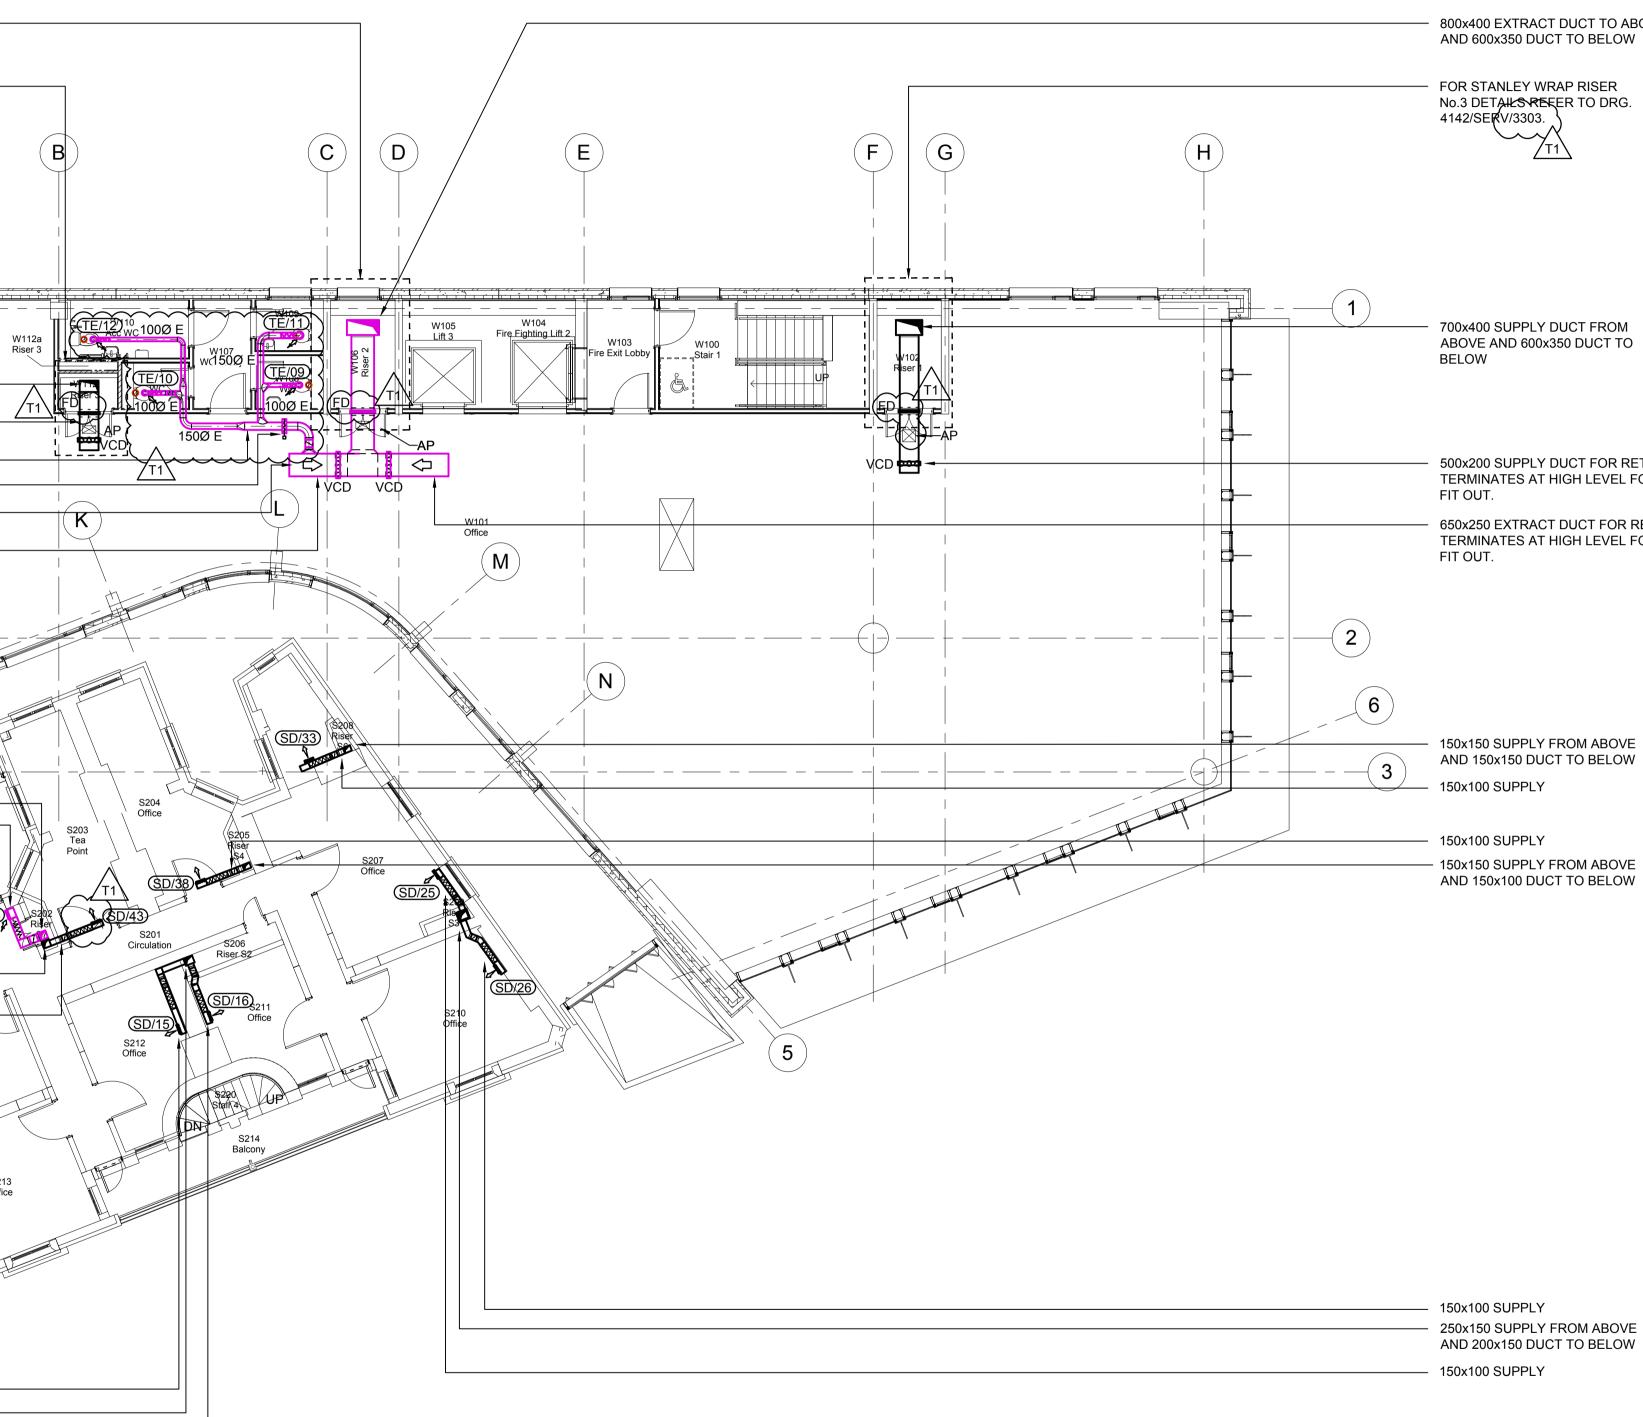

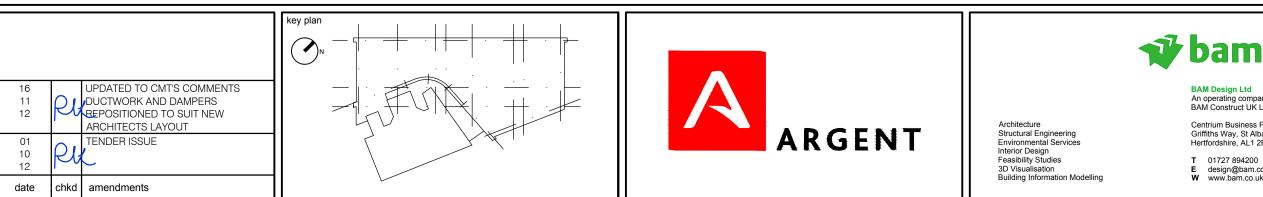

12

rev by

## 800x400 EXTRACT DUCT TO ABOVE AND 600x350 DUCT TO BELOW



500x200 SUPPLY DUCT FOR RETAIL UNIT. DUCT TERMINATES AT HIGH LEVEL FOR FUTURE TENANT FIT OUT.

650x250 EXTRACT DUCT FOR RETAIL UNIT. DUCT TERMINATES AT HIGH LEVEL FOR FUTURE TENANT FIT OUT.

150x150 SUPPLY FROM ABOVE AND 150x150 DUCT TO BELOW 150x100 SUPPLY

- 150x100 SUPPLY

150x150 SUPPLY FROM ABOVE
AND 150x100 DUCT TO BELOW

150x100 SUPPLY - 250x150 SUPPLY FROM ABOVE AND 200x150 DUCT TO BELOW - 150x100 SUPPLY

	project	drawing status TENDER					
hpany of	Kings Cross Zone B - Building E1	contract no.		scale	1:100 @ October.		
K Ltd is Park Albans 1 2RD 00	FIRST FLOOR STANLEY WRAP & SECOND FLOOR STANLEY BUILDING	drawn by DJC		checke	checked by RK		
n.co.uk o.uk	VENTILATION LAYOUT	drawing no.	4142	SERV	3111	T1	