

NOTES:

All dimensions in millimetres.

All dimensions and levels are to be checked on site to prior to commencing excavation works. any discrepa

All dimensions and levels are to be checked on site by the main contractor prior to commencing excavation works. any discrepancy is to be reported back to the designer for instruction.

This drawing is the property of ARGENT DESIGN LIMITED and may not be reproduced or disclosed to a third party in any form without written permission

GENERAL NOTES:

DRAWINGS TO BE READ IN CONJUNCTION WITH: SCHEDULE OF EXISTING CONDITIONS, DETAIL DRAWINGS, STATEMENTS AND SPECIALIST REPORTS. ALL EXISTING CORNICES ARE RETAINED AND REPAIRED WHERE REQUIRED. FOR NEW CORNICES SEE SCHEDULE.

LIGHTING KEY

DOWNLIGHT

TABLE LIGHT

WALL MOUNTED LUMINAIREnote typically mounted at 1800mm above FFL, but TBC

PENDANT LUMINAIRE

② DIRECTIONAL DOWNLIGHTJ⊗ LIGHT IN JOINERY / NICHE

LIGHTING CIRCUIT- LIGHTING SPEC. BY LANDSCAPE ARCHITECT

FLUORESCENT BATTEN

PIR LIGHT

RECESSED WALL LIGHTS

UNDER CABINET
FIXTURE - VERIFY LENGTH

LOW LEVEL LIGHT

FLOOR LAMP



* ** **

CLIENT/PROJECT:

34-35 FITZROY SQUARE

SHEET TITLE:

Lower Ground Floor Lighting Plan

DATE: 1:50 (A1) DRAWN BY:

DATE: 2010-07-23 APPROVED:


DRAWING No: 2425 F.S. L. C.E. 121 Rev. No.:

DRAWING No: 3435FS-LGF-121

ARGENT
DESIGN LIMITED

100 George Street London, W1U 8NU


TELEPHONE: 020 7563 4250 FAX: 020 7563 4251 EMAIL: INFO@ARGENTDESIGN.CO.UK

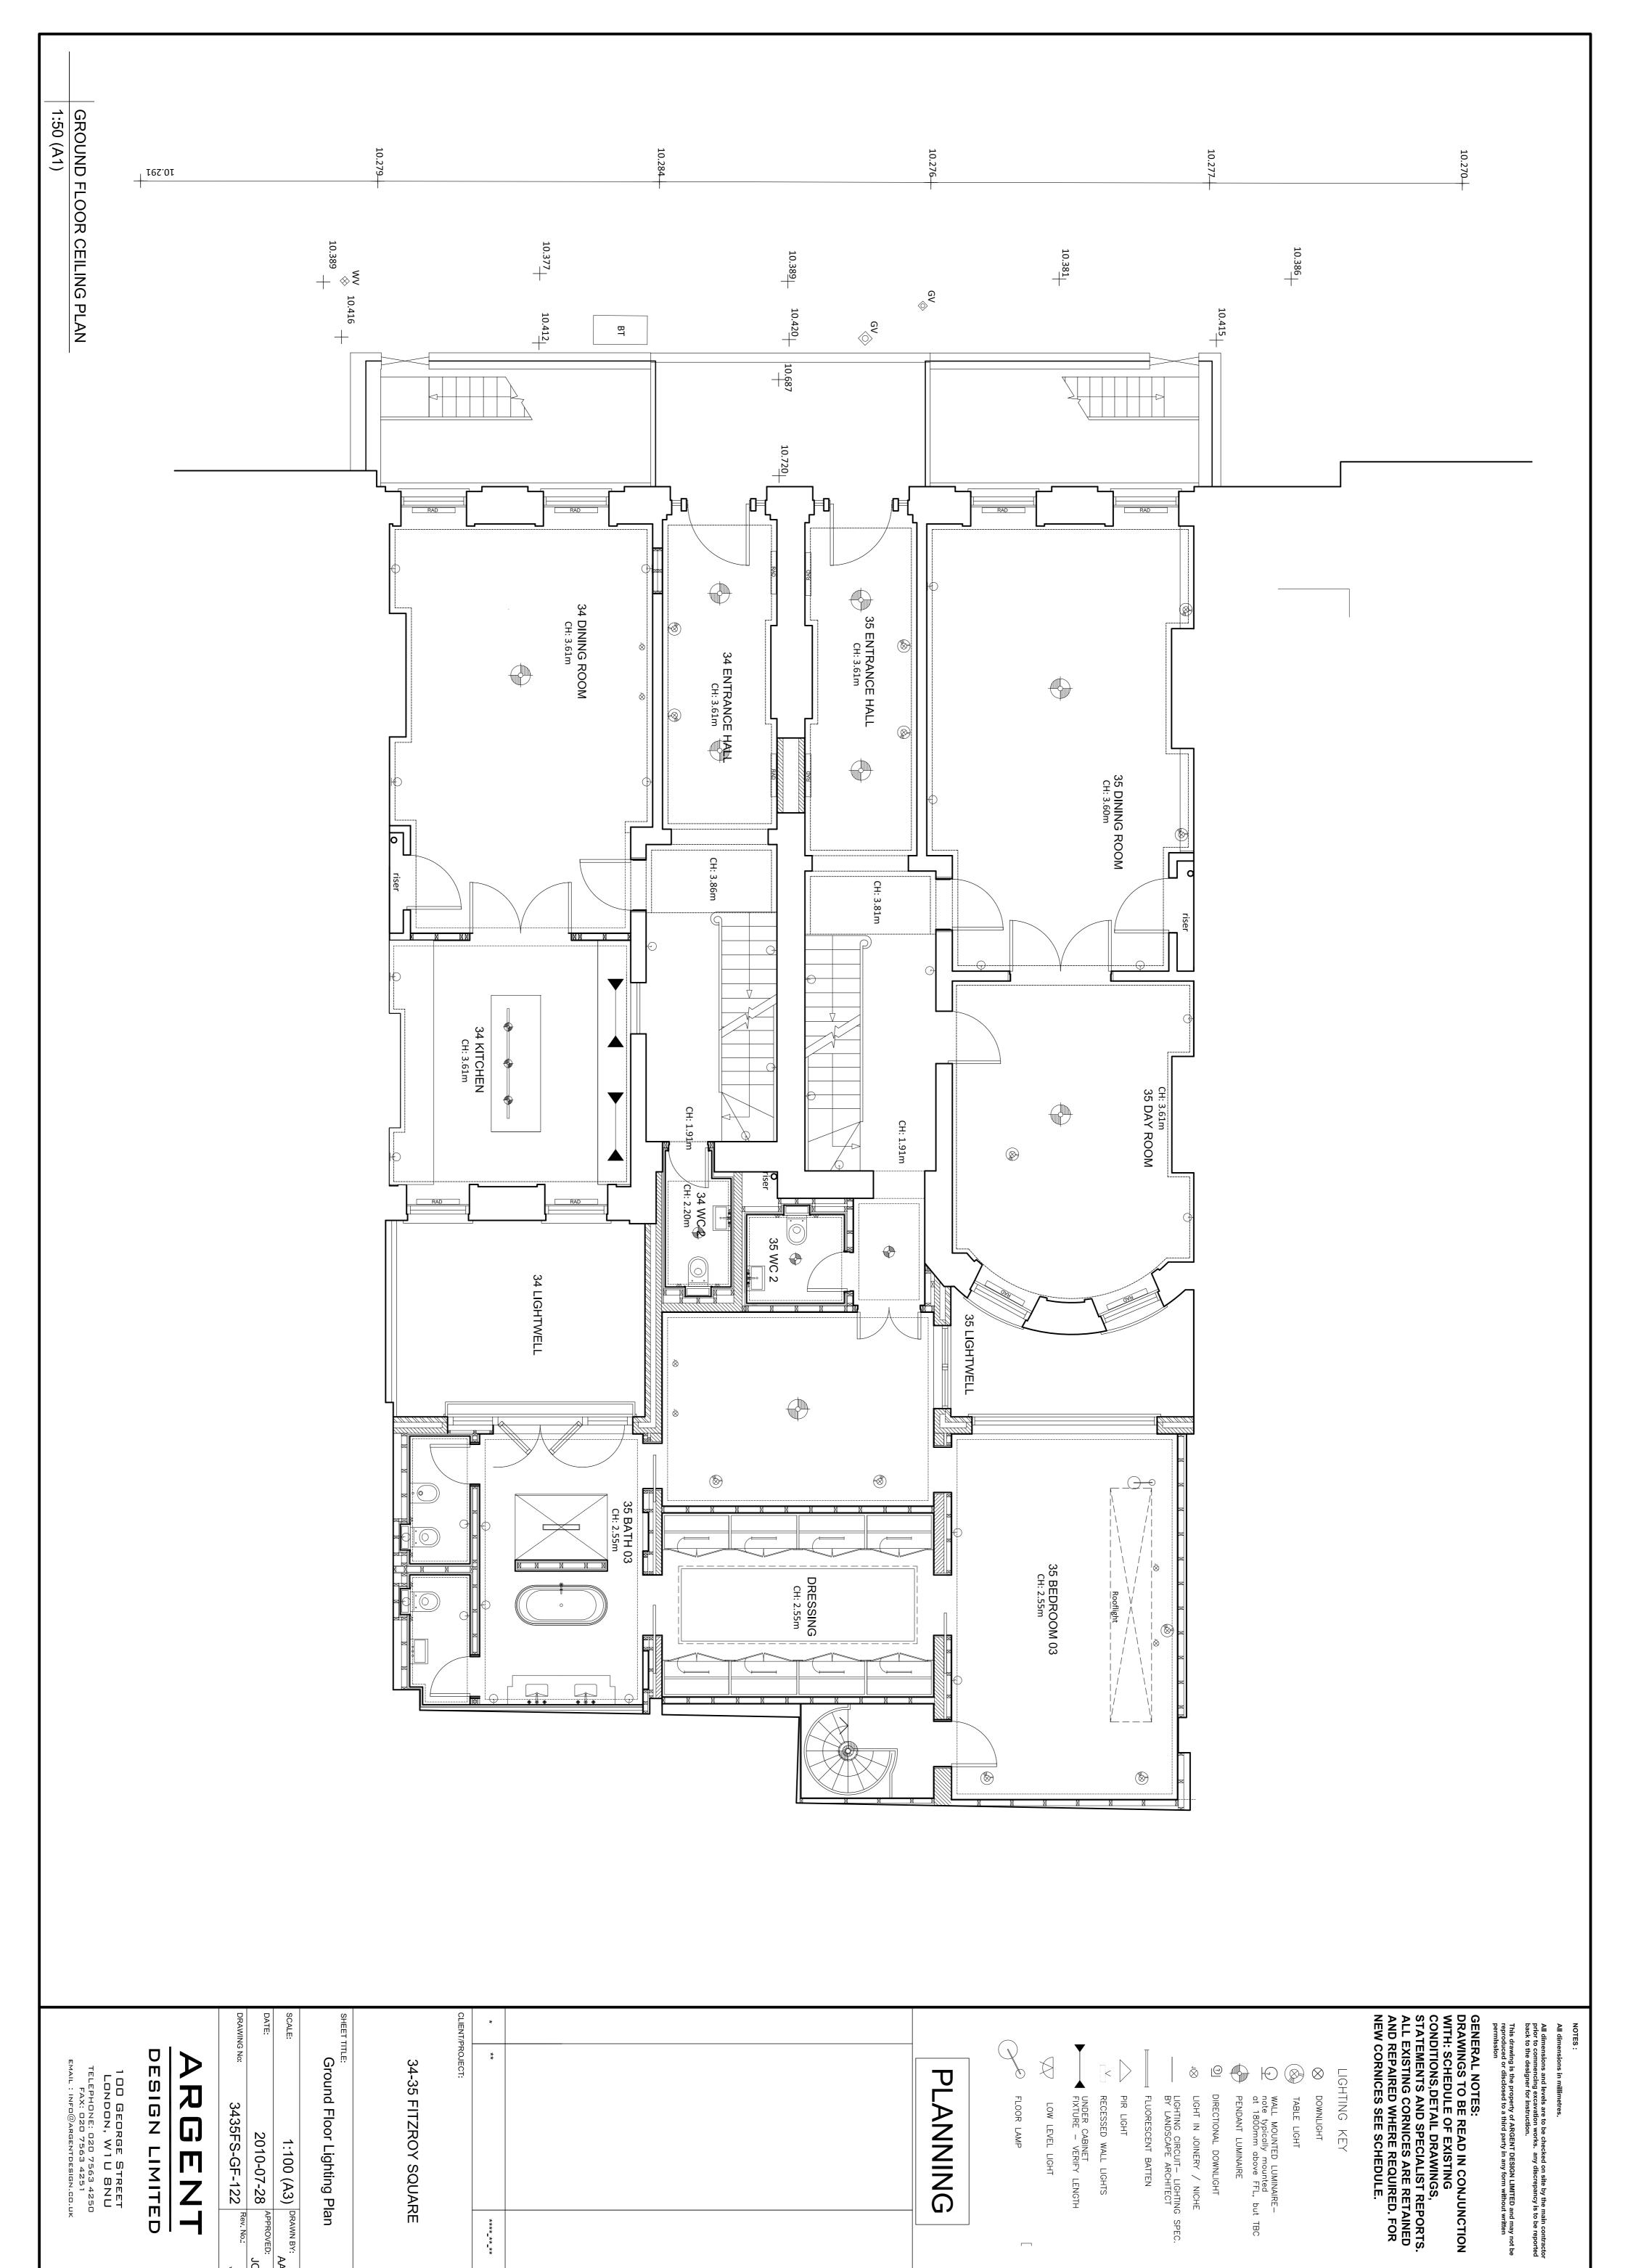

* * * * * * *

}

JC

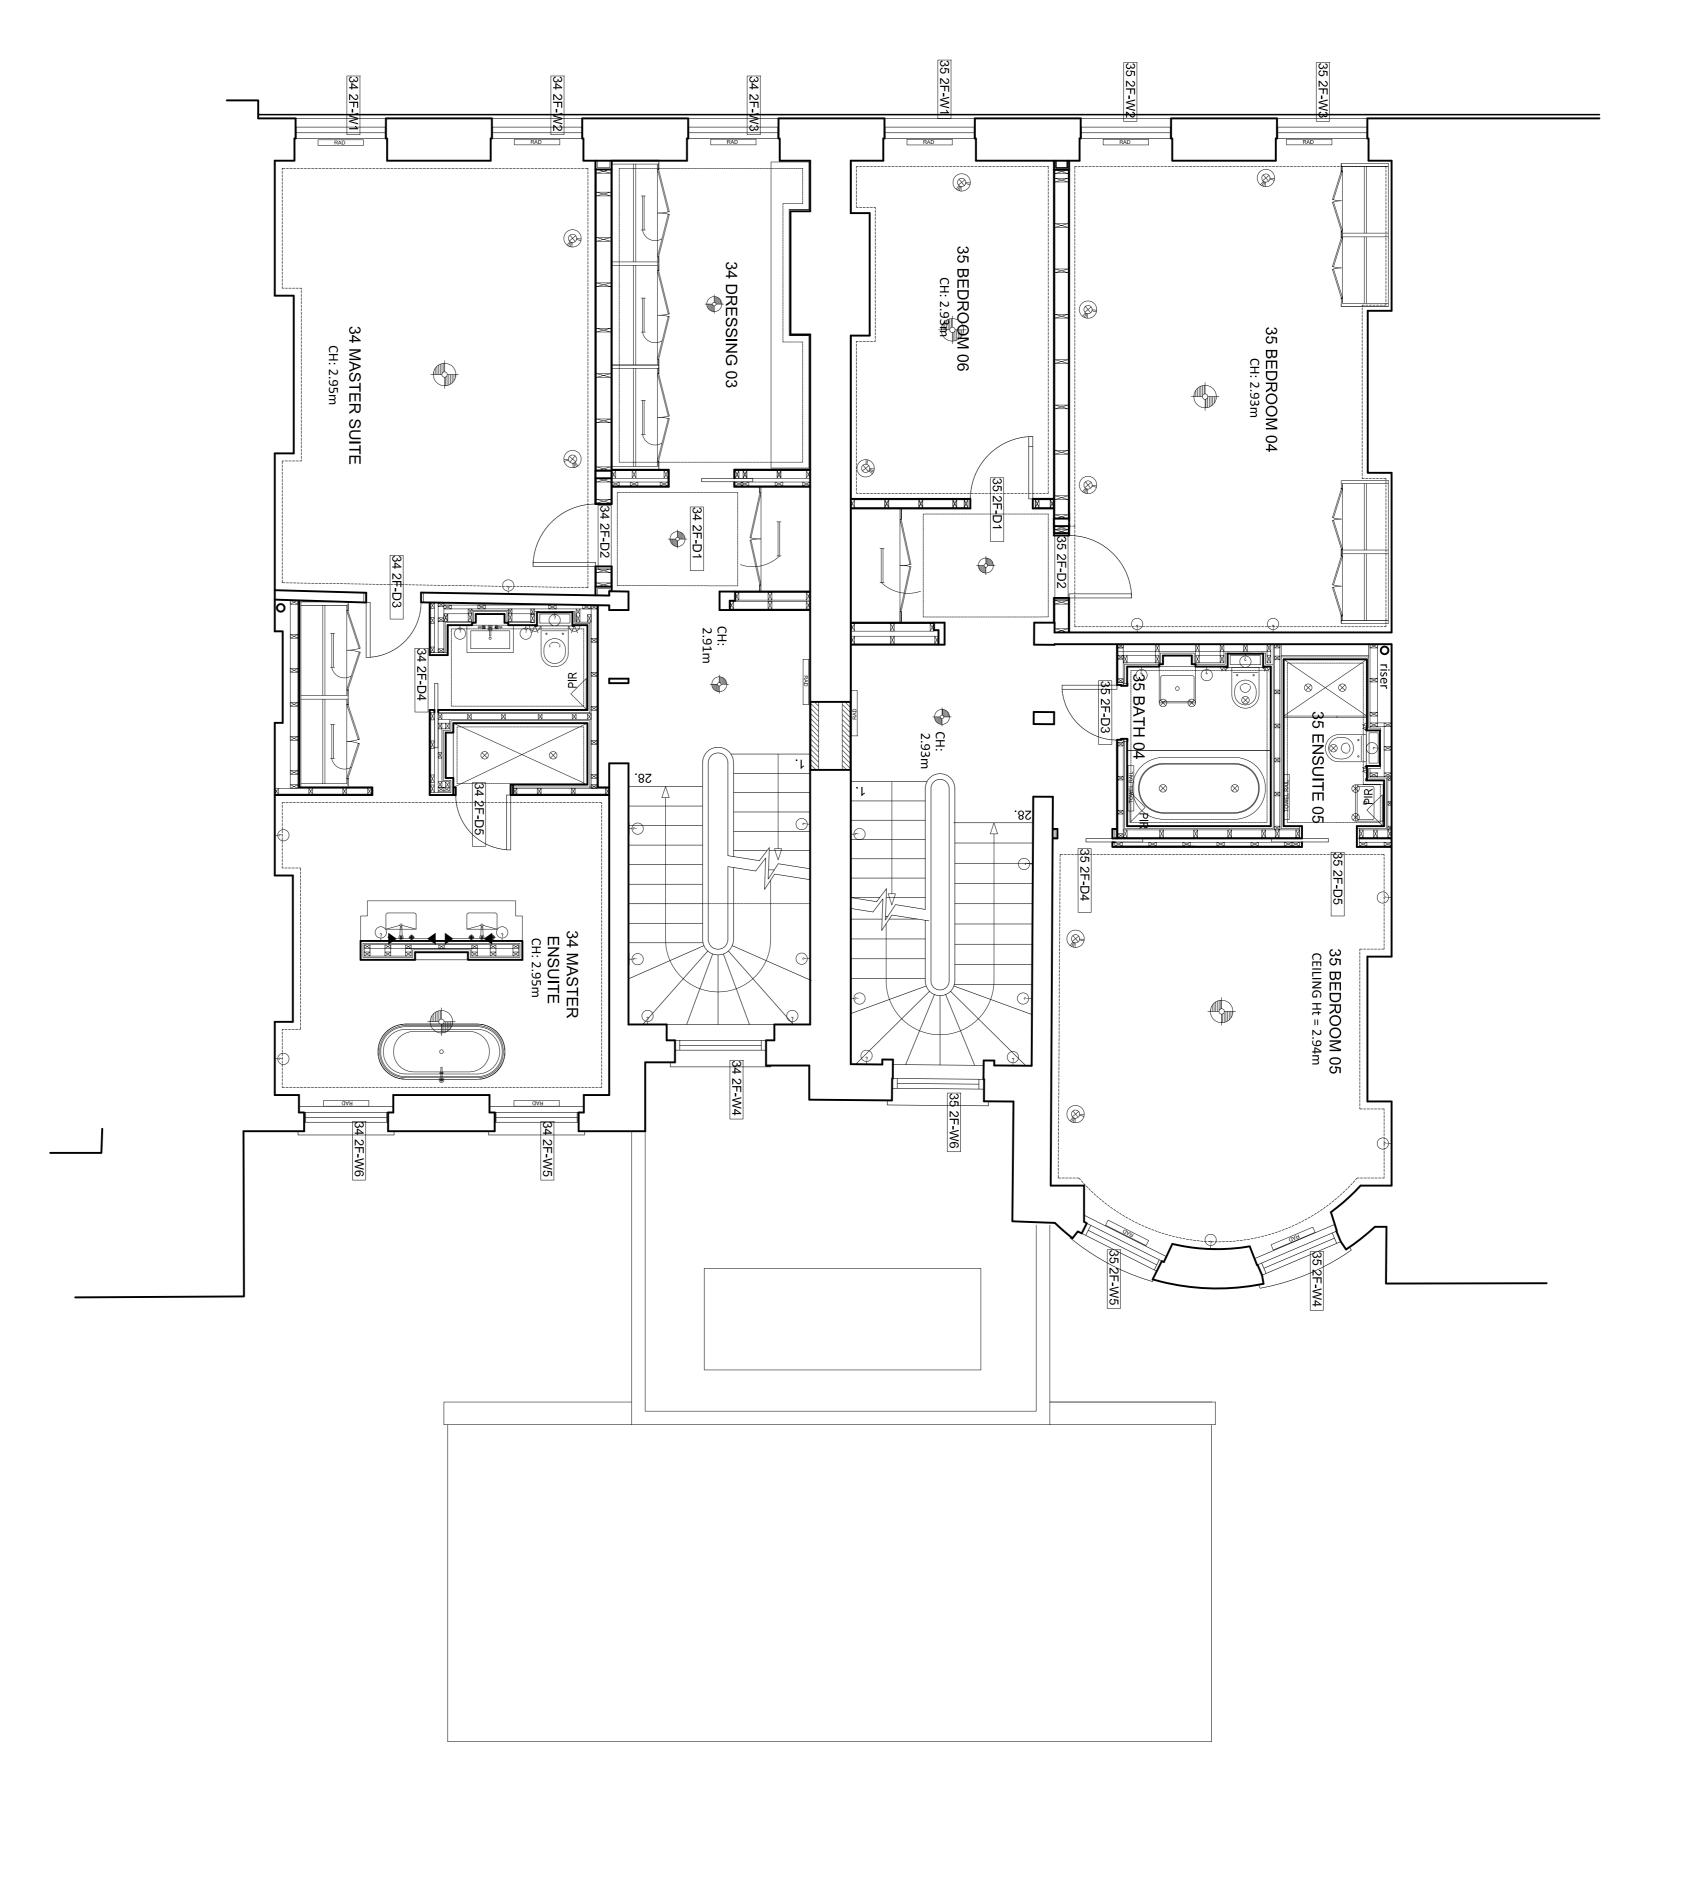

GENERAL NOTES:

DRAWINGS TO BE READ IN CONJUNCTION
WITH: SCHEDULE OF EXISTING
CONDITIONS,DETAIL DRAWINGS,
STATEMENTS AND SPECIALIST REPORTS.
ALL EXISTING CORNICES ARE RETAINED
AND REPAIRED WHERE REQUIRED. FOR
NEW CORNICES SEE SCHEDULE.

LIGHTING KEY

DOWNLIGHT

TABLE LIGHT

№ 10 № 8

WALL MOUNTED LUMINAIRE note typically mounted at 1800mm above FFL, but TBC

PENDANT LUMINAIRE

DIRECTIONAL DOWNLIGHT

PIR LIGHT

FLUORESCENT BATTEN

LIGHTING CIRCUIT— LIGHTING SPEC. BY LANDSCAPE ARCHITECT

UNDER CABINET FIXTURE — VERIFY LENGTH

LOW LEVEL LIGHT

RECESSED WALL LIGHTS

FLOOR LAMP

All dimensions and levels are to be checked on site by the main contractor prior to commencing excavation works. any discrepancy is to be reported back to the designer for instruction.

This drawing is the property of ARGENT DESIGN LIMITED and may not be reproduced or disclosed to a third party in any form without written permission


PLANNING AA PPROVED: JG PANNING: AA PPROVED: JG PANNING: AA PPROVED: JG PANNING: AA PPROVED: JG PANNING: AA PPROVED: JG PROVED: JG PRO

DESIGN LIMITED

100 GEORGE STREET
LONDON, W1 U 8NU
TELEPHONE: 020 7563 4250
FAX: 020 7563 4251
EMAIL: INFO@ARGENTDESIGN.CO.UK

PAGEZT

3435FS-2F-124 Rev. No.:

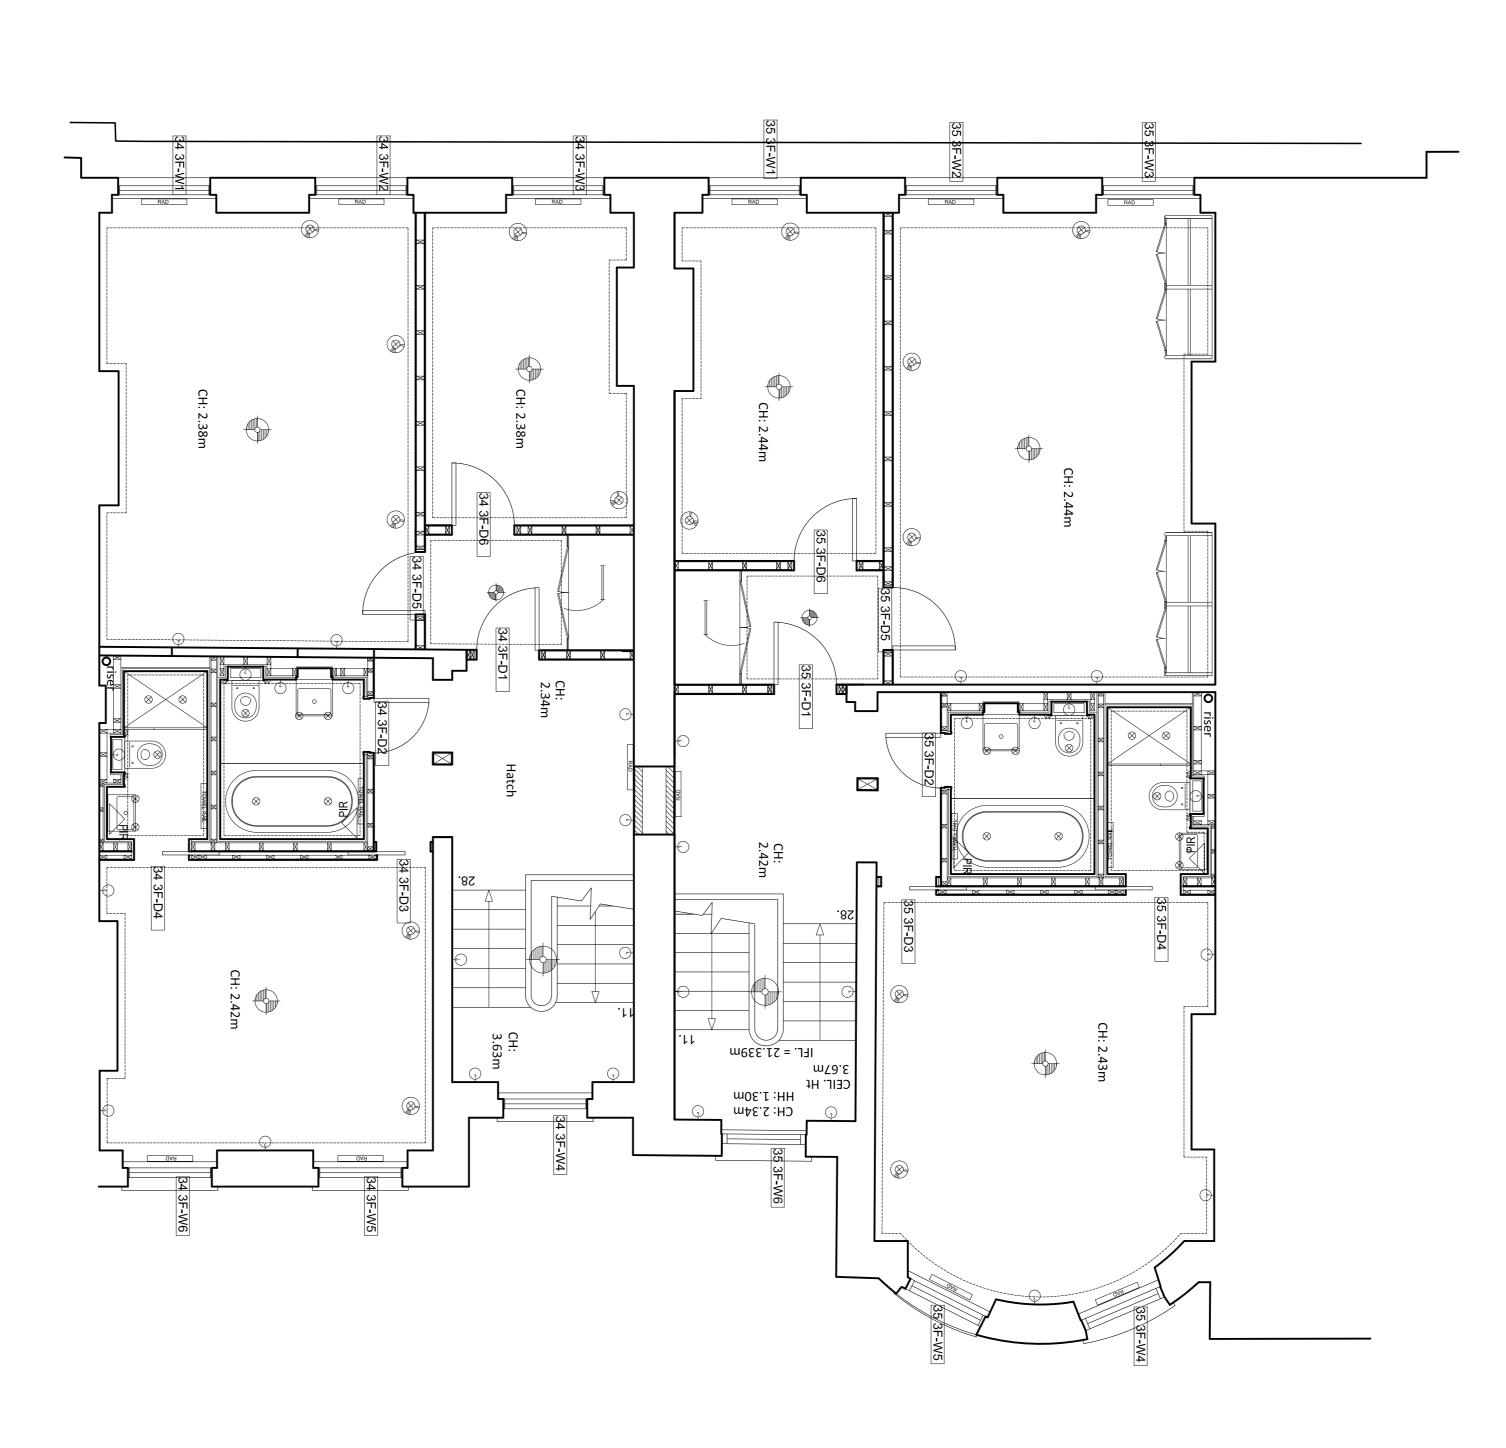

GENERAL NOTES:

DRAWINGS TO BE READ IN CONJUNCTION
WITH: SCHEDULE OF EXISTING
CONDITIONS, DETAIL DRAWINGS,
STATEMENTS AND SPECIALIST REPORTS.
ALL EXISTING CORNICES ARE RETAINED
AND REPAIRED WHERE REQUIRED. FOR
NEW CORNICES SEE SCHEDULE.

∅∅∅

DIRECTIONAL DOWNLIGHT

PENDANT LUMINAIRE

WALL MOUNTED LUMINAIRE note typically mounted at 1800mm above FFL, but TBC

LIGHT IN JOINERY / NICHE

LIGHTING CIRCUIT— LIGHTING SPEC. BY LANDSCAPE ARCHITECT

FLUORESCENT BATTEN

FLOOR LAMP

UNDER CABINET FIXTURE — VERIFY LENGTH

LOW LEVEL LIGHT

RECESSED WALL LIGHTS

 $\Theta \otimes \Theta$

TABLE LIGHT

LIGHTING KEY

All dimensions and levels are to be checked on site by the main contractor prior to commencing excavation works. any discrepancy is to be reported back to the designer for instruction.

This drawing is the property of ARGENT DESIGN LIMITED and may not be reproduced or disclosed to a third party in any form without written permission

PLANNING PLANNING PLANNING PLANNING A35 FITZROY SQUARE 34.35 FITZROY SQUARE 34.35 FITZROY SQUARE 34.35 FITZROY SQUARE PARGE 2010-06-25 Promotes A4 PARGE NIT 125 Promotes STREET PESIGN LIMITED 1 DD GEDRAGE STREET PERSON DES 7560 4-260 TOLIFONOR CROSS 7560 4-260 TOLIFONOR CROSS 7560 4-260 FRAN I DATE DOLIFON DISC.