
Fitzroy Street

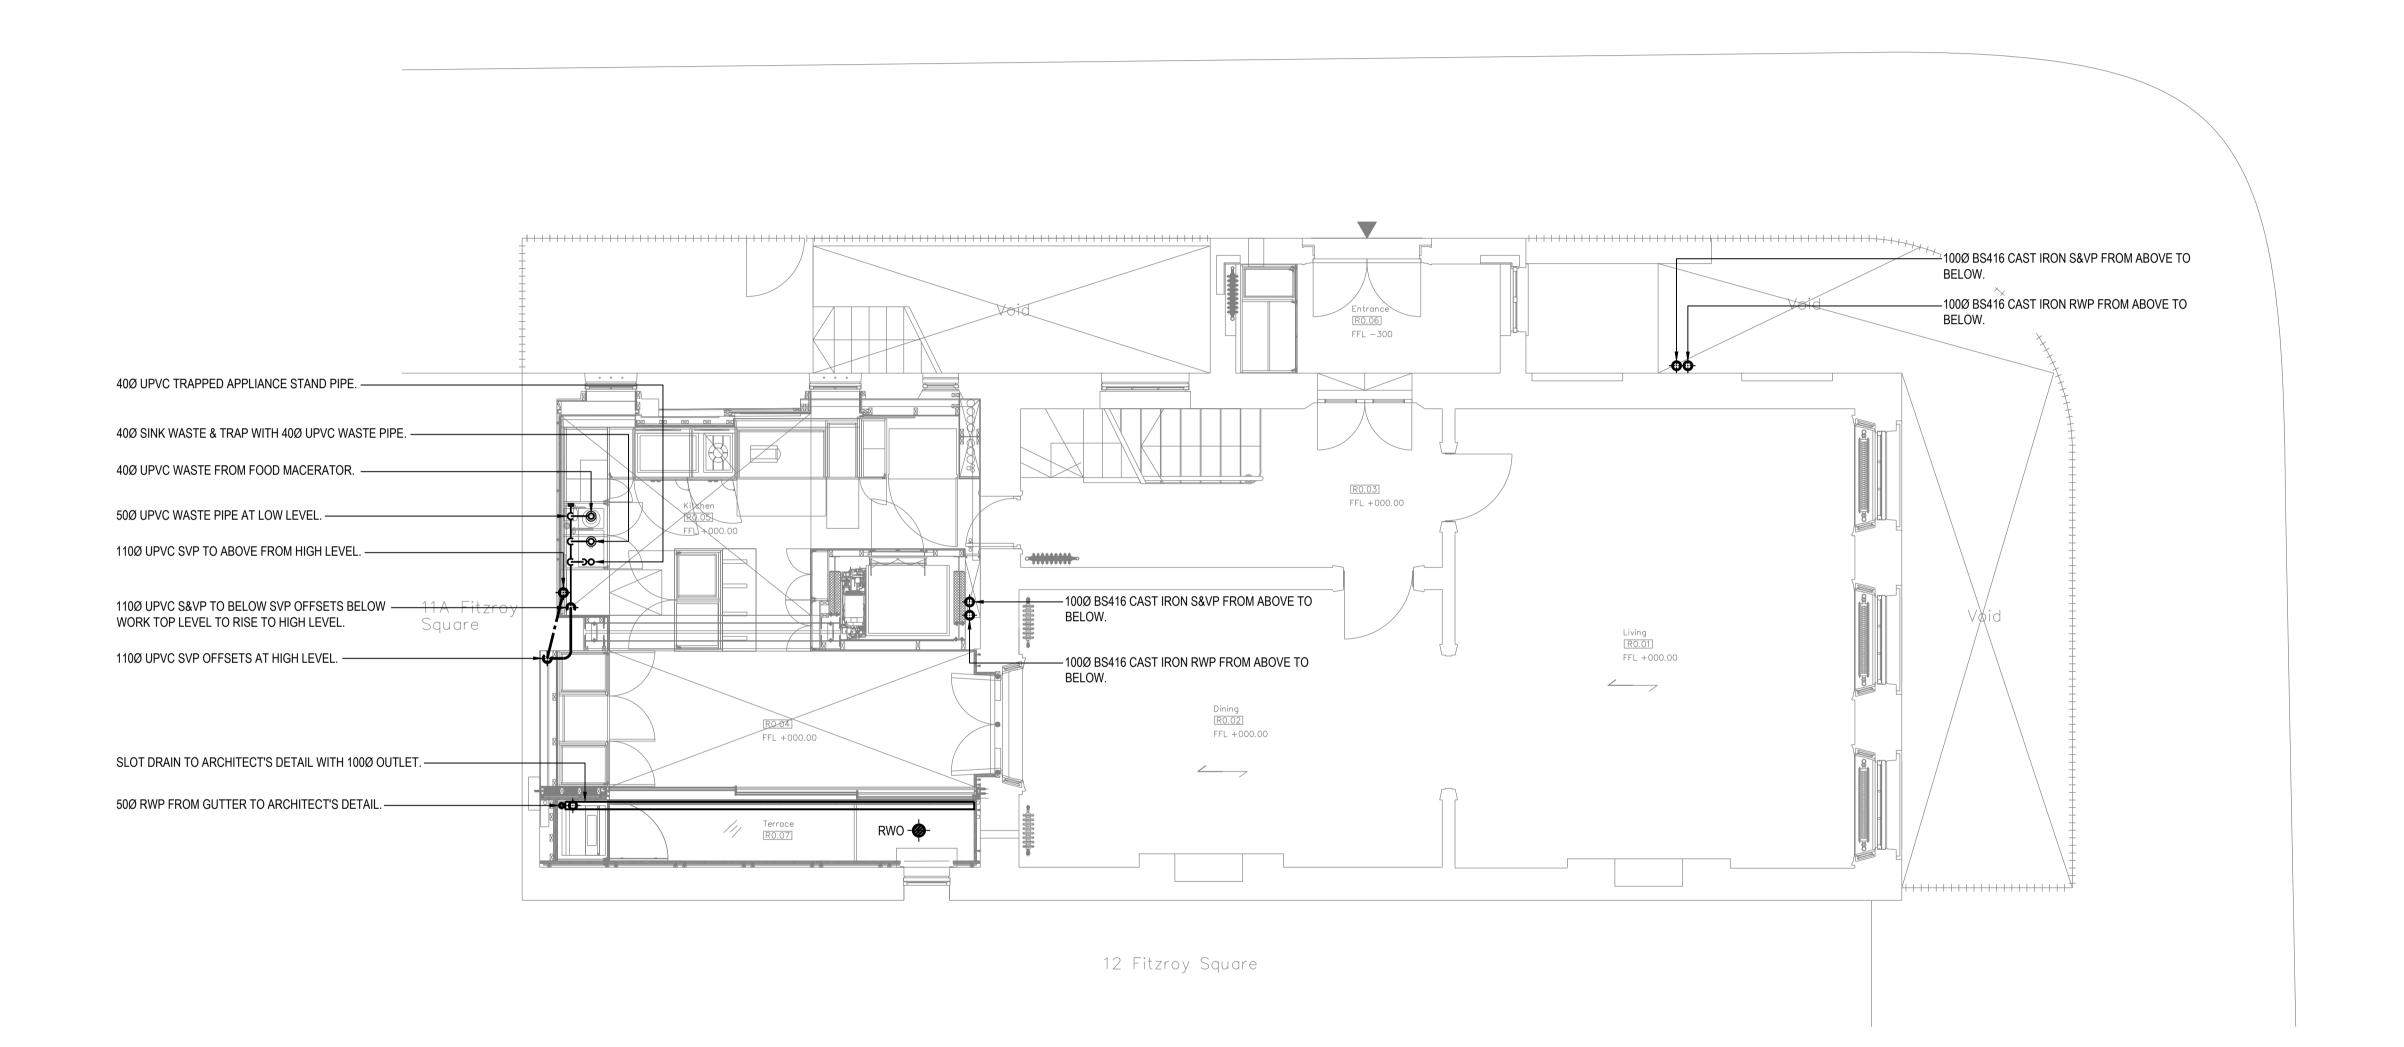


Cadfile Data: 3128/PH/02 (1:50@A1) Date: APRIL 2013 THIS DRAWING SHALL BE READ IN CONJUNCTION WITH THE SPECIFICATION FOR PUBLIC HEALTH SERVICES INSTALLATION AND ALL ASSOCIATED PUBLIC HEALTH DRAWINGS LISTED THEREIN. 2. ALL PUBLIC HEALTH SERVICES DRAWINGS SHALL BE READ IN CONJUNCTION WITH ALL ASSOCIATED ARCHITECTURAL, STRUCTURAL, MECHANICAL AND ELECTRICAL SERVICES DRAWINGS. 3. THE CONTRACTOR SHALL CHECK AND VERIFY ALL

DIMENSIONS ON SITE PRIOR TO COMMENCING

CONSTRUCTION.

<u>NOTES</u>

P1 AUG 14 FOR PLANNING REV. DATE DESCRIPTION

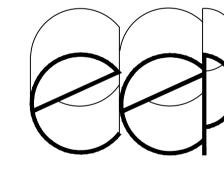

ENVIRONMENTAL ENGINEERING PARTNERSHIP CONSULTING ENGINEERS

The Chapel House, High Street, West Wycombe, Buckinghamshire. HP14 3AG
United Kingdom
Telephone: +44 (0)1494 464544
Facsimile: +44 (0)1494 464282
E-mail: consulting@eep.co.uk

RICHARD & JUDITH GREER 11 FITZROY SQUARE LONDON **GROUND FLOOR** SOIL, WASTE, VENTILATING & RAINWATER DRAINAGE LAYOUT DRAWN

1:50@A1 M.S. CHECKED APRIL 2013 DRAWING No. REVISION

3128/PH/02