
Fitzroy Street

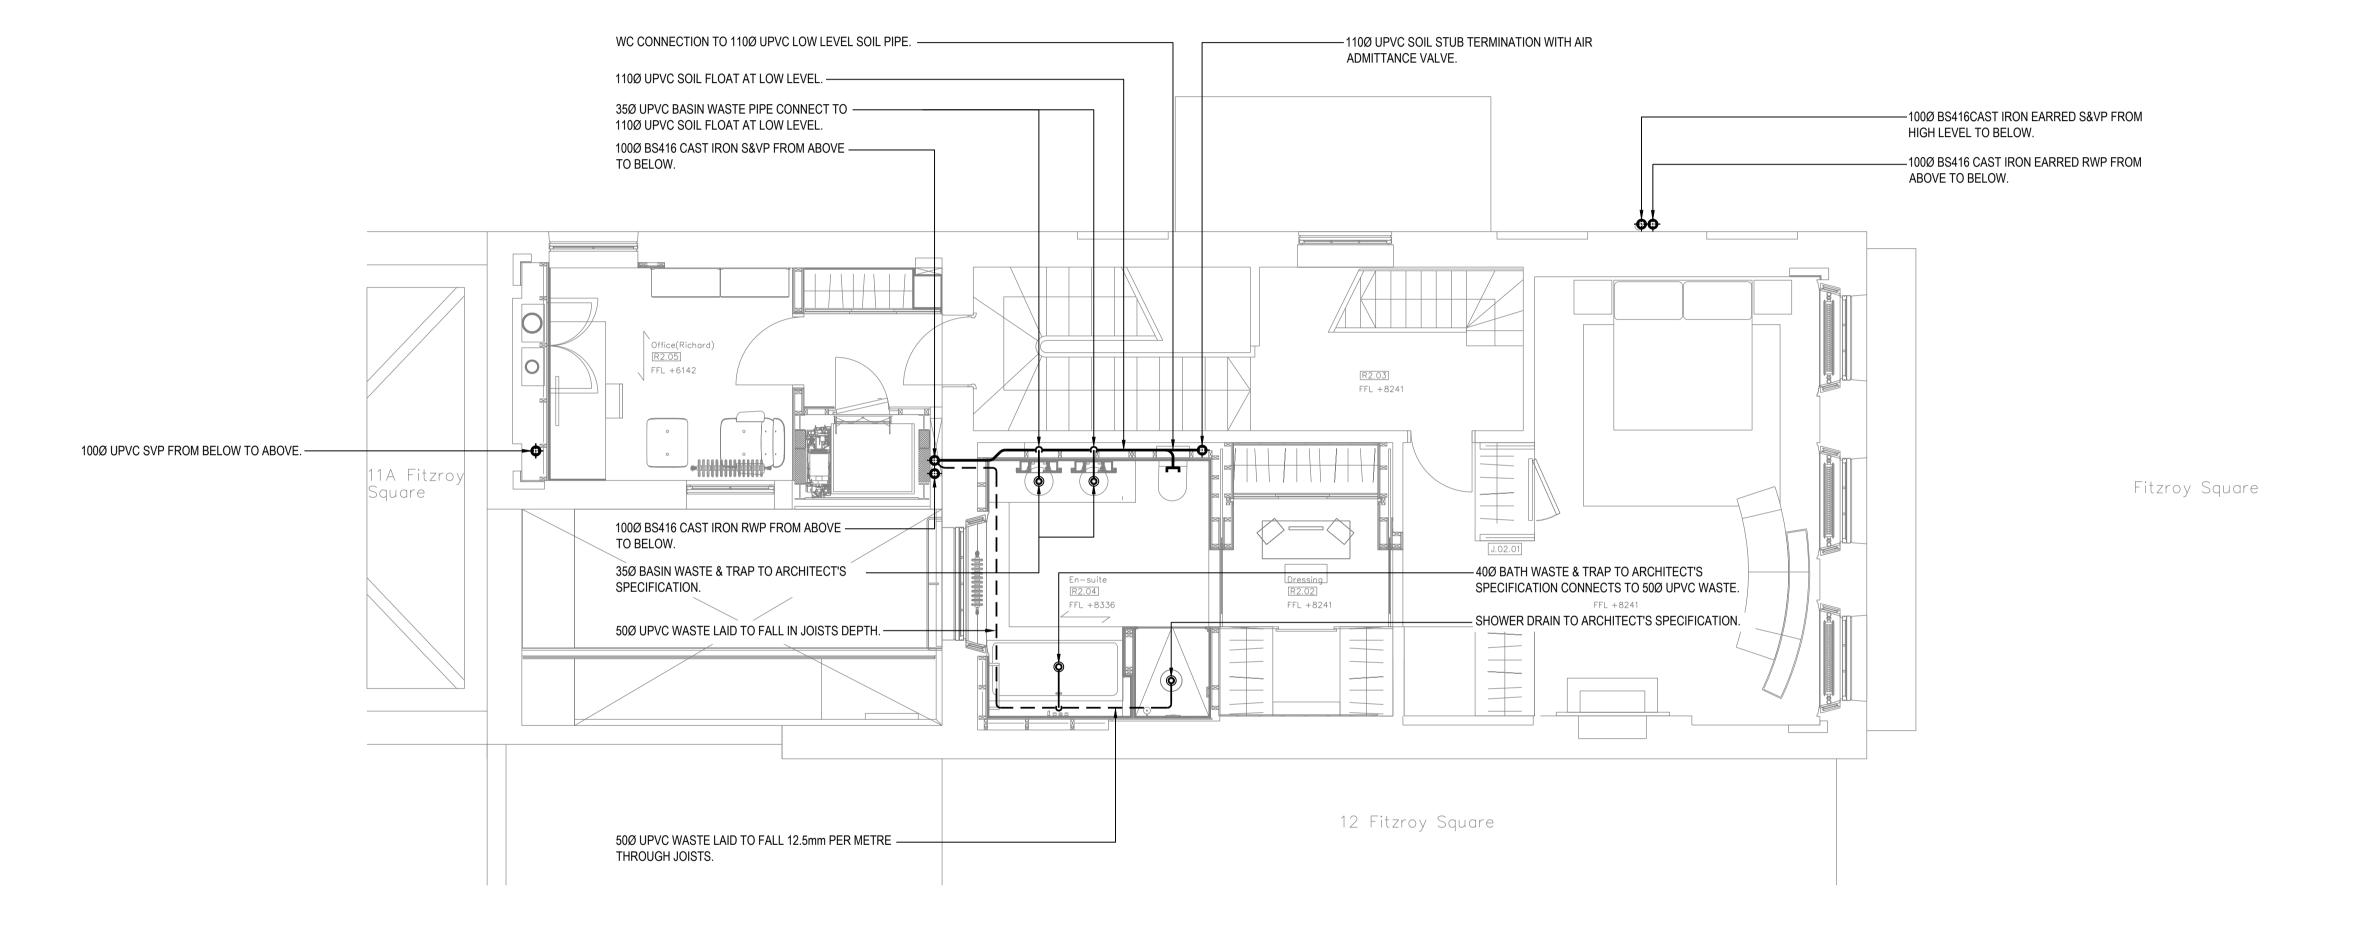


Cadfile Data: 3128/PH/04 (1:50@A1) Date: APRIL 2013

<u>NOTES</u>

- THIS DRAWING SHALL BE READ IN CONJUNCTION WITH THE SPECIFICATION FOR PUBLIC HEALTH SERVICES INSTALLATION AND ALL ASSOCIATED PUBLIC HEALTH DRAWINGS LISTED THEREIN.
- 2. ALL PUBLIC HEALTH SERVICES DRAWINGS SHALL BE READ IN CONJUNCTION WITH ALL ASSOCIATED ARCHITECTURAL, STRUCTURAL, MECHANICAL AND ELECTRICAL SERVICES DRAWINGS.
- 3. THE CONTRACTOR SHALL CHECK AND VERIFY ALL DIMENSIONS ON SITE PRIOR TO COMMENCING CONSTRUCTION.

P1 AUG 14 FOR PLANNING REV. DATE

DESCRIPTION

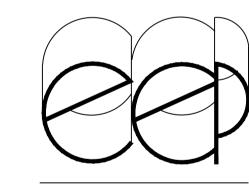

ENVIRONMENTAL ENGINEERING PARTNERSHIP CONSULTING ENGINEERS

The Chapel House, High Street, West Wycombe, Buckinghamshire. HP14 3AG United Kingdom
Telephone: +44 (0)1494 464544
Facsimile: +44 (0)1494 464282
E-mail: consulting@eep.co.uk

RICHARD & JUDITH GREER

11 FITZROY SQUARE LONDON

TITLE

SECOND FLOOR SOIL, WASTE, VENTILATING & RAINWATER DRAINAGE LAYOUT

REVISION

DRAWN		SCALE		
	M.S.		1:50(@A1
CHECKED		DATE		
	R.D.		APRIL	2013
DRAWING No.				REVISIO

3128/PH/04