

Do not scale-off this drawing. SC Ltd take no responsibility for any dimensions obtained by measuring or scaling from this drawing and no reliance may be placed on such dimensions. If no dimension is given, it is the responsibility of the recipient to ascertain the dimension specifically from the Architect or by site measurement. The sizing of all structural and service elements must always be checked against the relevant engineers drawings. No reliance should be placed upon sizing information shown on this drawing.

SAFETY HEALTH AND ENVIRONMENTAL INFORMATION
 BOX - See Health and Safety Risk Register


In addition to the hazards / risks normally associated with the types of work detailed on this drawing, TAKE NOTE OF THE RISKS BELOW. It is assumed that all works on this drawing will be carried out by a competent contractor working, where appropriate, to an approved method statement.

NOTE:

-This drawings is to be read in conjunction with all other relevant drawings and specifications

LEGEND

-  MRX BOX (NU-AIRE MRXBOX95B-LPT)
-  SUPPLY DUCT
-  EXTRACT DUCT

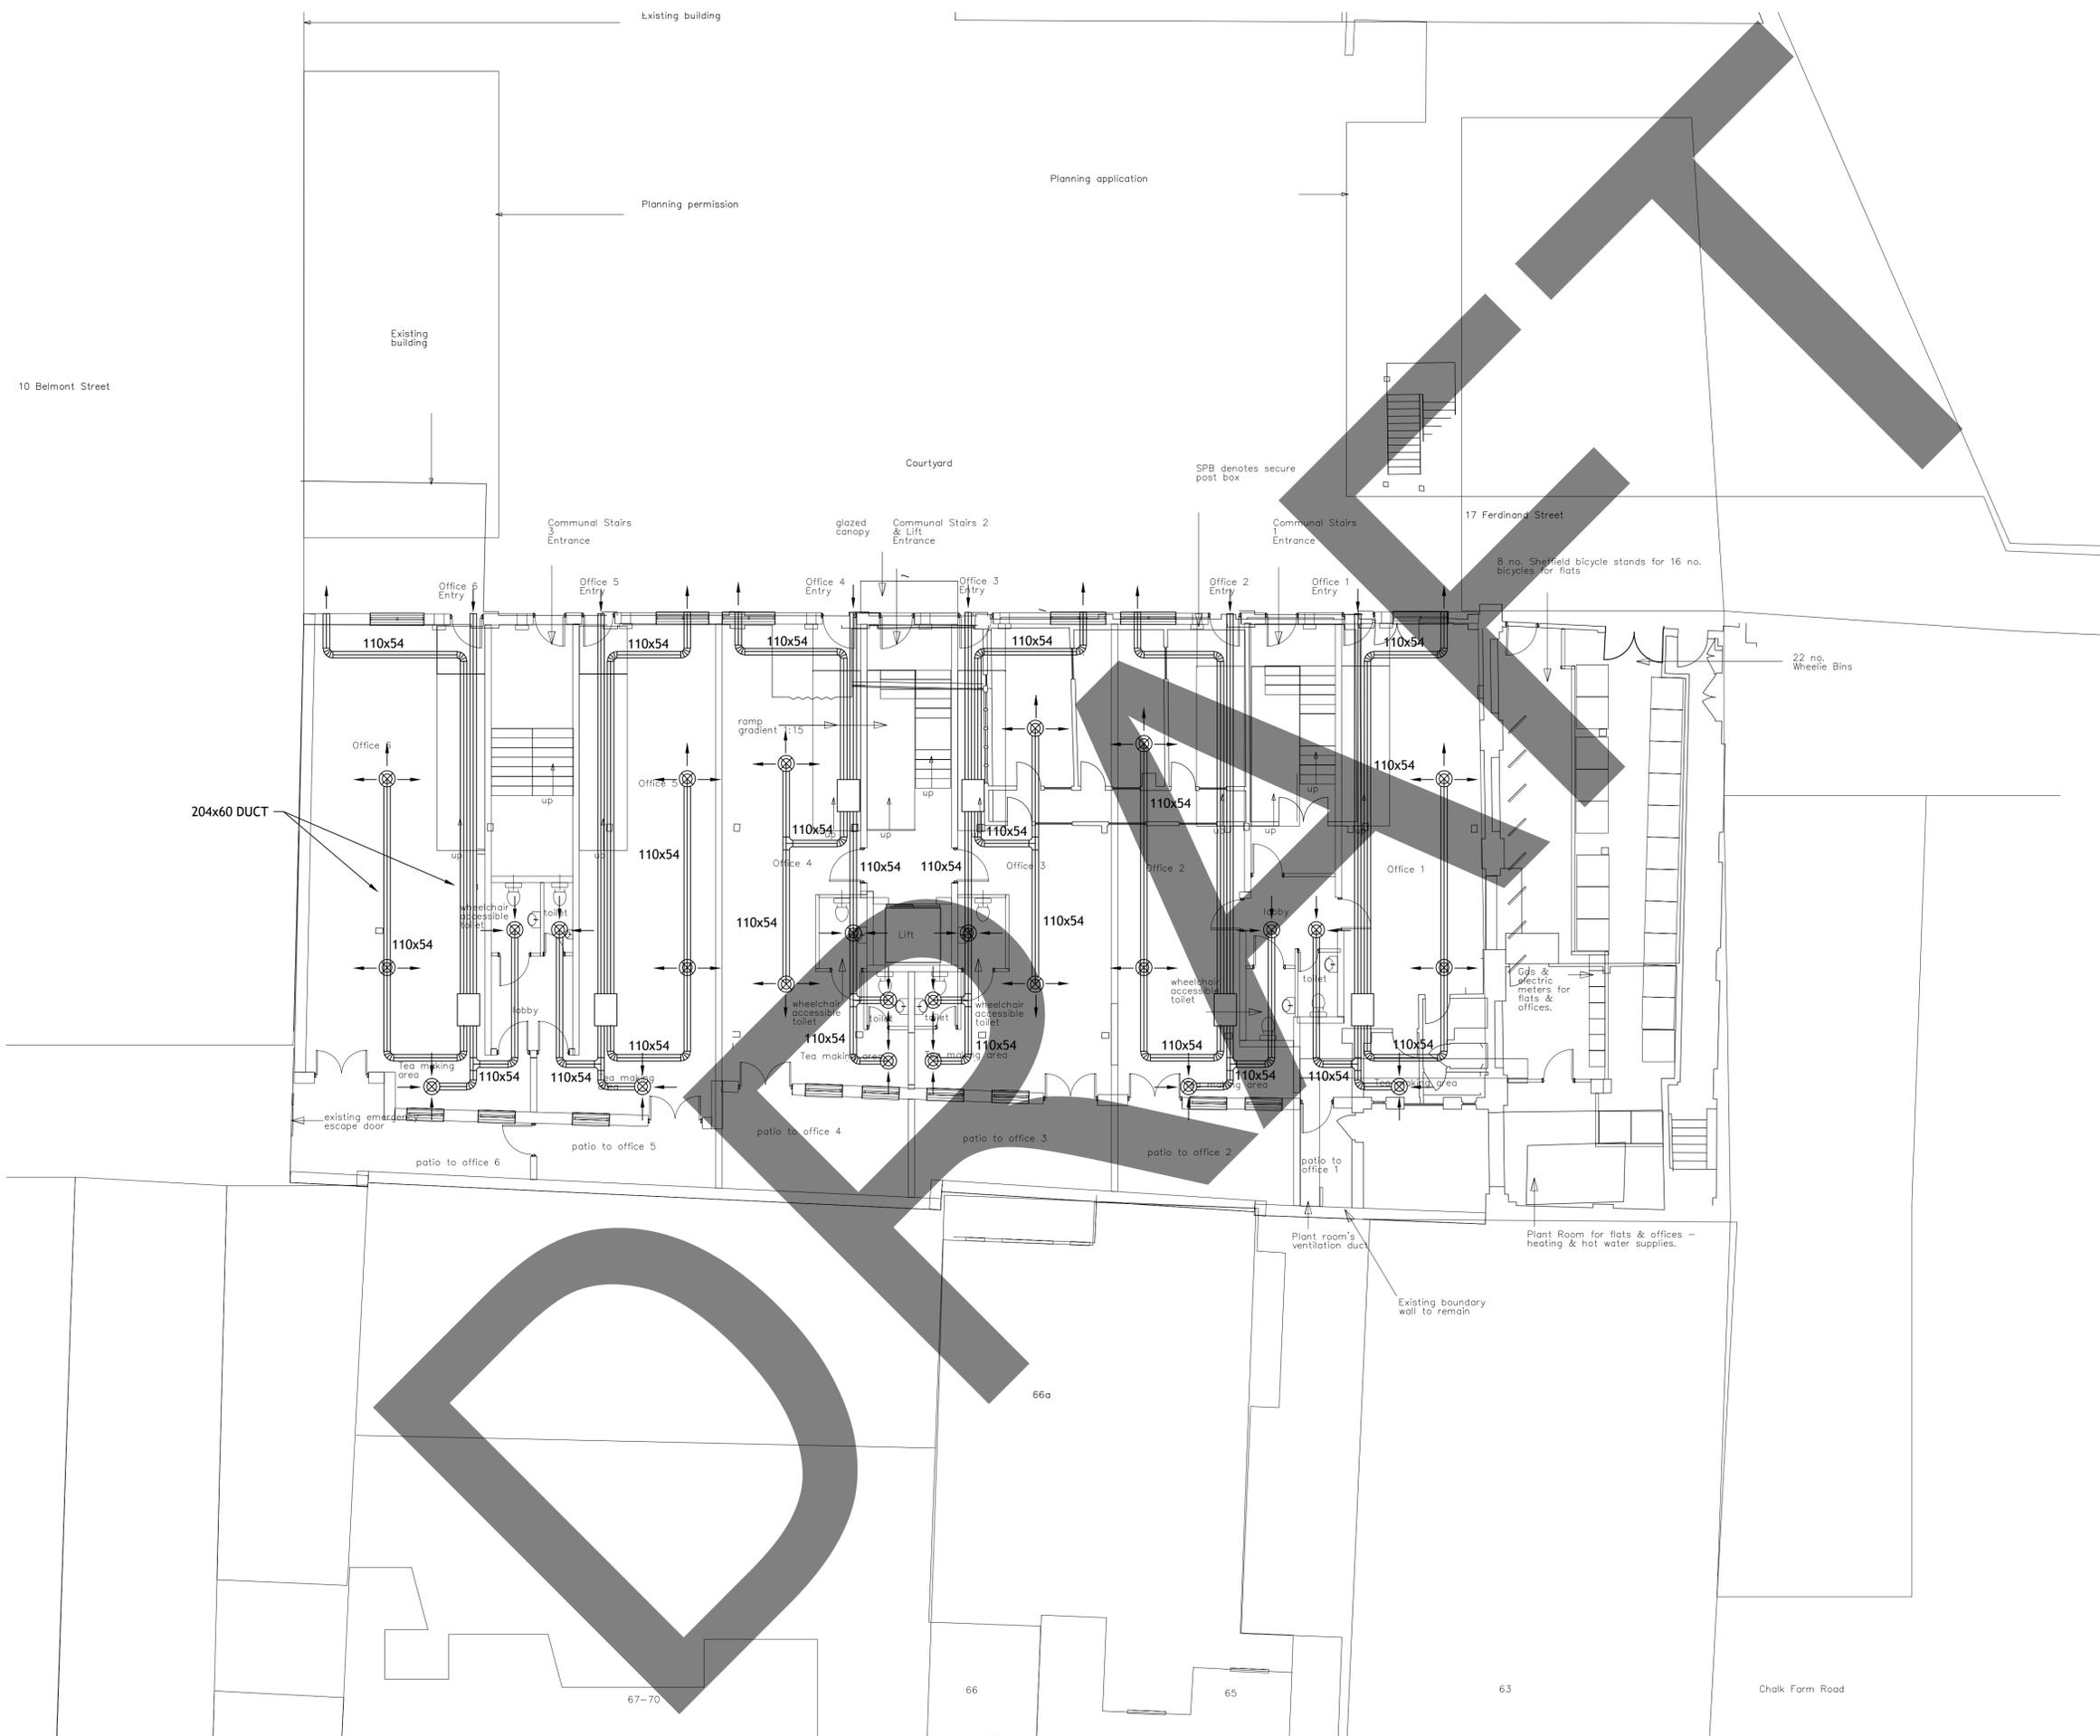

FOR INFORMATION		
SyntegraConsulting		
<small>Syntegra House, 63 Milford Road, Reading, RG1 8LG mail@syntegra-epc.co.uk www.syntegra-epc.co.uk</small>		
Client:	17-19 Ferdinand Street	
Project:	17-19 Ferdinand Street	
Title:	VENTILATION LAYOUT - Ground Floor	
By: JS	Chkd: AWK	Date: 12/06/2015
Sheet: -	Scale: 1:100 @A1	
Dwg. No. V01	Rev. -	

Do not scale-off this drawing. SC Ltd take no responsibility for any dimensions obtained by measuring or scaling from this drawing and no reliance may be placed on such dimensions. If no dimension is given, it is the responsibility of the recipient to ascertain the dimension specifically from the Architect or by site measurement. The sizing of all structural and service elements must always be checked against the relevant engineers drawings. No reliance should be placed upon sizing information shown on this drawing.

SAFETY HEALTH AND ENVIRONMENTAL INFORMATION
 BOX - See Health and Safety Risk Register

In addition to the hazards / risks normally associated with the types of work detailed on this drawing, TAKE NOTE OF THE RISKS BELOW. It is assumed that all works on this drawing will be carried out by a competent contractor working, where appropriate, to an approved method statement.

NOTE:

-This drawings is to be read in conjunction with all other relevant drawings and specifications

LEGEND

-  MRX BOX (NU-AIRE MRXBOX95B-LPT)
-  SUPPLY DUCT
-  EXTRACT DUCT

BATHROOM EXTRACT FAN SCHEDULE							
REF	LOCATION	EXTRACT AIR VOL/SYSTEM RESILIENCE	ELECTRICAL SUPPLY	POWER (MAX W)	CONTROL	MODEL REF	MANUFACTURER
TEF-01	BATHROOM	0-022m ³ /SV 100Pa	230v/1PH/50Hz	30	LIGHT SWITCH / C/W PULL CORD / ADJUSTABLE 2 WAY GANGS / RUN ON TIMER	CYFAN-C SEMI-RECESSED /WALL MOUNTED	NUAIRE
TEF-02	KITCHEN	424m ³ /hr	/	60	4 POSITION SWITCH TO PROVIDE 14-33 l/s CONTINUOUSLY WITH BOOST TO 47 l/s	COOKERHOOD SS	NUAIRE

ALL EXTRACT FANS TO BE LOCATED AT A MINIMUM OF 300mm AWAY FROM ANY OPENINGS



FOR INFORMATION			
SyntegraConsulting			
<small>Syntegra House, 63 Milford Road, Reading, RG1 8LG mail@syntegra-epc.co.uk www.syntegra-epc.co.uk</small>			
Client:		17-19 Ferdinand Street	
Project:		17-19 Ferdinand Street	
Title: VENTILATION LAYOUT - First Floor			
By: JS	Chkd: AWK	Date: 12/06/2015	
Sheet: -	Scale: 1:100 @A1		
Dwg. No. V02	Rev. -		

Do not scale-off this drawing. SC Ltd take no responsibility for any dimensions obtained by measuring or scaling from this drawing and no reliance may be placed on such dimensions. If no dimension is given, it is the responsibility of the recipient to ascertain the dimension specifically from the Architect or by site measurement. The sizing of all structural and service elements must always be checked against the relevant engineers drawings. No reliance should be placed upon sizing information shown on this drawing.

SAFETY HEALTH AND ENVIRONMENTAL INFORMATION
 BOX - See Health and Safety Risk Register

In addition to the hazards / risks normally associated with the types of work detailed on this drawing, TAKE NOTE OF THE RISKS BELOW. It is assumed that all works on this drawing will be carried out by a competent contractor working, where appropriate, to an approved method statement.

NOTE:


-This drawings is to be read in conjunction with all other relevant drawings and specifications

LEGEND

-  MRX BOX (NU-AIRE MRXBOX95B-LPT)
-  SUPPLY DUCT
-  EXTRACT DUCT

BATHROOM EXTRACT FAN SCHEDULE							
REF	LOCATION	EXTRACT AIR VOL/SYSTEM RESILIENCE	ELECTRICAL SUPPLY	POWER (MAX W)	CONTROL	MODEL REF	MANUFACTURER
TEF-01	BATHROOM	0-022m ³ /SV 100Pa	230v/1PH/50Hz	30	LIGHT SWITCH / C/W PULL CORD / ADJUSTABLE 2 WAY GANGS / RUN ON TIMER	CYFAN-C SEMI -RECESSED	NUAIRE
TEF-02	KITCHEN	424m ³ /hr	/	60	4 POSITION SWITCH TO PROVIDE 14-33 l/s CONTINUOUSLY WITH BOOST TO 47 l/s	COOKERHOOD SS	NUAIRE

ALL EXTRACT FANS TO BE LOCATED AT A MINIMUM OF 300mm AWAY FROM ANY OPENINGS

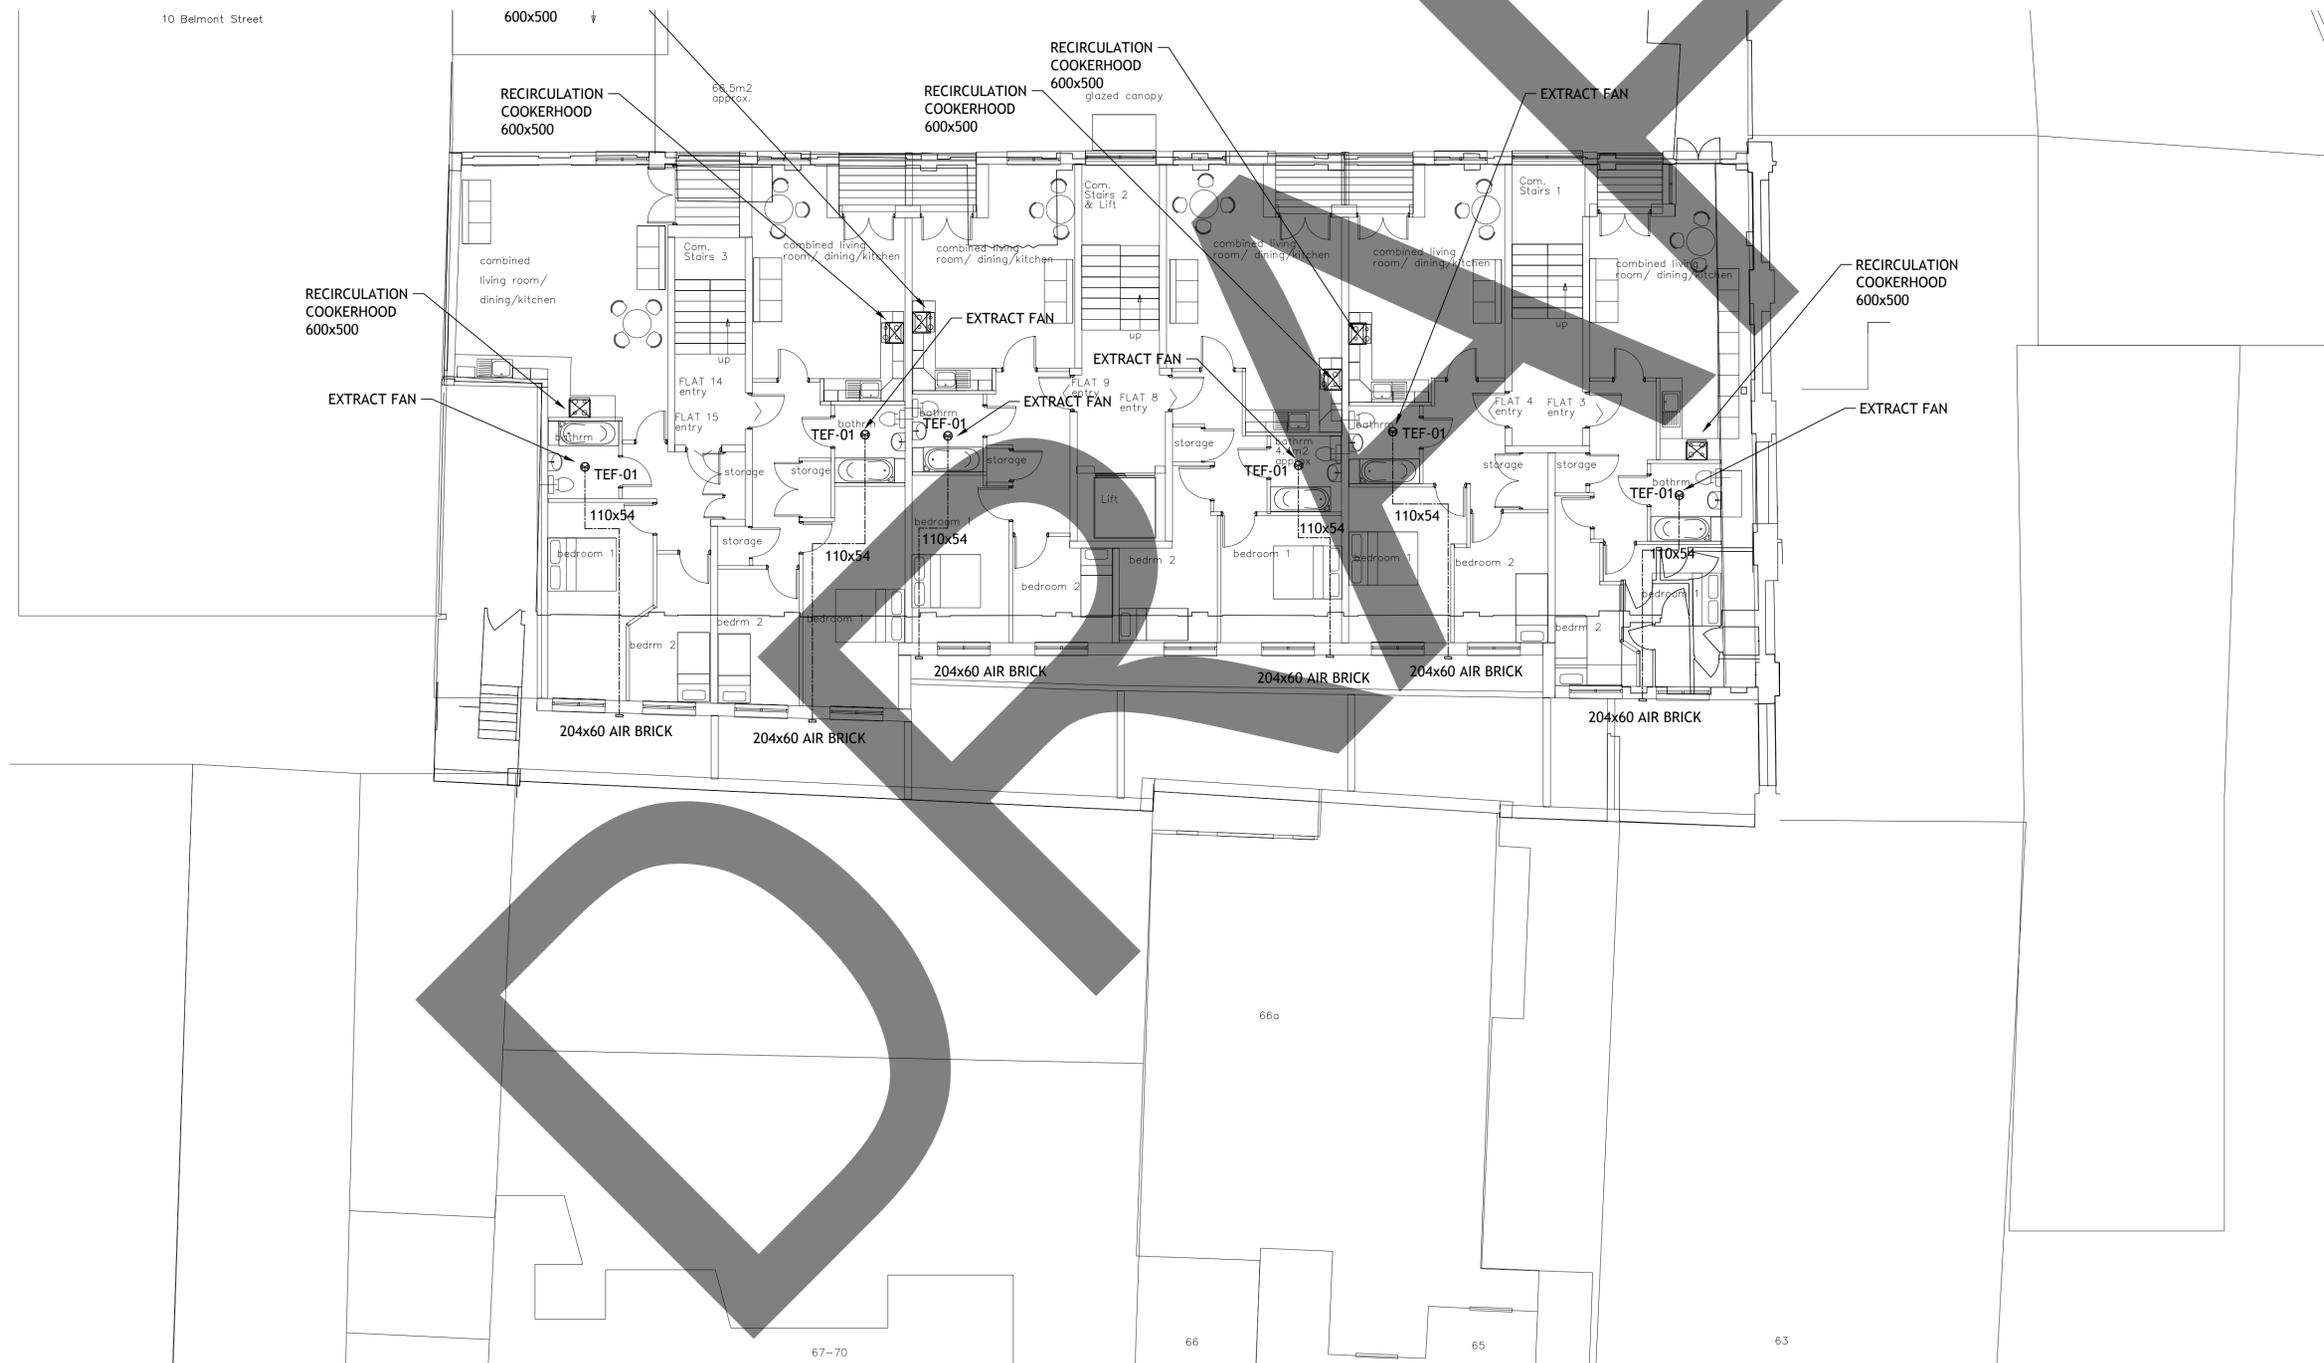

FOR INFORMATION			
SyntegraConsulting			
<small>Syntegra House, 63 Milford Road, Reading, RG1 8LG mail@syntegra-epc.co.uk www.syntegra-epc.co.uk</small>			
Client:	17-19 Ferdinand Street		
Project:	17-19 Ferdinand Street		
Title:	VENTILATION LAYOUT - Second Floor		
By: JS	Chkd: AWK	Date:	12/06/2015
Sheet: -	Scale: 1:100 @A1		
Dwg. No. V03	Rev. -		

Do not scale-off this drawing. SC Ltd take no responsibility for any dimensions obtained by measuring or scaling from this drawing and no reliance may be placed on such dimensions. If no dimension is given, it is the responsibility of the recipient to ascertain the dimension specifically from the Architect or by site measurement. The sizing of all structural and service elements must always be checked against the relevant engineers drawings. No reliance should be placed upon sizing information shown on this drawing.

SAFETY HEALTH AND ENVIRONMENTAL INFORMATION
 BOX - See Health and Safety Risk Register

In addition to the hazards / risks normally associated with the types of work detailed on this drawing, TAKE NOTE OF THE RISKS BELOW. It is assumed that all works on this drawing will be carried out by a competent contractor working, where appropriate, to an approved method statement.

NOTE:

-This drawings is to be read in conjunction with all other relevant drawings and specifications

LEGEND


□ MRX BOX (NU-AIRE MRXBOX95B-LPT)

— SUPPLY DUCT

— EXTRACT DUCT

BATHROOM EXTRACT FAN SCHEDULE							
REF	LOCATION	EXTRACT AIR VOL/SYSTEM RESILIENCE	ELECTRICAL SUPPLY	POWER (MAX W)	CONTROL	MODEL REF	MANUFACTURER
TEF-01	BATHROOM	0-022m ³ /SV 100Pa	230v/1PH/50Hz	30	LIGHT SWITCH / C/W PULL CORD / ADJUSTABLE 2 WAY GANGS / RUN ON TIMER	CYFAN-C SEMI -RECESSED	NUAIRE
TEF-02	KITCHEN	424m ³ /hr	/	60	4 POSITION SWITCH TO PROVIDE 14-33 l/s CONTINUOUSLY WITH BOOST TO 47 l/s	COOKERHOOD SS	NUAIRE

ALL EXTRACT FANS TO BE LOCATED AT A MINIMUM OF 300mm AWAY FROM ANY OPENINGS

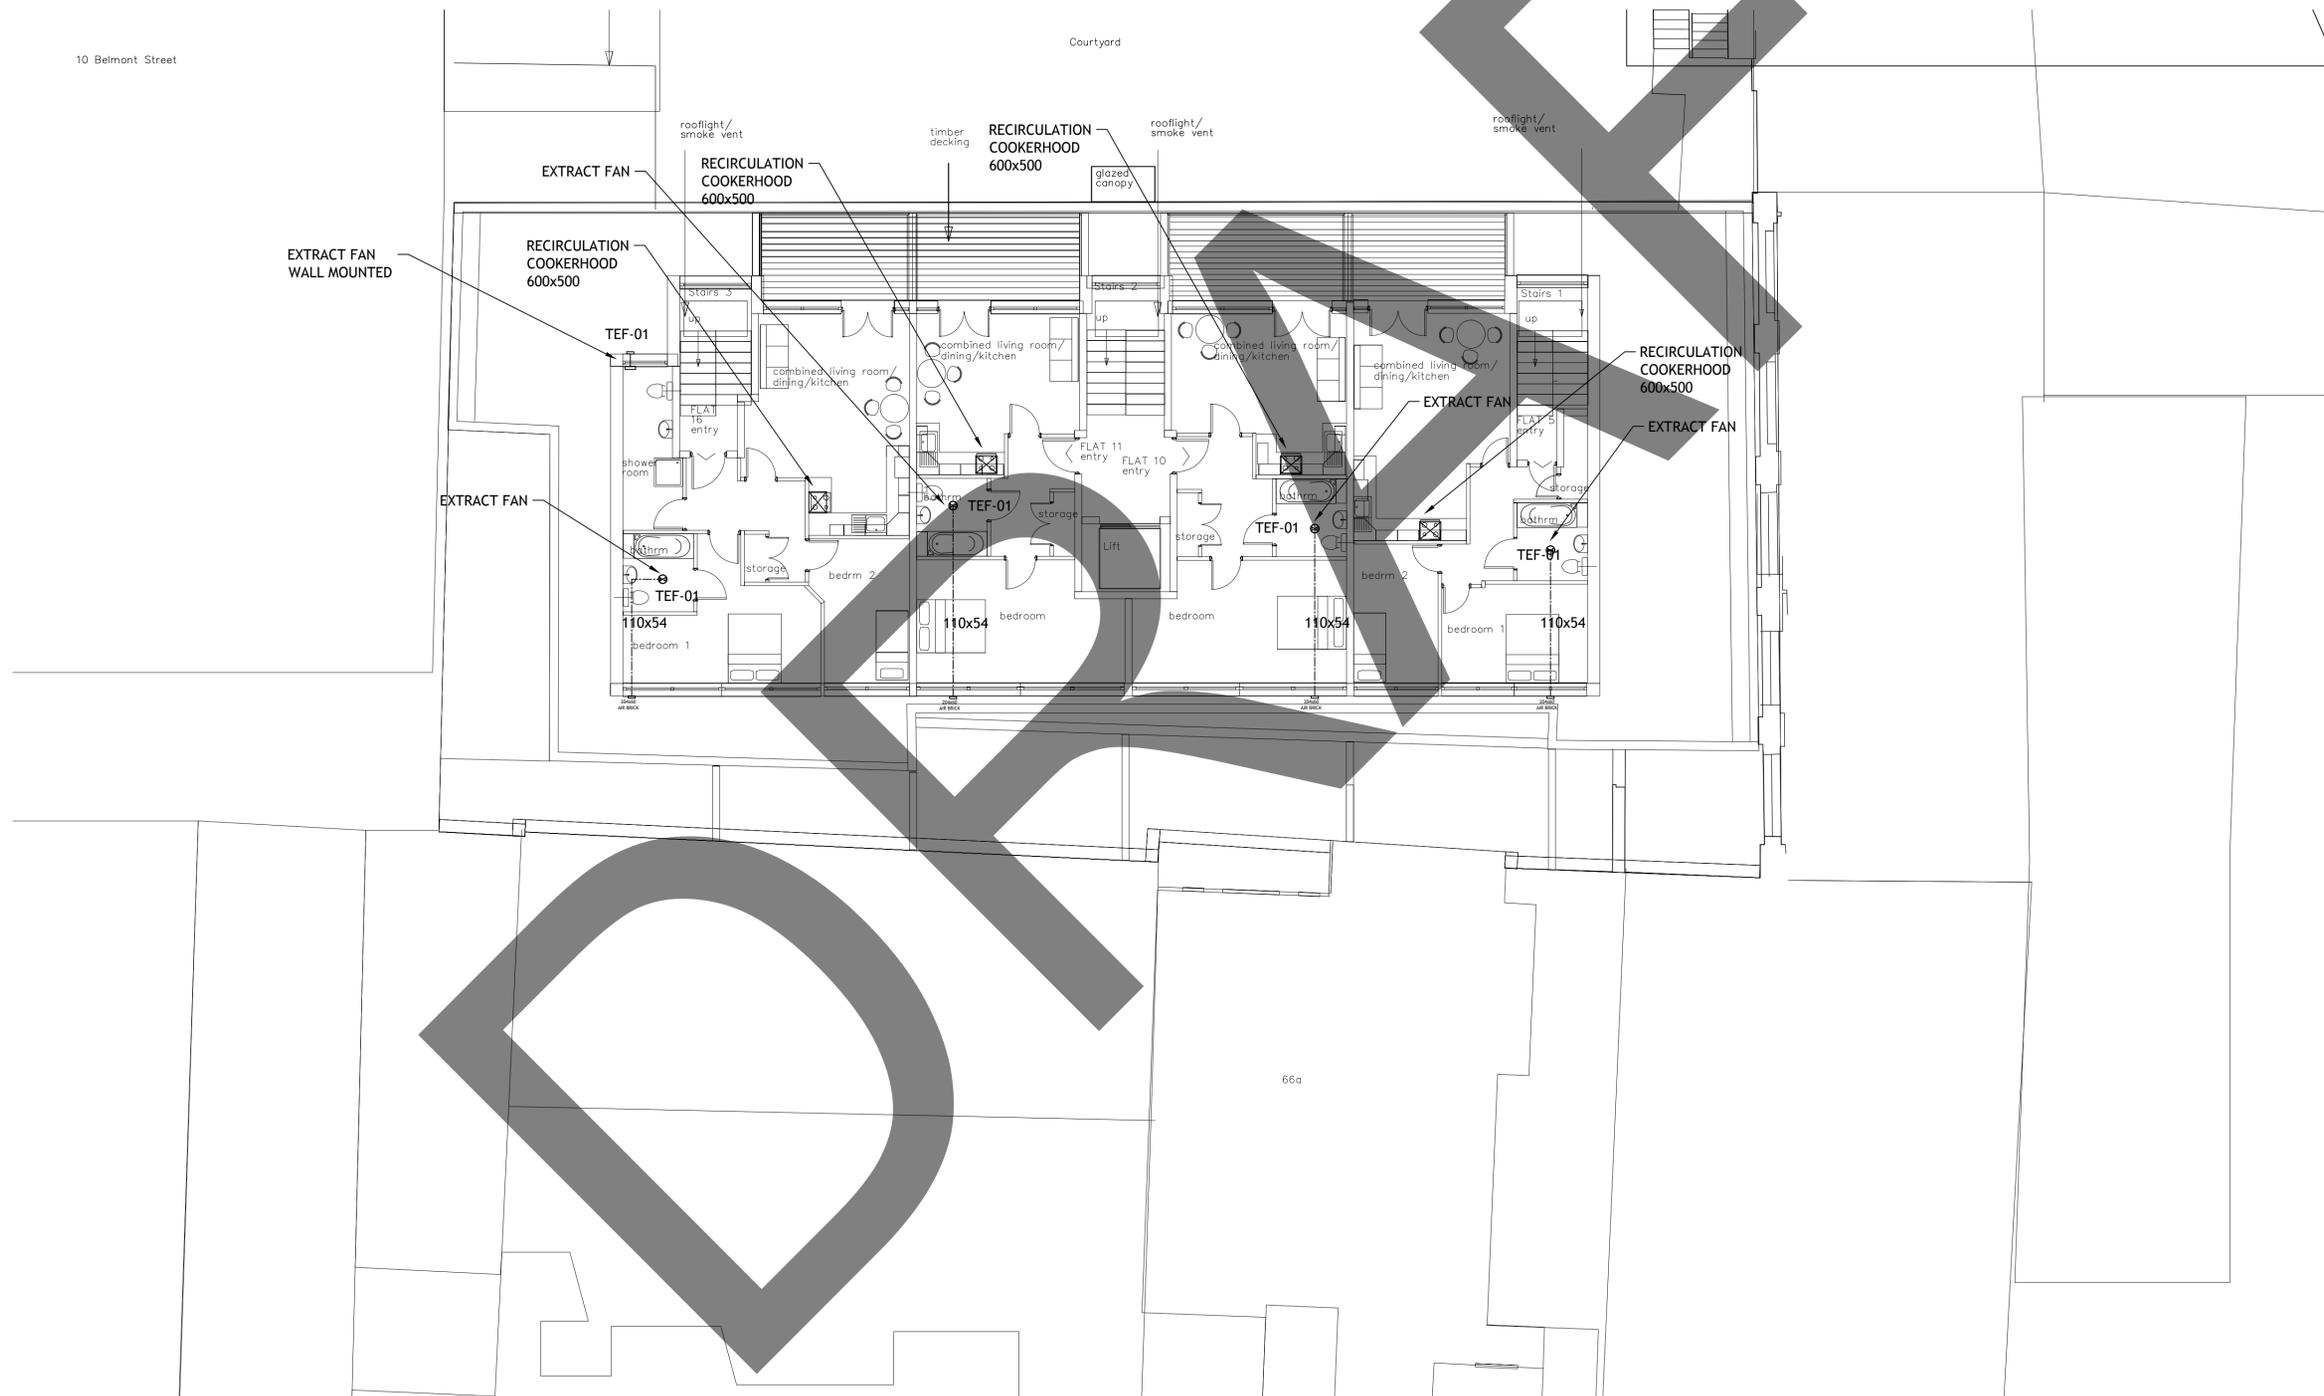

10 Belmont Street

FOR INFORMATION			
SyntegraConsulting			
<small>Syntegra House, 63 Milford Road, Reading, RG1 8LG mail@syntegra-epc.co.uk www.syntegra-epc.co.uk</small>			
Client:		17-19 Ferdinand Street	
Project:		17-19 Ferdinand Street	
Title: VENTILATION LAYOUT - Third Floor			
By: JS	Chkd: AWK	Date:	12/06/2015
Sheet: -	Scale: 1:100 @A1		
Dwg. No. V04	Rev. -		

Do not scale-off this drawing. SC Ltd take no responsibility for any dimensions obtained by measuring or scaling from this drawing and no reliance may be placed on such dimensions. If no dimension is given, it is the responsibility of the recipient to ascertain the dimension specifically from the Architect or by site measurement. The sizing of all structural and service elements must always be checked against the relevant engineers drawings. No reliance should be placed upon sizing information shown on this drawing.

SAFETY HEALTH AND ENVIRONMENTAL INFORMATION
 BOX - See Health and Safety Risk Register

In addition to the hazards / risks normally associated with the types of work detailed on this drawing, TAKE NOTE OF THE RISKS BELOW. It is assumed that all works on this drawing will be carried out by a competent contractor working, where appropriate, to an approved method statement.


NOTE:

-This drawings is to be read in conjunction with all other relevant drawings and specifications

LEGEND

-  MRX BOX (NU-AIRE MRXBOX95B-LPT)
-  SUPPLY DUCT
-  EXTRACT DUCT

10 Belmont Street

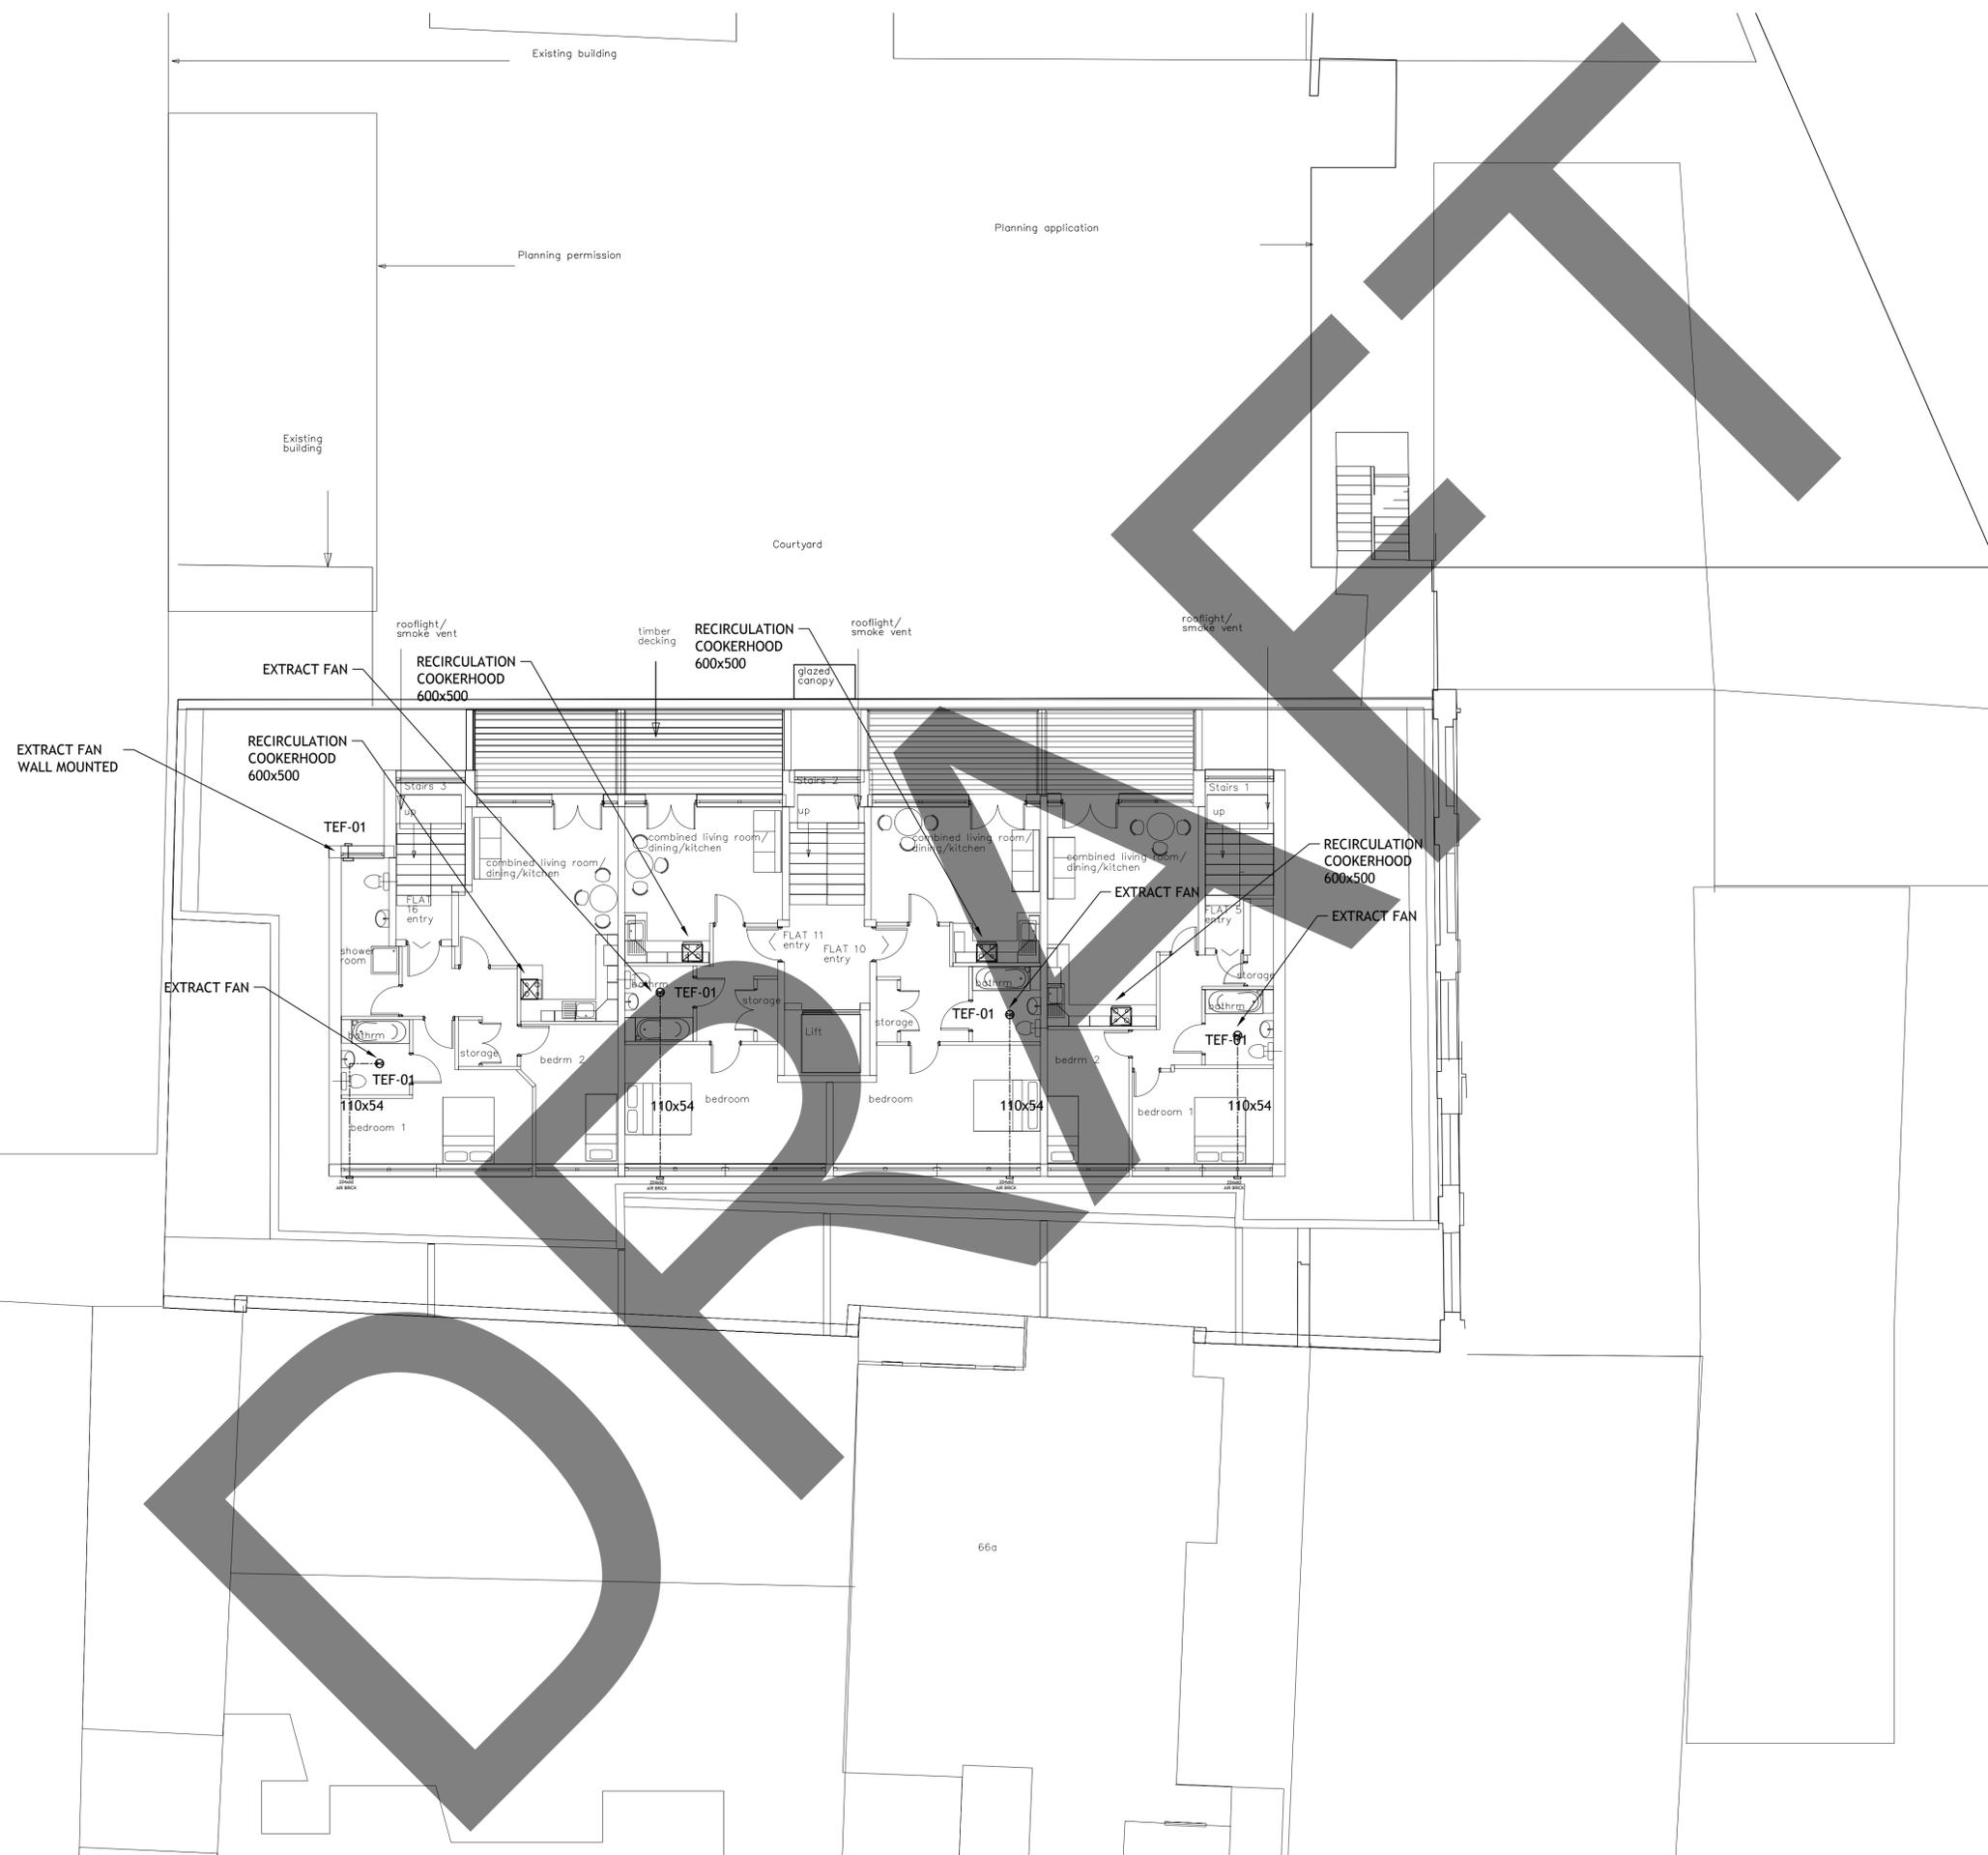

FOR INFORMATION			
SynteGraConsulting			
<small>SynteGra House, 63 Milford Road, Reading, RG1 8LG mail@syntegra-epc.co.uk www.syntegra-epc.co.uk</small>			
Client:		17-19 Ferdinand Street	
Project:		17-19 Ferdinand Street	
Title: VENTILATION LAYOUT - Roof			
By: JS	Chkd: AWK	Date: 12/06/2015	
Sheet: -	Scale: 1:100 @A1		
Dwg. No. V05			Rev. -