

Safety, Health and Environment Information

The significant unusual hazards / risks associated with this type of work are noted as:

| CONSTRUCTION              |      |      |
|---------------------------|------|------|
| CI                        | NONE | NONE |
| CII                       | NONE | NONE |
| OPERATION AND MAINTENANCE |      |      |
| OI                        | NONE | NONE |
| OII                       | NONE | NONE |
| DISMANTLING/DEMOLITION    |      |      |
| DI                        | NONE | NONE |
| DII                       | NONE | NONE |


NOTE - TO BE READ IN CONJUNCTION WITH RISK REGISTER

GENERAL NOTES:

- DO NOT SCALE THE DRAWINGS
- ALL BUILDING SERVICES DRAWINGS TO BE READ IN CONJUNCTION WITH MECHANICAL & ELECTRICAL SPECIFICATIONS & SCHEDULES
- THIS DRAWING SHALL ONLY BE USED FOR THE SPECIFIC SERVICES INTENDED
- DIMENSIONS TO BE CHECKED ON SITE BEFORE ANY WORK IS PUT IN BY HAND OR PREFABRICATED
- FINAL ACCESS & SETTING OUT OF SERVICES TO BE AGREED WITH ARCHITECT
- UNLESS OTHERWISE STATED ALL DIMENSIONS IN MILLIMETERS
- REFER TO STANDARD DETAILS
- REFER TO 28731-SOAS-E-SYM-GEN-XX-850 FOR STANDARD SYMBOLS AND ABBREVIATIONS
- THIS DRAWING IS COPYRIGHT AND SHALL NOT BE USED WITHOUT PERMISSION
- FINAL LOCATIONS OF DOOR LOCK COMMUNICATIONS HUB SUBJECT TO MANUFACTURER'S SITE SURVEY

| REV | DATE     | DESCRIPTION   | DWN | CHK/APP |
|-----|----------|---|-----|---------|
| 6   | 03.08.15 | PRE-CONSTRUCTION - LIGHT FITTINGS TYPE AG + AGE ADDED AND TYPE A + AE REINSTATED WHERE APPLICABLE | SH  | MF/DP   |
| 5   | 21.07.15 | PRE-CONSTRUCTION - LIGHT FITTINGS TYPE A + AE OMITTED   | SH  | MF/DP   |
| 4   | 01.05.15 | PRE-CONSTRUCTION  | SH  | KM/DP   |
| 3   | 22.08.14 | PRE-CONSTRUCTION  | SH  | RS/DP   |
| 2   | 12.08.14 | PRE-CONSTRUCTION  | SH  | RS/DP   |
| 1   | 01.08.14 | PRE-CONSTRUCTION  | PJS | RS/DP   |

KEY PLAN

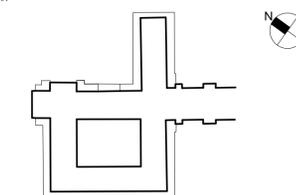

PROJECT STATUS: **PRE-CONSTRUCTION**



155 Moorgate, London, EC2M 6XB  
 www.macegroup.com


PROJECT TITLE:  
**SOAS INTO SENATE HOUSE  
 MALET STREET  
 LONDON, WC1E 7HU**

DRAWING TITLE:  
**ELECTRICAL SERVICES  
 LIGHTING LAYOUT  
 THIRD FLOOR**

| PROJECT NO. | DRAWN BY | SH | DATE | 01.08.14 |
|-------------|----------|----|------|----------|
| 28731       | CHK BY   | RS | DATE | 01.08.14 |
|             | APPD BY  | DP | DATE | 01.08.14 |

| PROJECT CODE                | DISC. | VIEW TYPE        | VIEW CAT. | LEVEL | DWG. NO. |
|-----------------------------|-------|------------------|-----------|-------|----------|
| SOAS - E - PLN - LTG - 03 - |       |                  |           |       | 114      |
| SHEET NO.                   | SCALE | ORIG. SHEET SIZE | REV.      |       |          |
| 1 of 1                      | 1:100 | A1               | C 6       |       |          |

INFORMATION HANDLING CLASSIFICATION:  
**UNRESTRICTED**  
 C:\Users\harry.brown\Documents\SOAS-E-Proposed-WIP\_harry.brown.rvt

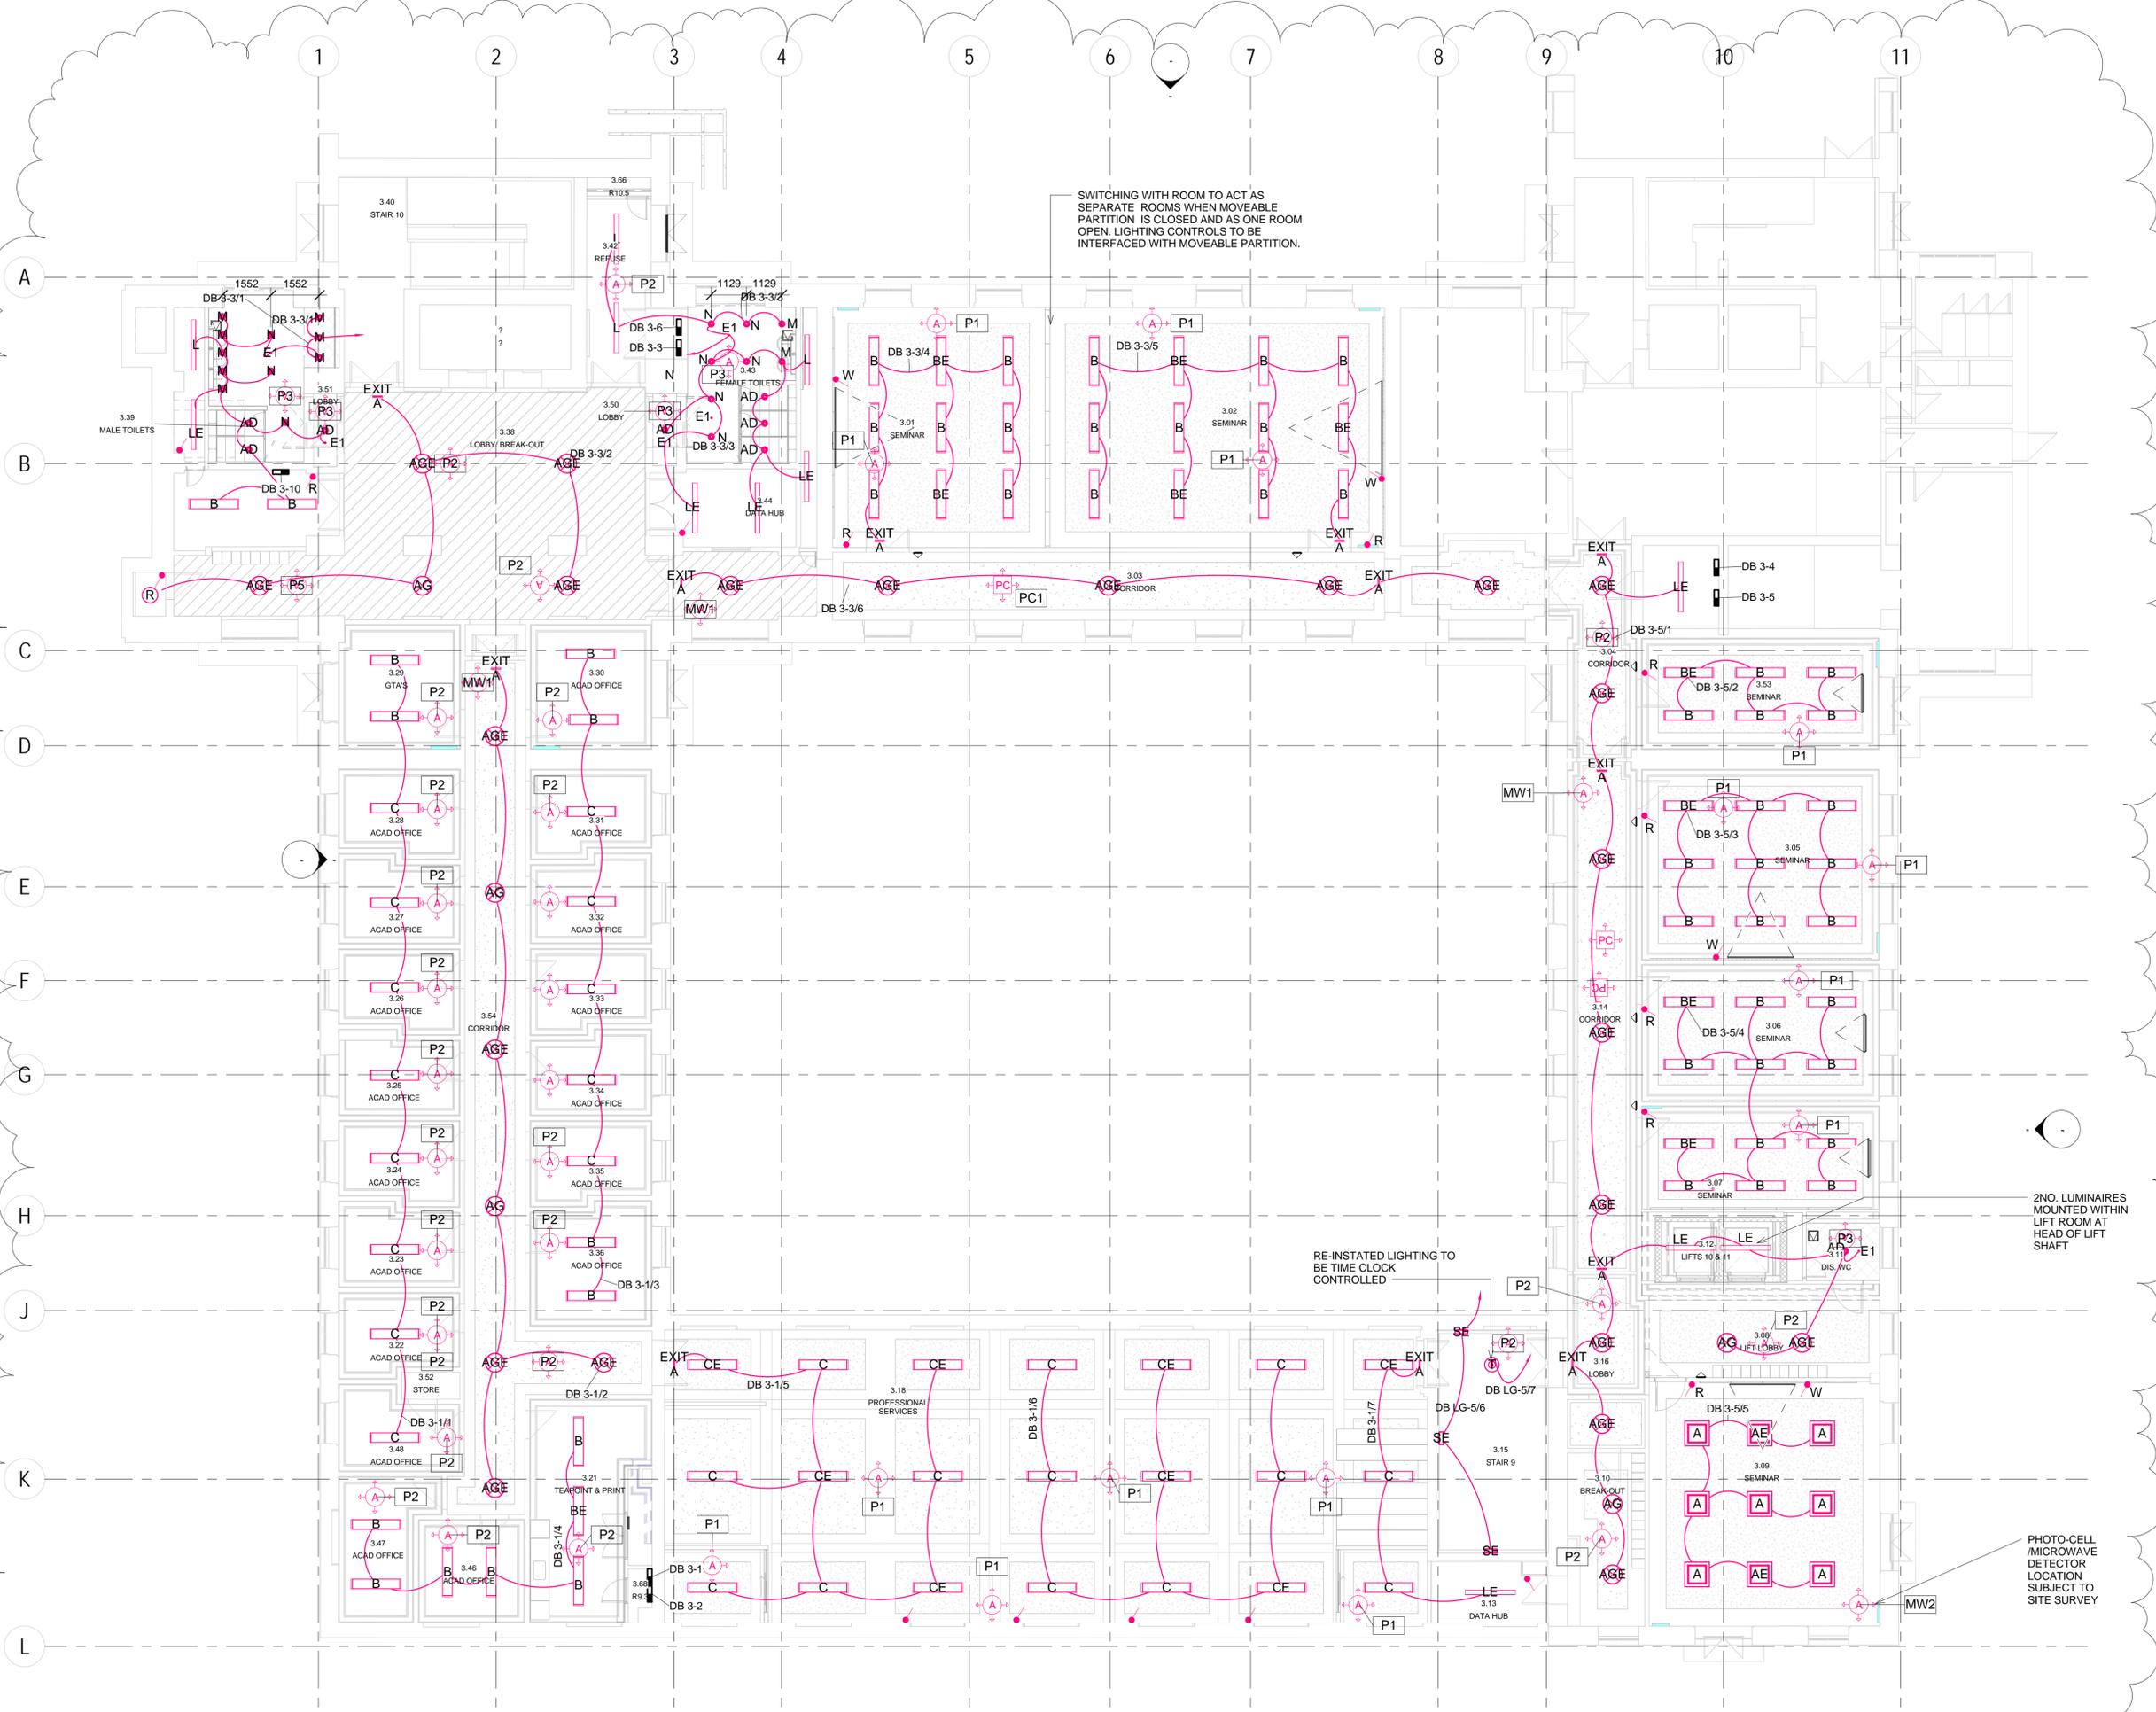

SWITCHING WITH ROOM TO ACT AS SEPARATE ROOMS WHEN MOVEABLE PARTITION IS CLOSED AND AS ONE ROOM OPEN. LIGHTING CONTROLS TO BE INTERFACED WITH MOVEABLE PARTITION.

RE-INSTATED LIGHTING TO BE TIME CLOCK CONTROLLED

2NO. LUMINAIRES MOUNTED WITHIN LIFT ROOM AT HEAD OF LIFT SHAFT

PHOTO-CELL/MICROWAVE DETECTOR LOCATION SUBJECT TO SITE SURVEY

**05 Third Floor - Lighting**  
 1:100