


REFER TO DRG No 22885-603 FOR CONTINUATION OF SITE

REFER TO DRG No 22885-601 FOR CONTINUATION OF SITE

REFER TO DRG No 22885-605 FOR CONTINUATION OF SITE

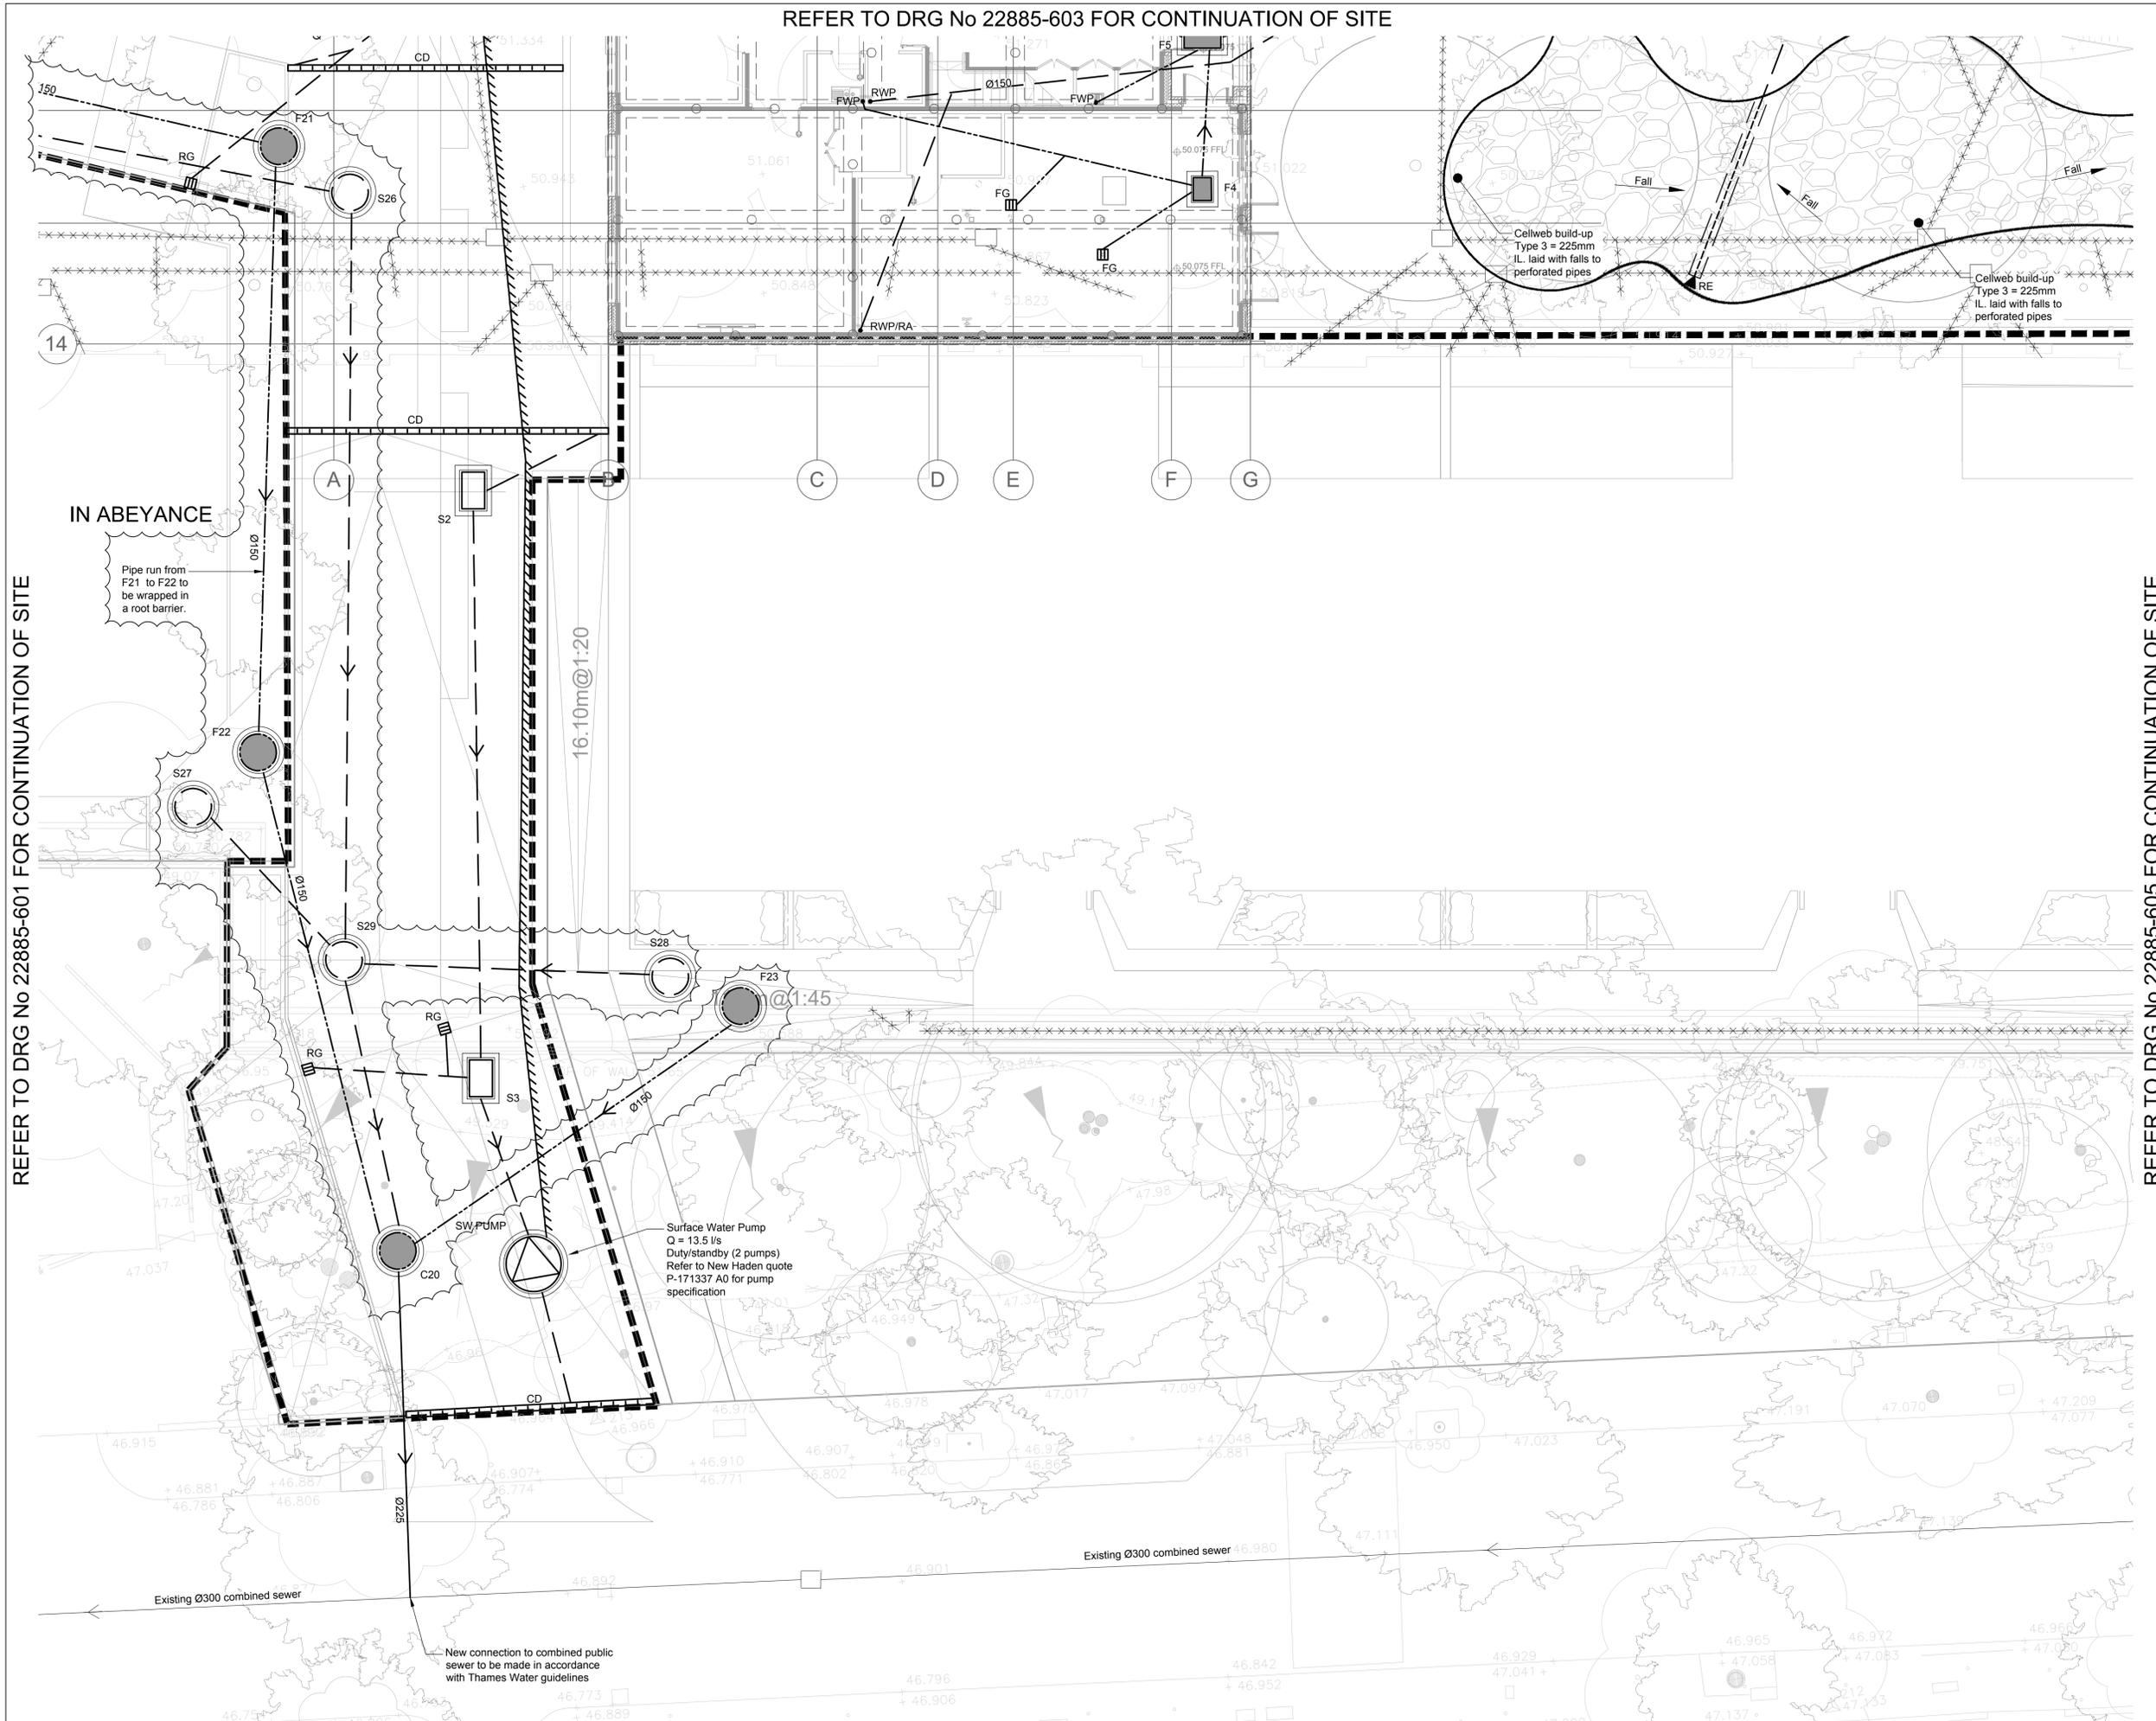

- Notes :
- This Drawing is to be read in conjunction with all relevant Architect's Engineer's and specialists' drawings and specifications.
  - Do not scale from this drawing in either paper or digital form. Use written dimensions only. To check drawing has been printed to the intended scale this bar should be 50mm long @ A1 or 25mm long @ A3.
  - Health & Safety : All specific drawing notes are to be read in conjunction with the project "Information Pack" and "Site Rules".
  - For general notes refer to Drawing No. 22885-600
  - Permeable surfaces TBC with Landscape Architect.
  - All buried surface water pipes to be Ø150mm & all foul water pipes to be Ø100mm U.N.O.

DRAINAGE LEGEND	
New FW Drain	--->---
New SW Drain	--->---
SW Perforated Pipe	--->---
New Combined Drain	--->---
Rising Main	--->---
Existing Combined Sewer	--->---
Existing FW Drain	--->---
Demolished/Abandoned	--->---

DRAINAGE KEY	
RWP	Rainwater Down Pipe
RWP/RA	Rainwater Down Pipe With Above Ground Rodding Access
FWP	Foul Waste Pipe
BD	Backdrop
NRV	Non Return Valve
RE	Rodding Eye
RG	Road Gully
YG	Yard Gully
FG	Floor Gully
CD	Channel Drain With Sump Unit
DC	Dish Channel
BS	Brickslot Channel Drain With Sump Unit
S1	Surface Water Manhole Chamber
F1	Foul Water Manhole Chamber
FCMH1	Flow Control Chamber (SW only)
	Permeable Paving
	Attenuation Cells

Ver	Date	Drawn	Eng	Amendment
12	11.04.16	DLa	KB	Issued for Construction
11	08.04.16	DLa	KB	Issued for Draft Construction
10	22.02.16	AH	KB	Issued for Construction
9	12.02.16	AH	KB	Issued for Construction
8	14.12.15	DLa	KB	Revisions Clouded
7	02.11.15	DLa	KB	Issued for Tender

**KINGSGATE SCHOOL  
LIDDELL ROAD**

**BELOW GROUND  
DRAINAGE LAYOUT  
SHEET 2**

Status  
**FOR CONSTRUCTION**

Drawn	DLa	Eng	KB
Scales	1:100 at A1	1:200 at A3	
Drawing No	22885-602	Ver	12