



NOTES/KEY:

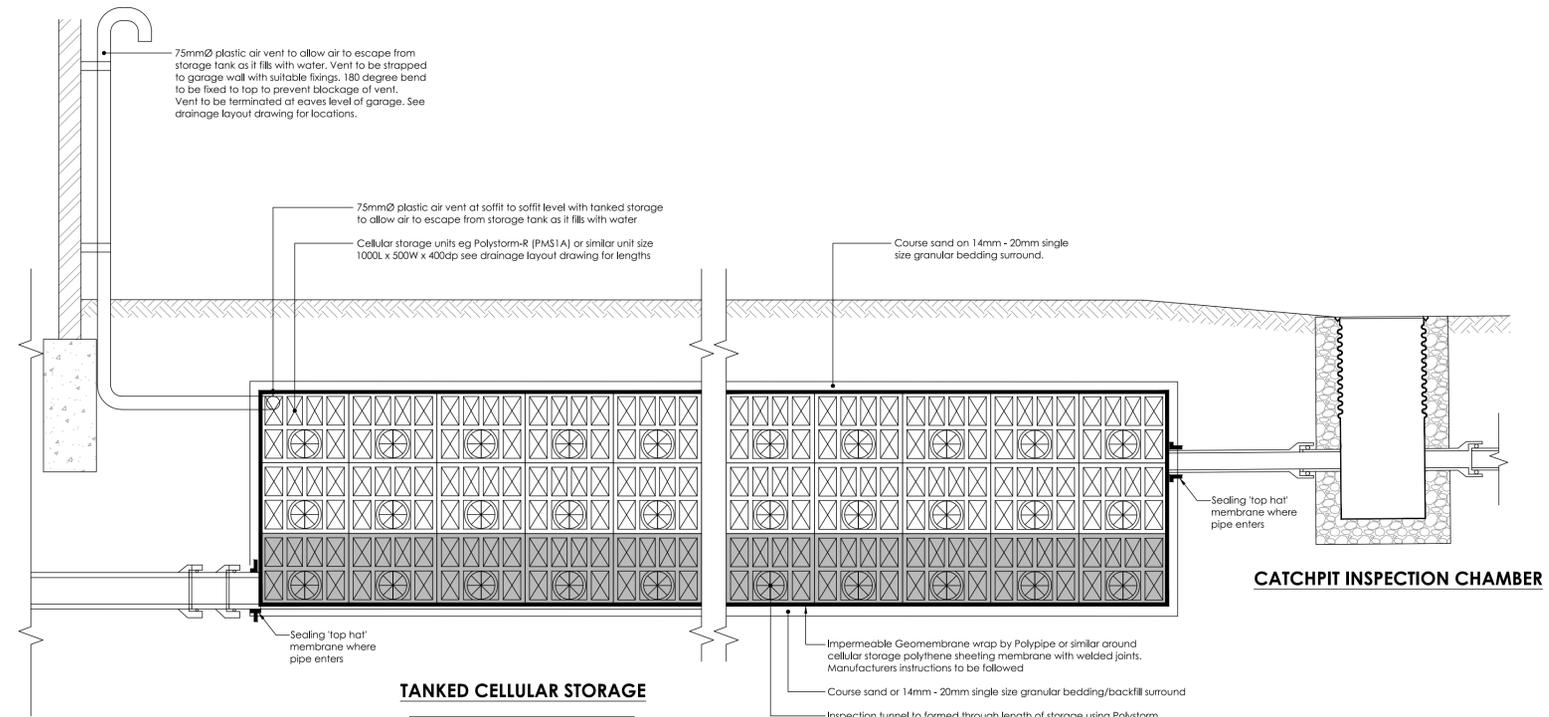


TANKED CELLULAR STORAGE

Note - It is important Cellular storage should be protected from loads during the construction period.

Note - THE LAYOUT SHOWN ABOVE IS A TYPICAL DETAIL AND NOT SITE SPECIFIC. PLEASE REFER TO DRAINAGE LAYOUT DRAWING FOR ACTUAL ARRANGEMENT.

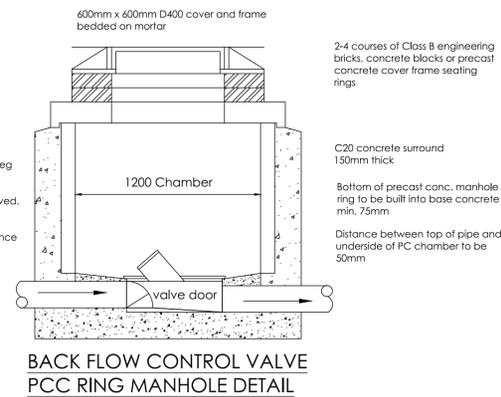

BACK FLOW CONTROL VALVE PCC RING MANHOLE DETAIL

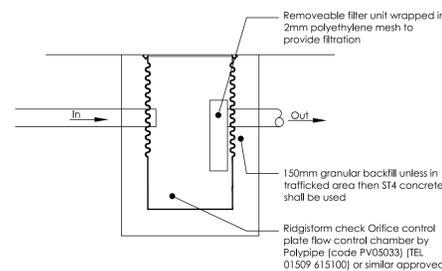

ORIFICE PLATE FLOW CONTROL CHAMBER

T1	23/08/16	DJ	JT	Initial Issue
MARK	DATE	BY	CHKD.	REVISION NOTES
				C.D.M.

SIGNIFICANT RISKS AND HAZARDS:

iesis SPECIAL STRUCTURES
 IESIS SPECIAL STRUCTURES
 20 IRONMONGER LANE
 LONDON
 EC2V 8EP
 T: +44 (0)207 6002912
 www.iesis.net

PROJECT:
**81 A/B Bayham Street
 Camden**

DRAWING TITLE:
Drainage Details

STATUS: **INFORMATION**

SCALE AT A1:	DATE:	DRAWN:	CHECKED:
1:20	23/08/2016	NJ	TST
JOB NUMBER:	DRAWING NUMBER:	REVISION:	
SE1233	301	T1	