


- Key**
- ⊙ New RWP
 - Drainage run

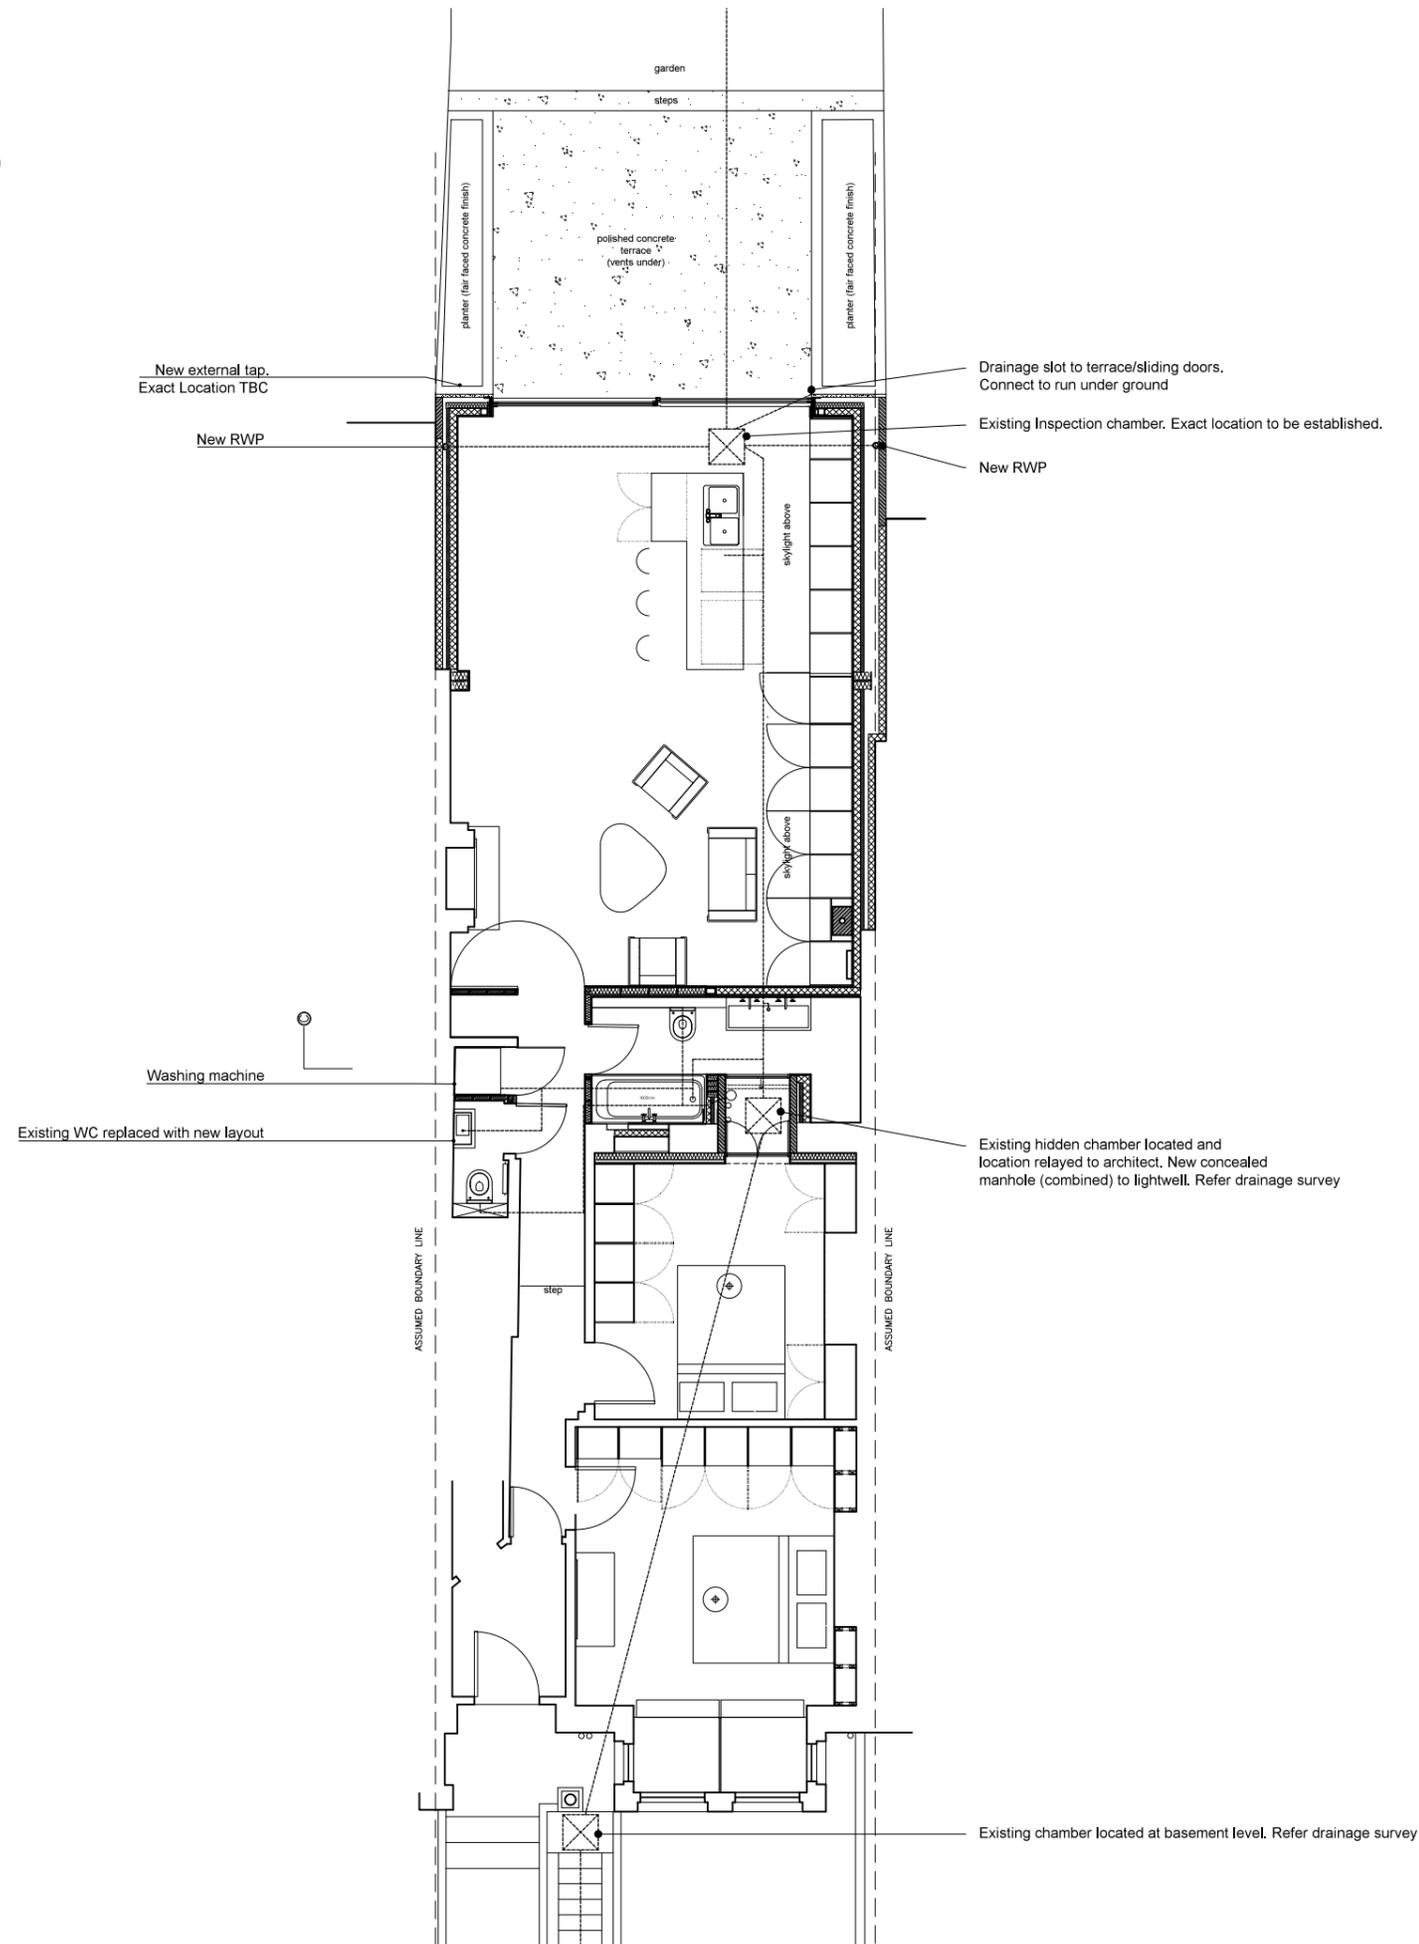

All drainage routes indicative. Contractor to establish existing drainage system and design new installation for approval of architect.

Refer also structural engineers drawings and drainage survey

NOTE

Do not scale from drawing. Use figured dimensions only. All discrepancies to be verified with Architect prior to ordering or construction/execution.

CONFIRM ALL SETTING OUT WITH ARCHITECT PRIOR TO CONSTRUCTION



PROPOSED



t: 0207 127 0696
 w: www.architectureforlondon.co.uk
 82-84 Clerkenwell Road London EC1M 5RF
 e: mail@architectureforlondon.co.uk

PROJECT TITLE 53 GONDAR GARDENS					
DRAWING TITLE PROP GROUND DRAINAGE PLANS					
DWG STATUS TENDER					
DRAWN	GR	FILE xxx	DATE 24-12-14	REVISION	
CHECKED	--	JOB NO. 1437	SCALE 1:100 @ A3	DWG NO.	AS002