




1 RWP Plan- WCD Double RWP Outlets
1 : 20

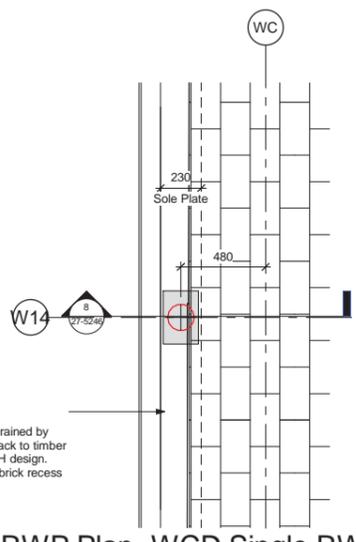


7 RWP Plan- WCD Single RWP Outlet
1 : 20

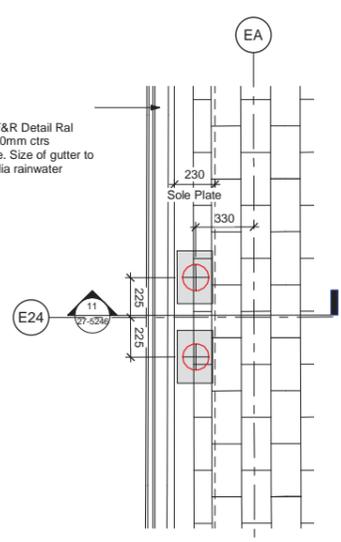


10 RWP Plan- ECD Double RWP Outlets
1 : 20

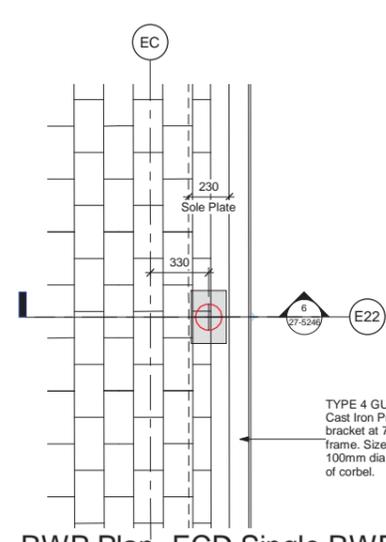


2 RWP Plan- ECD Single RWP Outlet
1 : 20

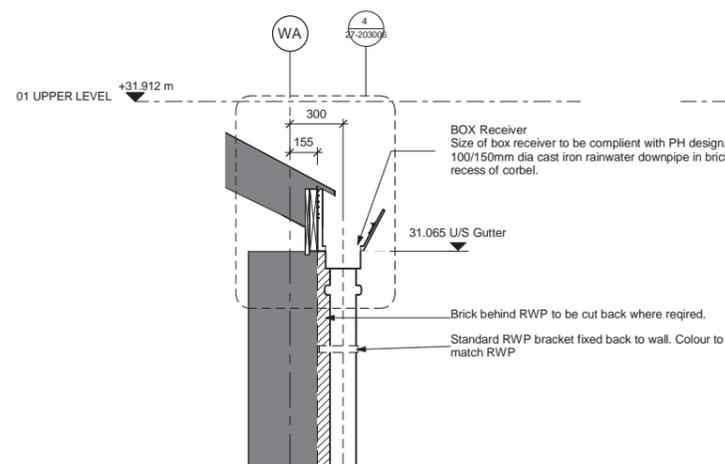


5 RWP Section- WCD Double RWP Outlet
1 : 20

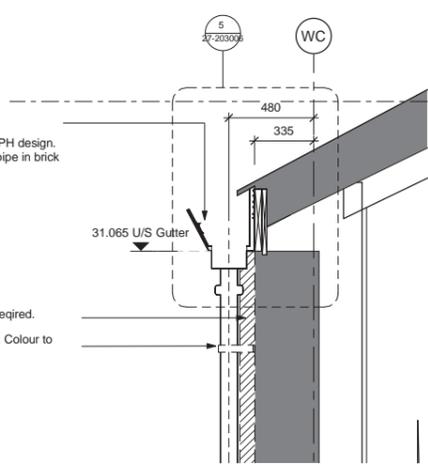


8 RWP Section- WCD Single RWP Outlet
1 : 20

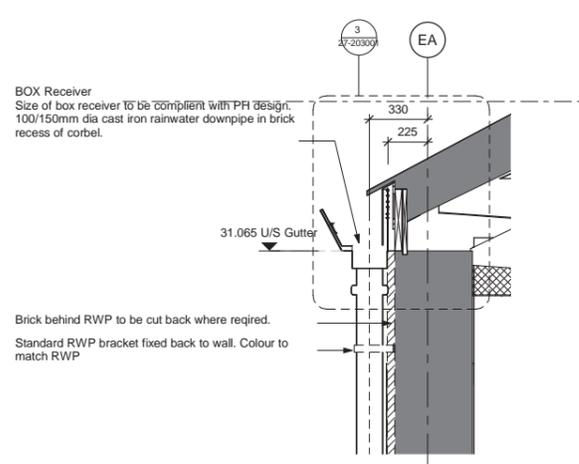

11 RWP Section- ECD Double RWP Outlets
1 : 20

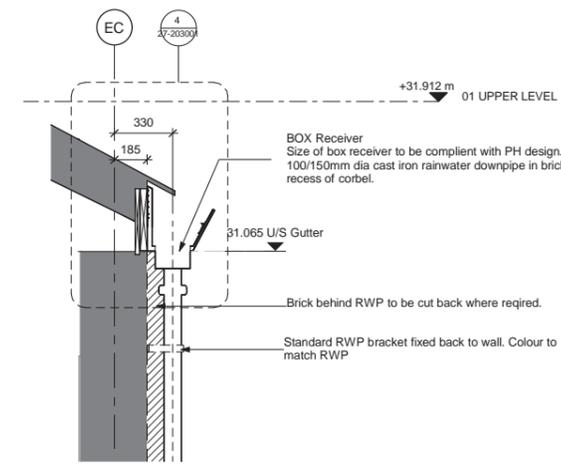


6 RWP Section- ECD Single RWP Outlet
1 : 20

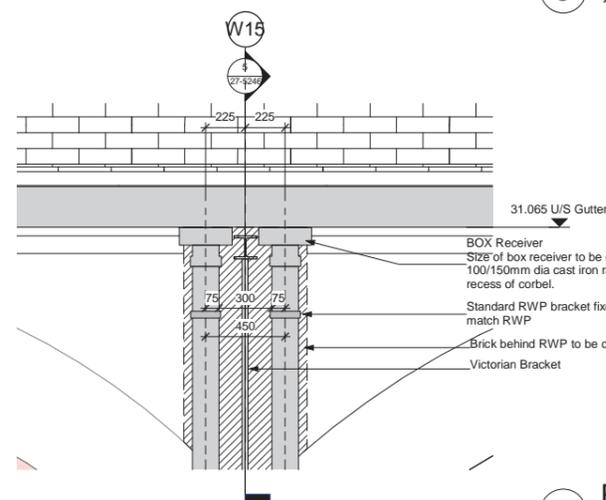


3 RWP Elevation- WCD Double RWP Outlets
1 : 20

9 RWP Elevation- WCD Single RWP Outlets
1 : 20

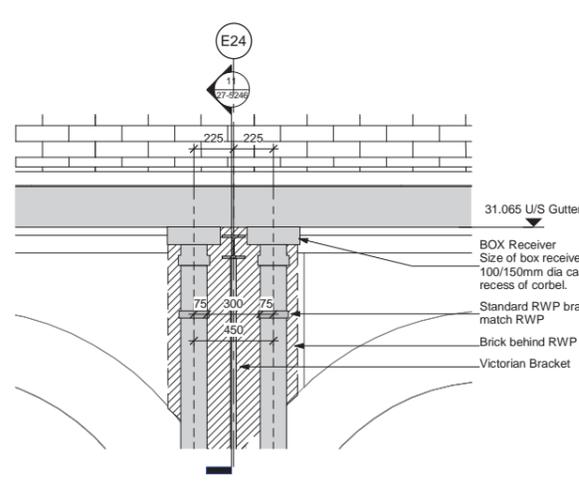

12 RWP Elevation- ECD Double RWP Outlets
1 : 20

4 RWP Elevation- ECD Single RWP Outlet
1 : 20

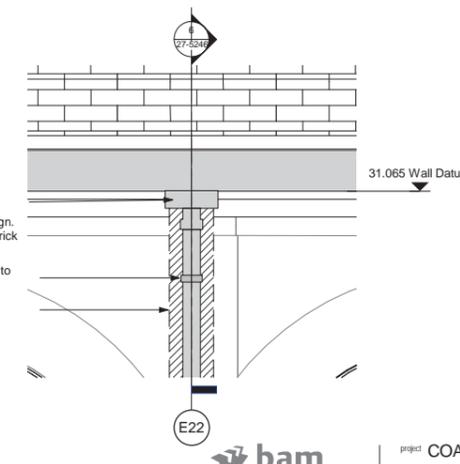

no	by	chkd	date	description
002	VH	MWB	08/07/16	Updated to suit comments dated 20.06.16
001	VH	MWB	17/06/16	Construction Issue



project COAL DROPS YARD

RWP Details

scale 1 : 20 @ A1

date 06/09/16

checked MWB

design @bam.co.uk

purpose of issue

Construction

draw VH


date 06/09/16

checked MWB


design @bam.co.uk

4389



002

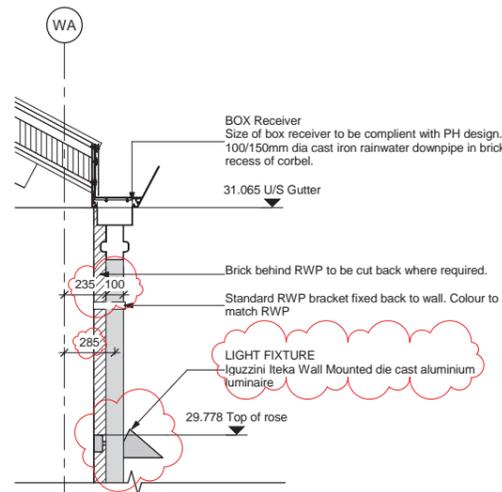


1 RWP Section WCD W01
1 : 20

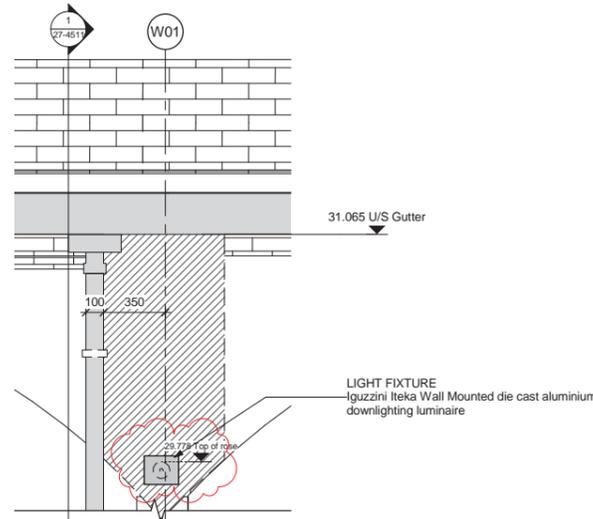


2 RWP Elevation WCD W01
1 : 20

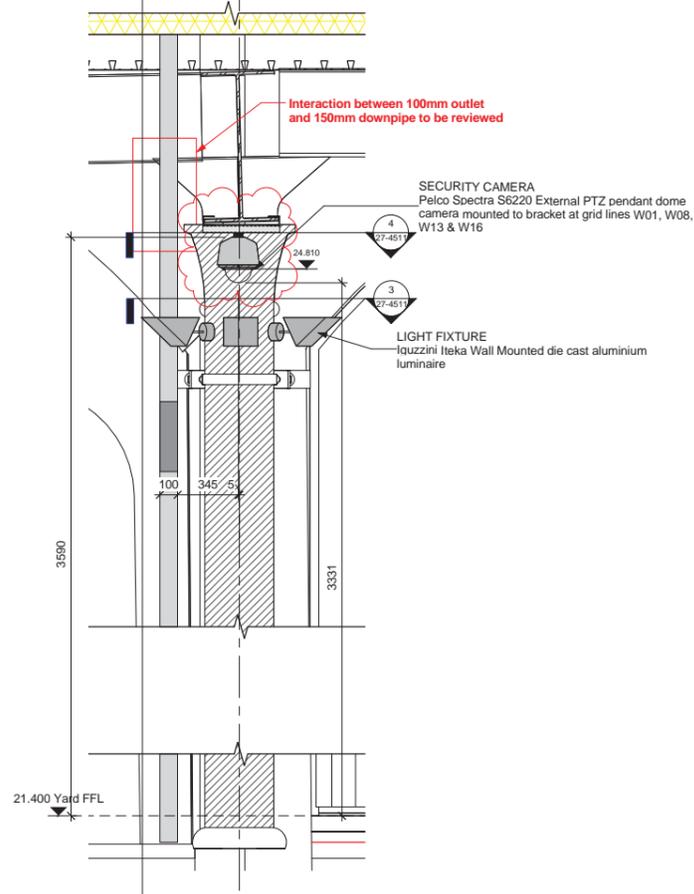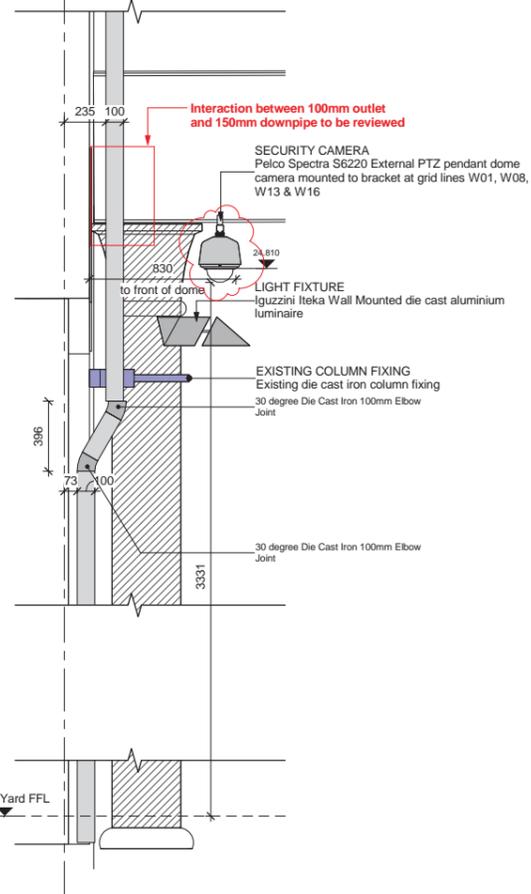

3 WCD W01 Lighting Plan
1 : 10

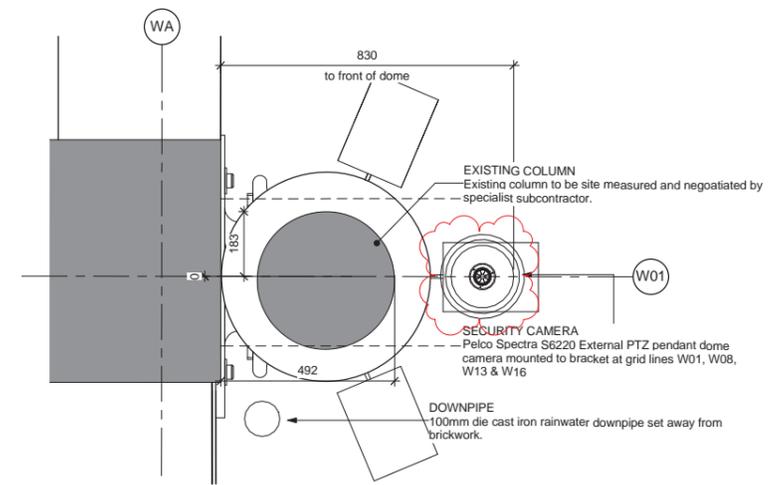

4 WCD W01 Security Camera Plan
1 : 10

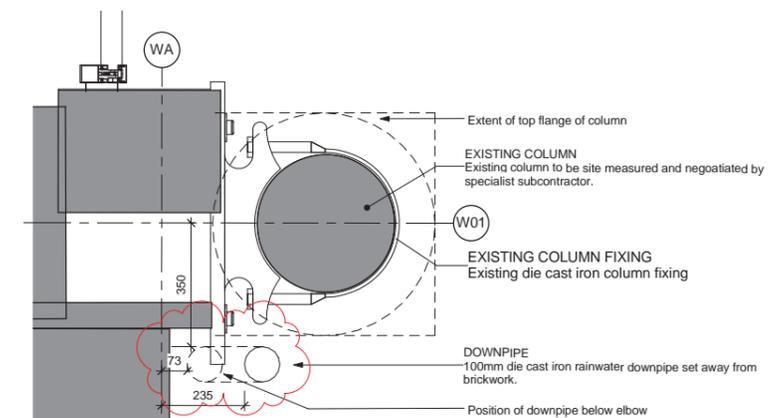

5 WCD W01 RWP Plan
1 : 10

Status Code (as defined in BS1192)
 S0 - Initial Status or WIP
 S1 - Issued for co-ordination
 S2 - Issued for information
 S3 - Issued for internal review
 S4 - Issued for construction approval
 D1 - Issued for costing
 D2 - Issued for tender

Documentation (Contractual)
 A - Issued for construction
 B - Issued for construction but with comments
 C - Comprehensive revision required

Archive
 AB - Record Drawing

Documentation (Pre-construction)
 D3 - Issued for contractor design
 D4 - Issued for manufacture/procurement

rev	by	chkd	date	description
002	BDC	DGW	14/09/17	Light shown at viaduct level, cctv location updated & RWP position updated.




bam
 B&M Design Ltd
 An operating company of
 B&M Construct UK Ltd
 Architecture
 Interior Design
 3D Visualisation
 Feasibility Studies
 Structural Engineering
 Environmental Services
 Building Information Modelling


Continium Business Park
 Griffiths Way, St Albans
 Northminster, AL1 2FD
 01727 894200
 design@bam.co.uk
 www.bam.co.uk

project COAL DROPS YARD
 title RWP - WCD W01 East Facade
 purpose of issue Construction
 scale As indicated @ A1
 date 08/22/17
 drafter DB
 checked DW
 design@bam.co.uk
 002


BAM job no. 4389
 rev S4

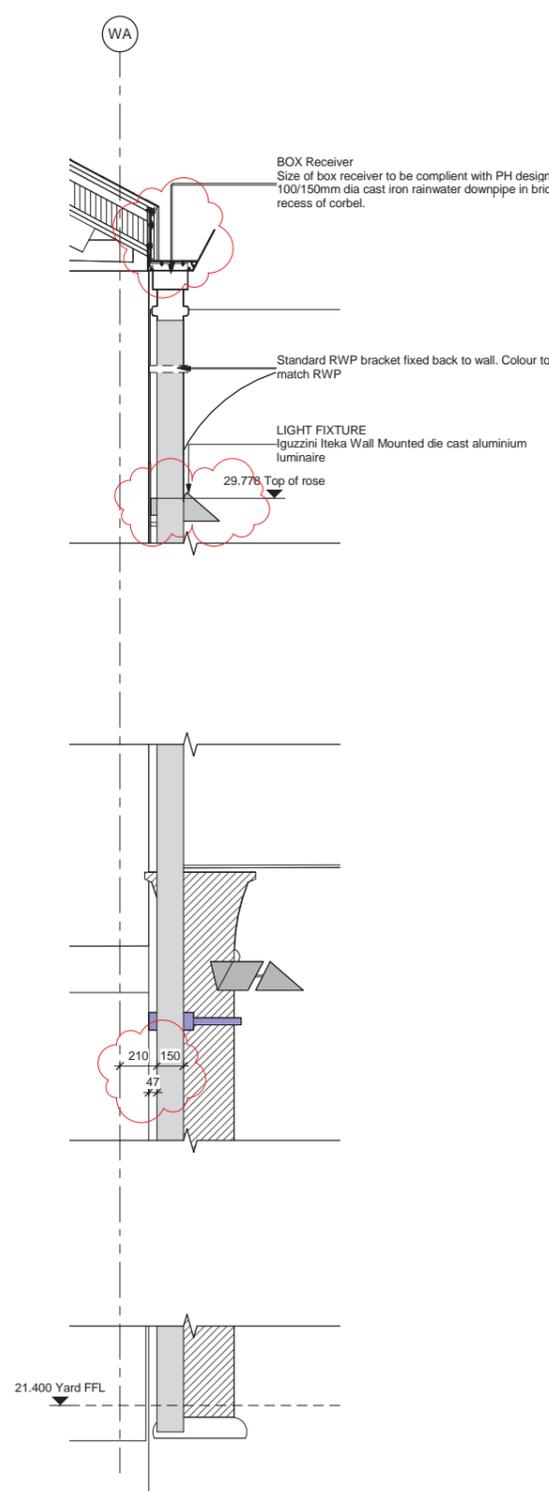


1
 RWP Section
 WCD W02
 1 : 20

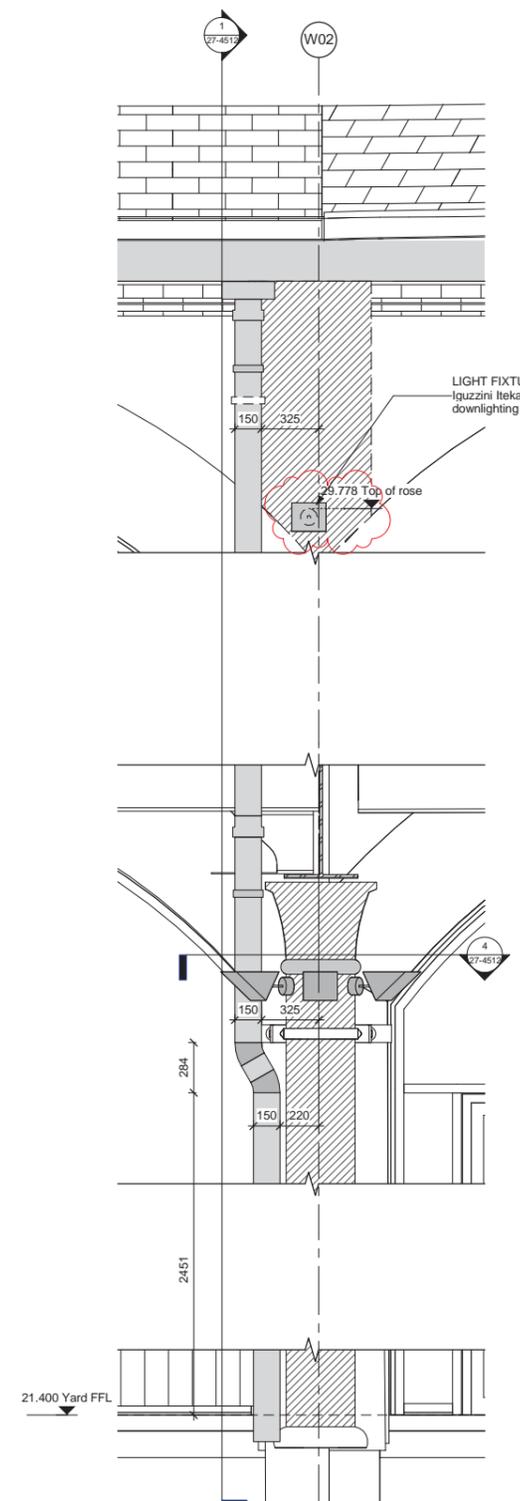


2
 RWP Elevation
 WCD W02
 1 : 20

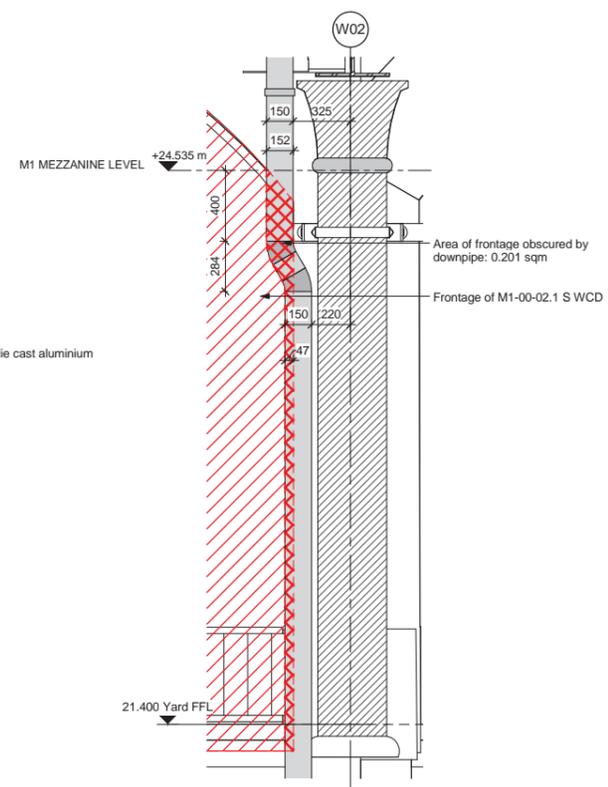

3
 RWP Elevation
 WCD W02 Shopfront
 1 : 20

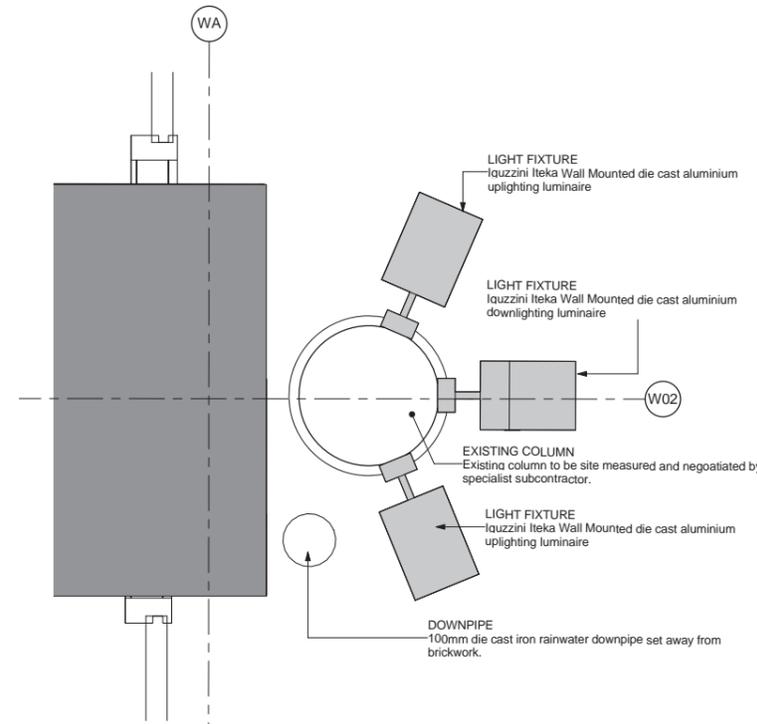

4
 RWP Plan
 WCD W02 Lighting
 1 : 10

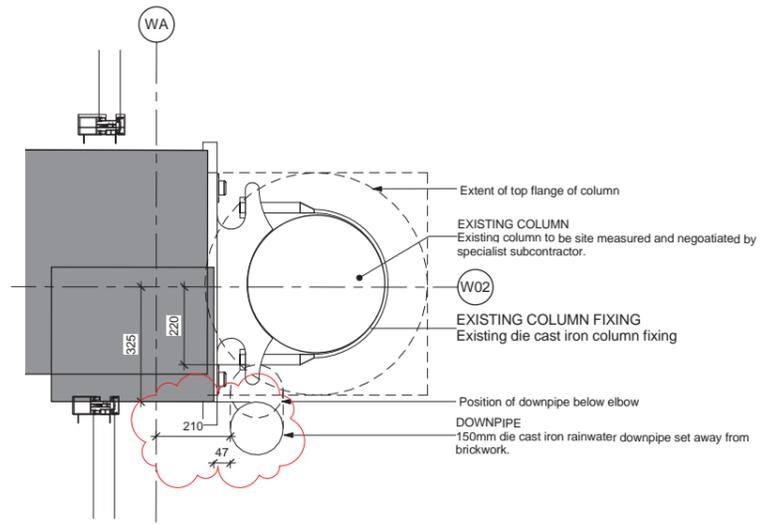

5
 RWP Plan
 WCD W02
 1 : 10

Status Code (as defined in BS1192)
 S0 - Initial Status or WIP
 S1 - Issued for co-ordination
 S2 - Issued for information
 S3 - Issued for internal review
 S4 - Issued for construction approval
 D1 - Issued for costing
 D2 - Issued for tender

Documentation (Contractual)
 A - Issued for construction
 B - Issued for construction but with comments
 C - Comprehensive revision required

Archive
 AB - Record Drawing

Documentation (Pre-construction)
 D3 - Issued for contractor design
 D4 - Issued for manufacture/procurement

rev	by	chkd	date	description
002	BDC	DGW	14/09/17	Light shown at viaduct level, RWP position updated.



bam
 B&M Design Ltd
 An operating company of
 B&M Construct UK Ltd
 Architecture
 Interior Design
 3D Visualisation
 Feasibility Studies
 Structural Engineering
 Environmental Services
 Building Information Modelling

Centrium Business Park
 Griffiths Way, St Albans
 Hemel Hempstead, AL1 2FD
 01727 894200
 design@bam.co.uk
 www.bam.co.uk

project COAL DROPS YARD

title RWP - WCD W02 East Facade

purpose of issue **Construction**

scale As indicated @ A1

date 08/22/17

site globallocation project

design/direct KXC-M1-001-BD4389-A-27-4512

draw DB

checked DW

Rate: C/S/F/B




purpose of issue

BAM job no.




4389

rev **S4**


002

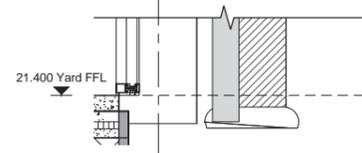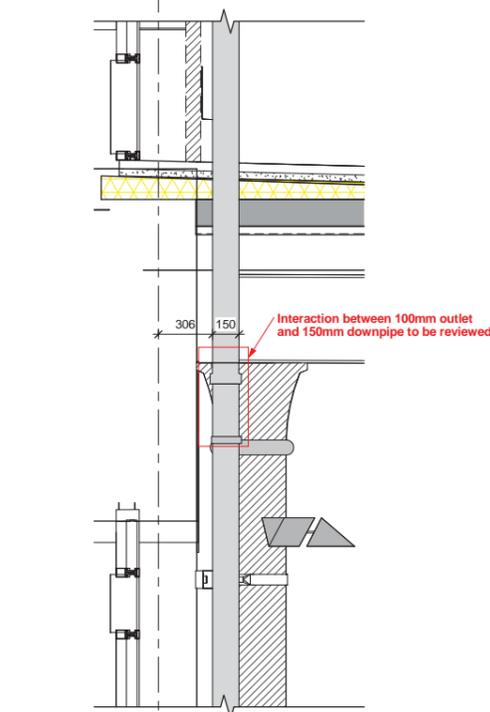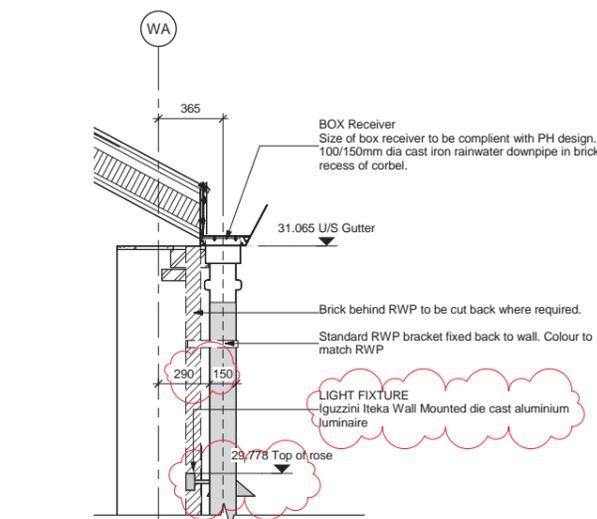


1
 RWP Section
 WCD W15
 1 : 20

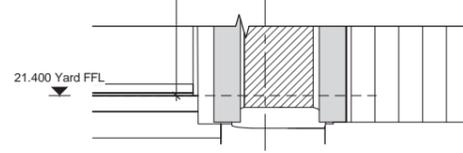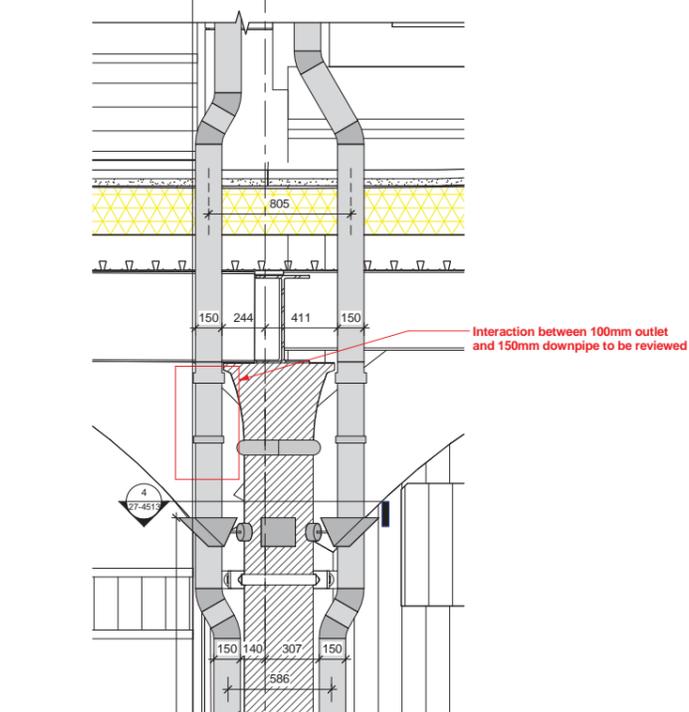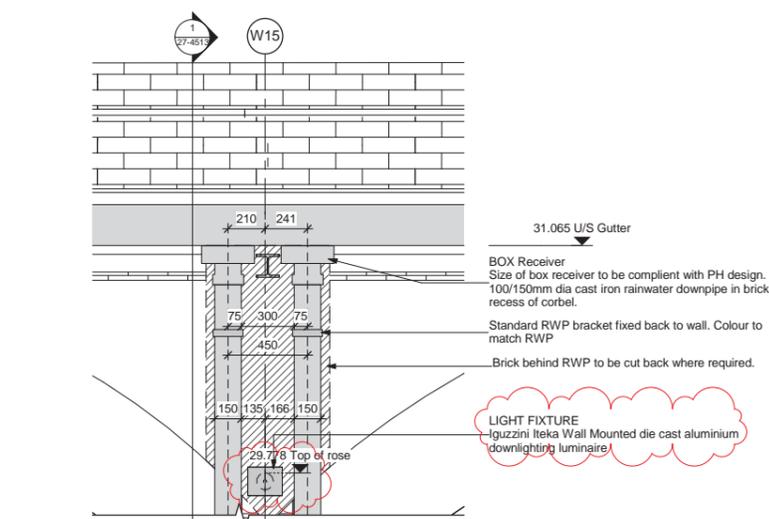

2
 RWP Elevation
 WCD W15
 1 : 20

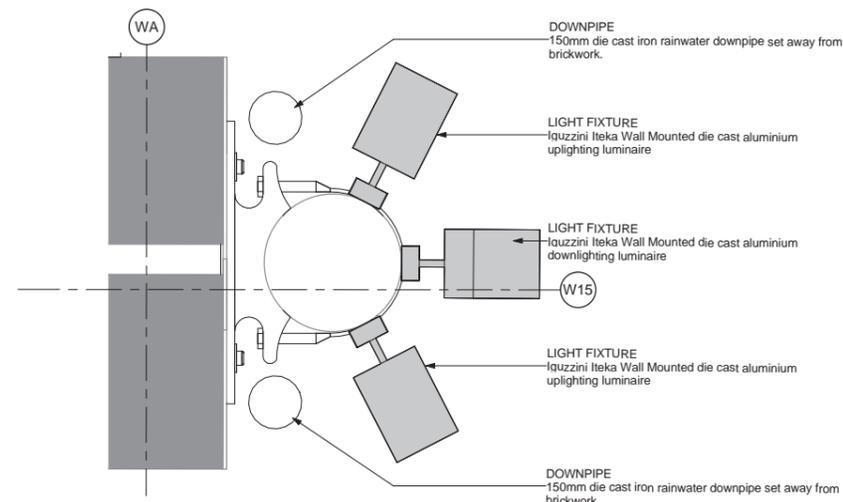

4
 RWP Plan
 WCD W15 Lighting
 1 : 10

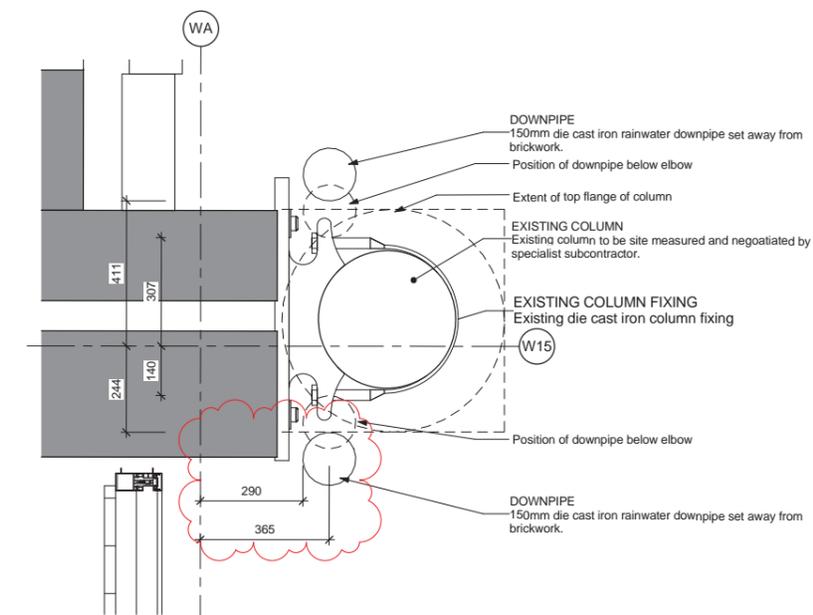

3
 RWP Plan
 WCD W15
 1 : 10

Status Code (as defined in BS1192)
 D3 - Issued for contractor design
 D4 - Issued for manufacture/procurement

Work in Progress (WIP)
 S0 - Initial Status or WIP

Shared
 S1 - Issued for co-ordination
 S2 - Issued for information
 S3 - Issued for internal review
 S4 - Issued for construction approval

Documentation (Pre-construction)
 D1 - Issued for costing
 D2 - Issued for tender

Documentation (Contractual)
 A - Issued for construction
 B - Issued for construction but with comments
 C - Comprehensive revision required

Archive
 AB - Record Drawing

002 BDC DGW 14/09/17 Light shown at viaduct level, RWP position updated.
 rev by dkd date description




bam
 B&M Design Ltd
 An operating company of
 BAM Construct UK Ltd
 Architecture
 Interior Design
 3D Visualisation
 Feasibility Studies
 Structural Engineering
 Environmental Services
 Building Information Modelling

Centrium Business Park
 Griffiths Way, St Albans
 Northfordshire, AL1 2FD
 01727 894200
 design@bam.co.uk
 www.bam.co.uk


project COAL DROPS YARD
 title RWP - WCD W15 East Facade
 purpose of issue Construction

scale As indicated @ A1
 date 08/22/17
 site skid/location project
 dgt/dicref KXC-M1-001-BD4389-A-27-4513


drawn DB
 checked DW
 Rate C/S/F/B Content
 B&M job no. 4389
 rev S4
 002

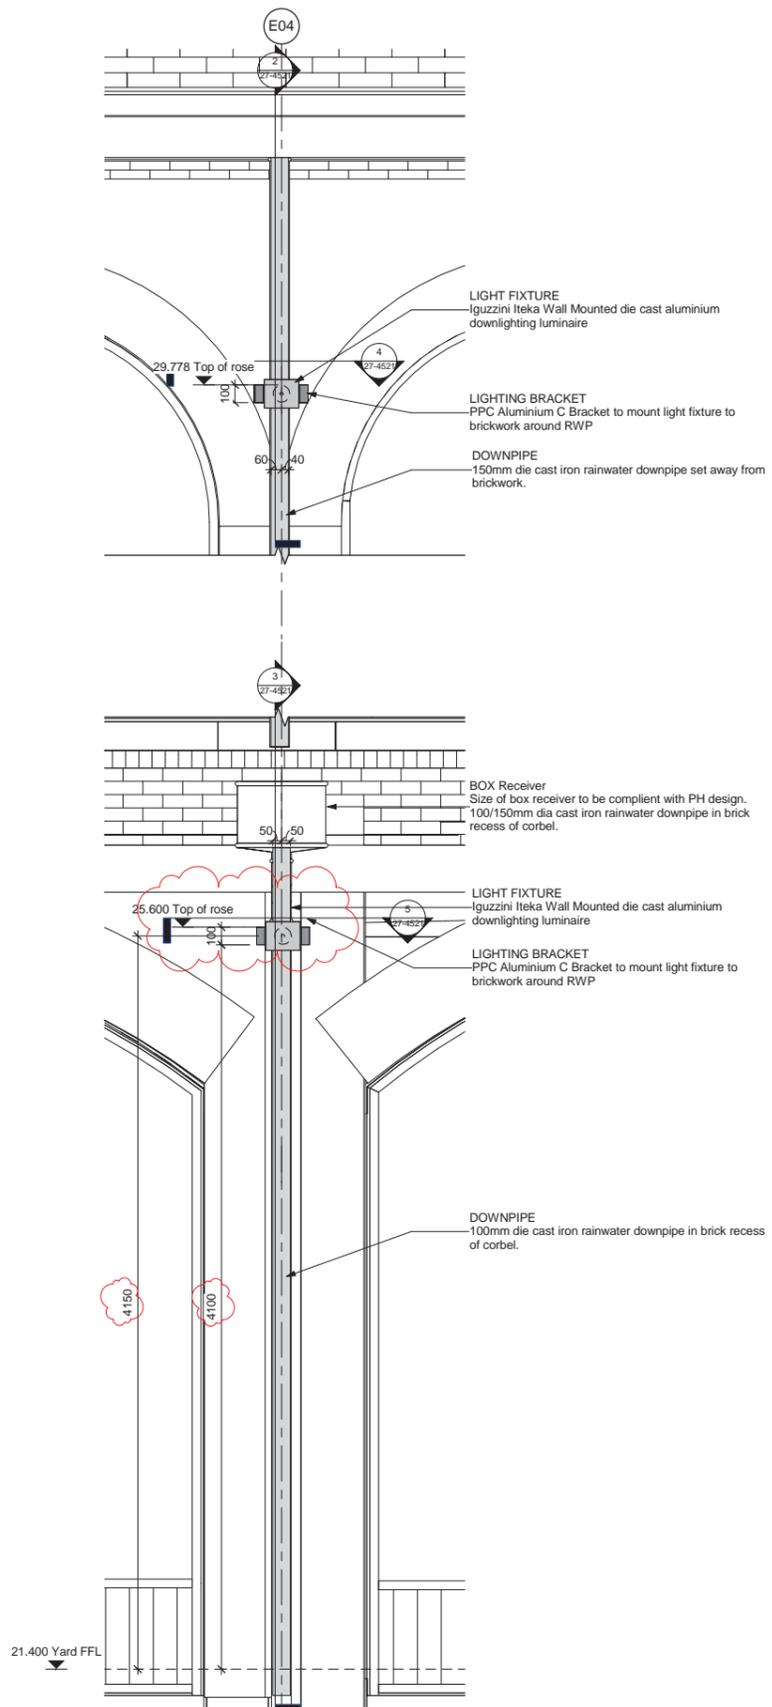


1 Elevation
 ECD West Facade Typical RWP Detail
 1 : 20

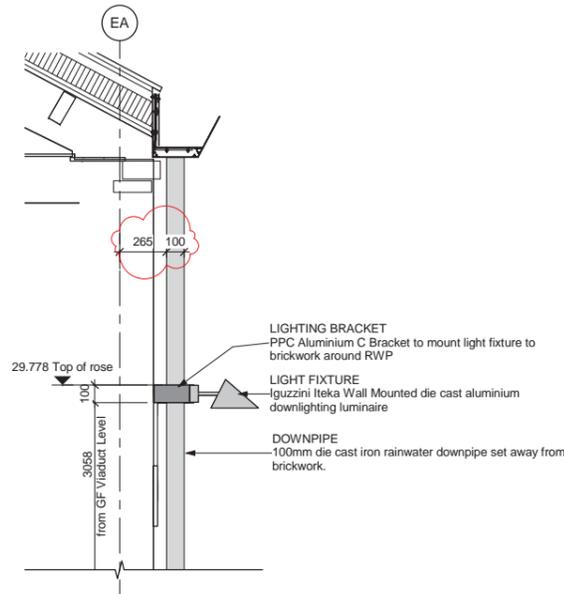


2 Section - Viaduct
 ECD West Facade Typical RWP Detail
 1 : 20

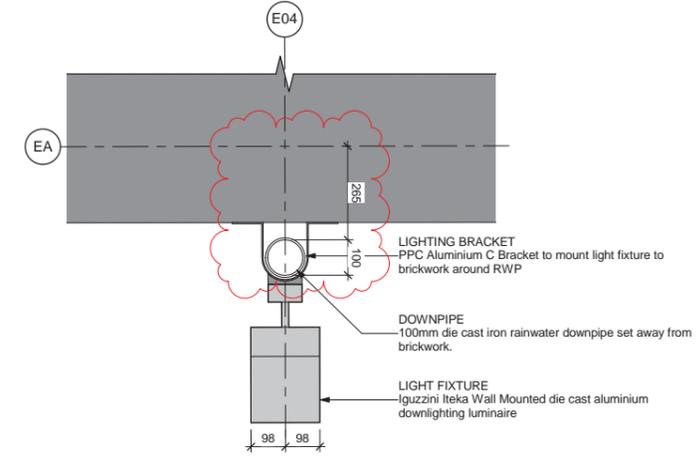


4 Plan - Viaduct
 ECD West Facade Typical RWP Detail
 1 : 10

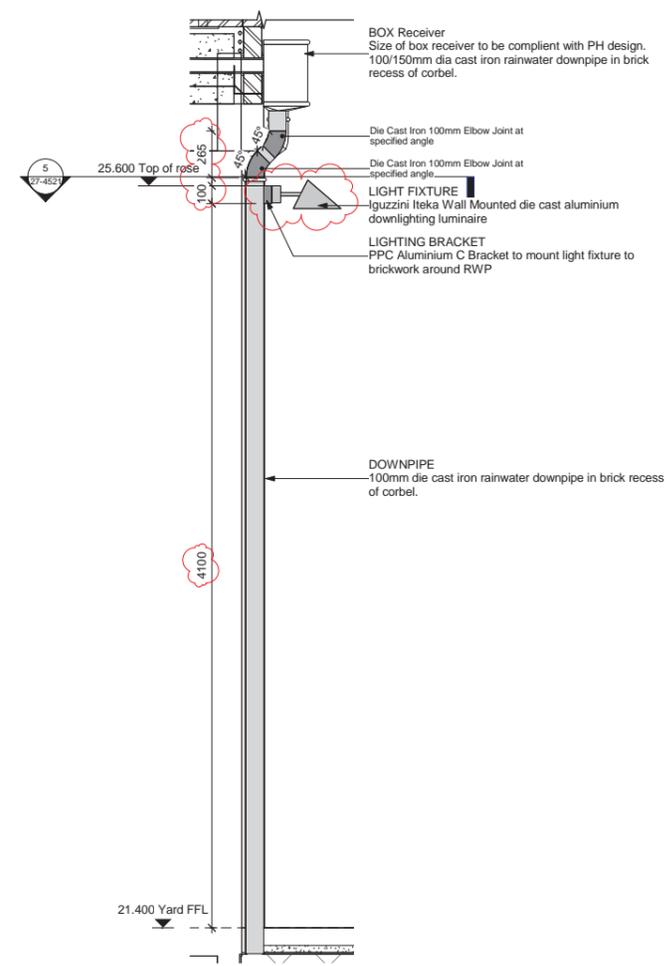

3 Section - Yard
 ECD West Facade Typical RWP Detail
 1 : 20

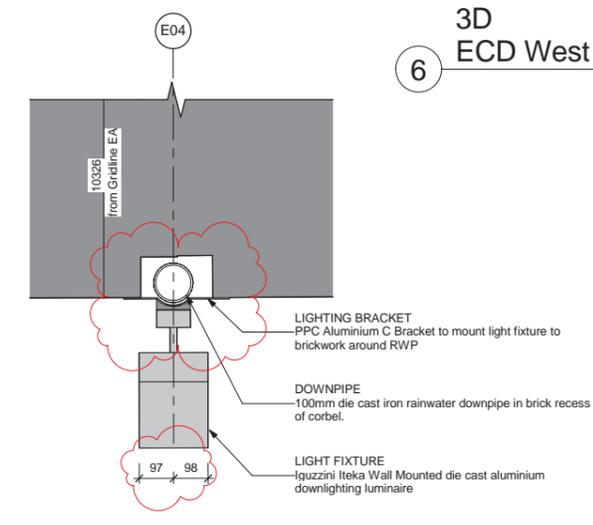

5 Plan - Yard
 ECD West Facade Typical RWP Detail
 1 : 10

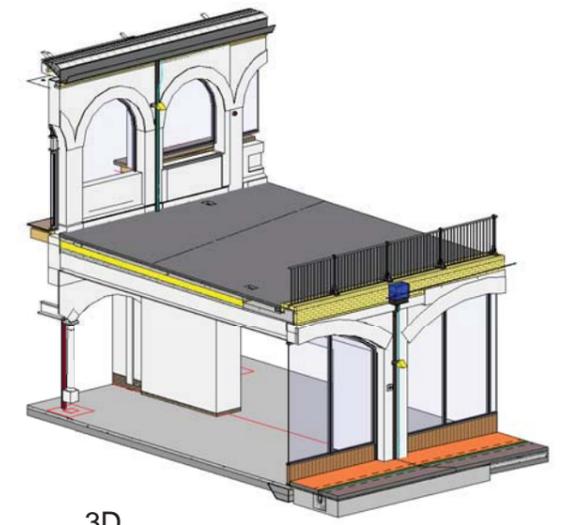

6 3D
 ECD West Facade Typical RWP Detail

Status Code (as defined in BS1192)
 D3 - Issued for contractor design
 D4 - Issued for manufacture/procurement

Work in Progress (WIP)
 S0 - Initial Status or WIP

Shared
 S1 - Issued for co-ordination
 S2 - Issued for information
 S3 - Issued for internal review
 S4 - Issued for construction approval

Documentation (Pre-construction)
 D1 - Issued for costing
 D2 - Issued for tender

Documentation (Contractual)
 A - Issued for construction
 B - Issued for construction but with comments
 C - Comprehensive revision required

Archive
 AB - Record Drawing

002	BDC	DGW	14/09/17	Lighting setting out updated& bracket changed.
rev	by	chkd	date	description



bam
 BAM Design Ltd
 An operating company of
 BAM Construct UK Ltd

Architecture
 Interior Design
 3D Visualisation
 Feasibility Studies
 Structural Engineering
 Environmental Services
 Building Information Modelling

Corinium Business Park
 Giffords Way, St Albans
 Northfordshire, AL1 2SD
 01727 894200
 design@bam.co.uk
 www.bam.co.uk

project COAL DROPS YARD

title Typical RWP - ECD West Facade

purpose of issue Construction

scale As indicated @ A1

date 08/30/17

site gbk/coal drops project

drawn DB

checked DW

Rate C/S/F/B


Content

BAM job no. 4389


rev S4

002


drg/dictref KXC-M2-001-BD4389-A-27-4521

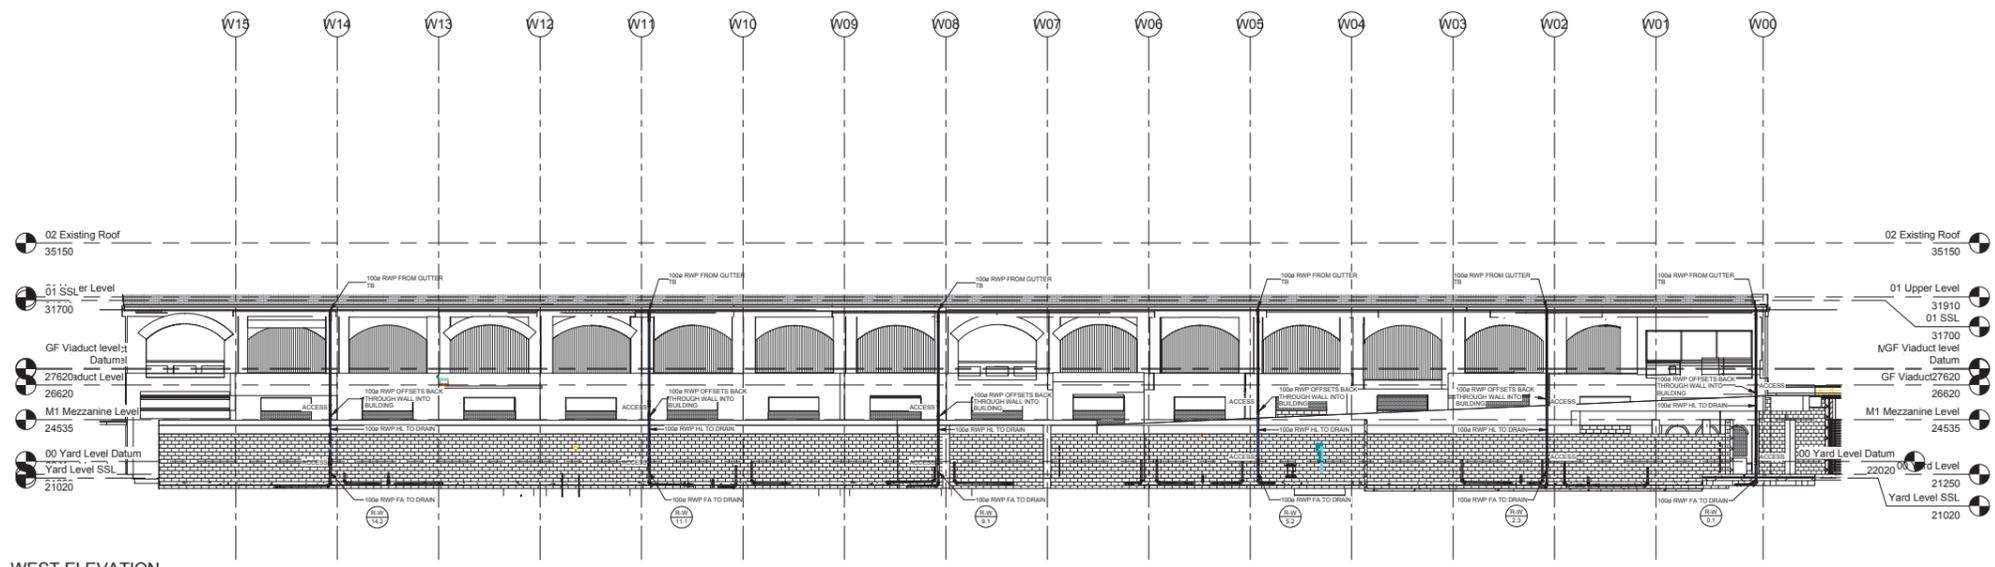


1 WEST ELEVATION
1:150

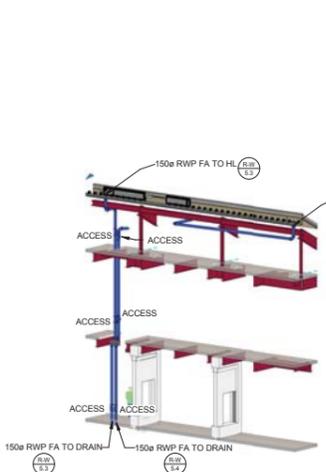


4 3D VIEW PH RWP GRID 5

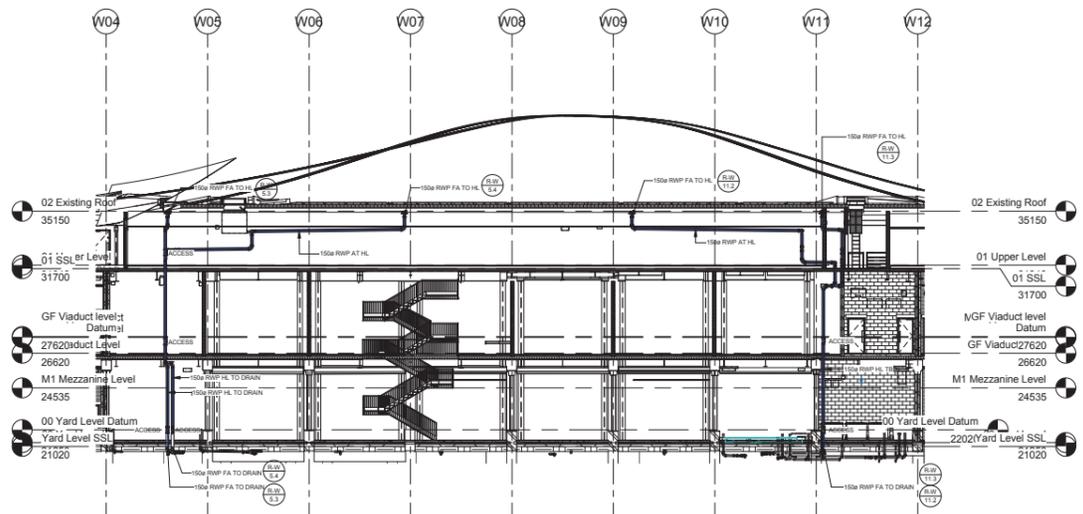

3 ROOF CHECK GUTTER
1:150

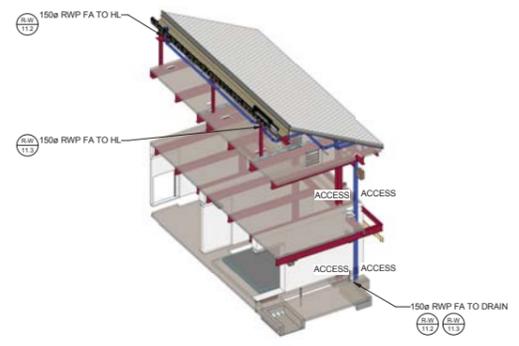

5 3D VIEW PH RWP GRID 11

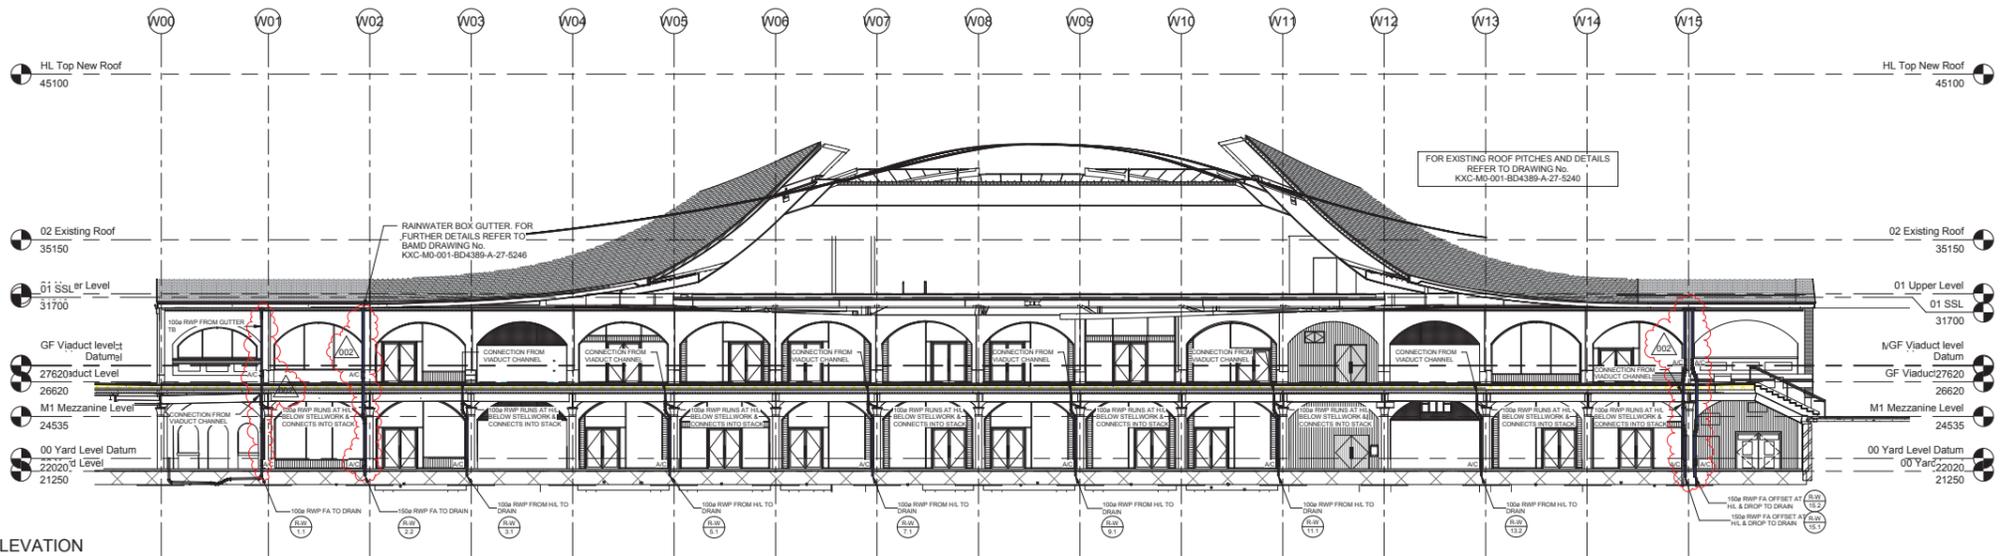

2 EAST ELEVATION
1:150

NOTE:
FOR FURTHER DETAILS OF
RAINWATER PIPES SETTING OUT
REFER TO ARCHITECTS DETAIL
DRAWINGS


NOTE:
FINAL LOCATIONS OF ACO DRAINS
ON VIADUCT LEVEL TO BE
CONFIRMED BY PBA

FOR EXISTING ROOF PITCHES AND DETAILS
REFER TO DRAWING No.
KXC-MD-001-BD4389-A-27-5246

4. FOR FURTHER DETAILS OF RAINWATER
PIPES SETTING OUT REFER TO ARCHITECTS
DETAIL DRAWINGS






NOTES:
1. FOR SYMBOLS LEGEND AND ABBREVIATIONS
REFER TO DRAWING BSE4389-M-58-0001
2. THIS DRAWING IS TO BE READ IN
CONJUNCTION WITH THE ARCHITECTS AND
STRUCTURAL ENGINEERS DRAWINGS AND
WITH THE PROJECTS SCHEDULES AND
SPECIFICATIONS.
3. THIS DRAWING IS TO BE READ IN
CONJUNCTION WITH THE RELEVANT
DETAILS AND SCHEMATICS.

REV	BY	DATE	CHKD	AMENDMENTS
002	ACB	07-08-17	SKJ	ISSUED FOR CONSTRUCTION, UPDATED FOR ARCHITECTS DETAILS
001	GRY	18-08-17	SKJ	ISSUED FOR CONSTRUCTION, DESIGN TEAM COMMENTS INCORPORATED
000	SD	15-08-16	SKJ	ISSUED FOR APPROVAL

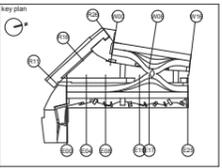

Coal Drops Yard
Western Coal Drops

CONSTRUCTION	
4389	1:150 @ AD
KXC-M1-001	14/09/15
GT	SKJ
BSE4389 P	52-70080 002

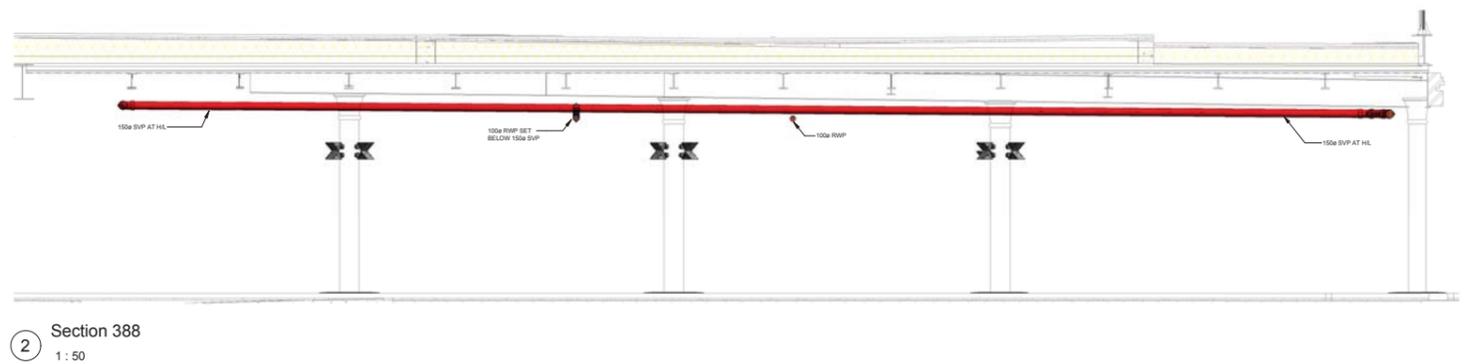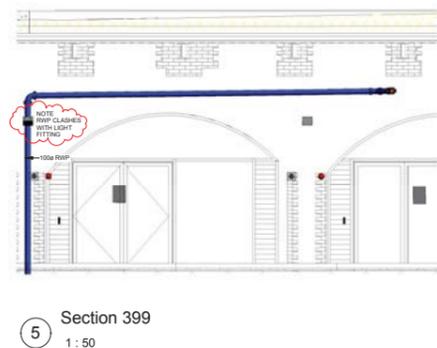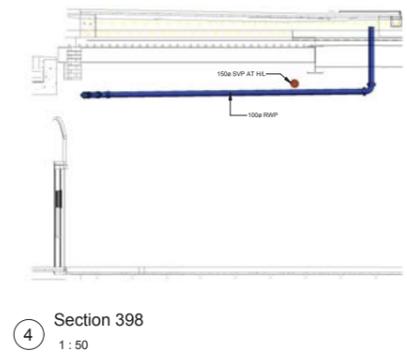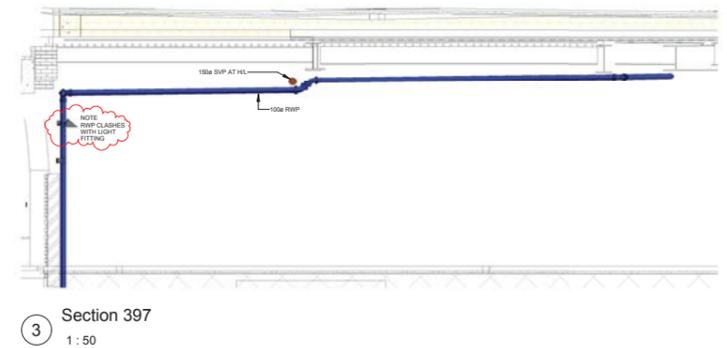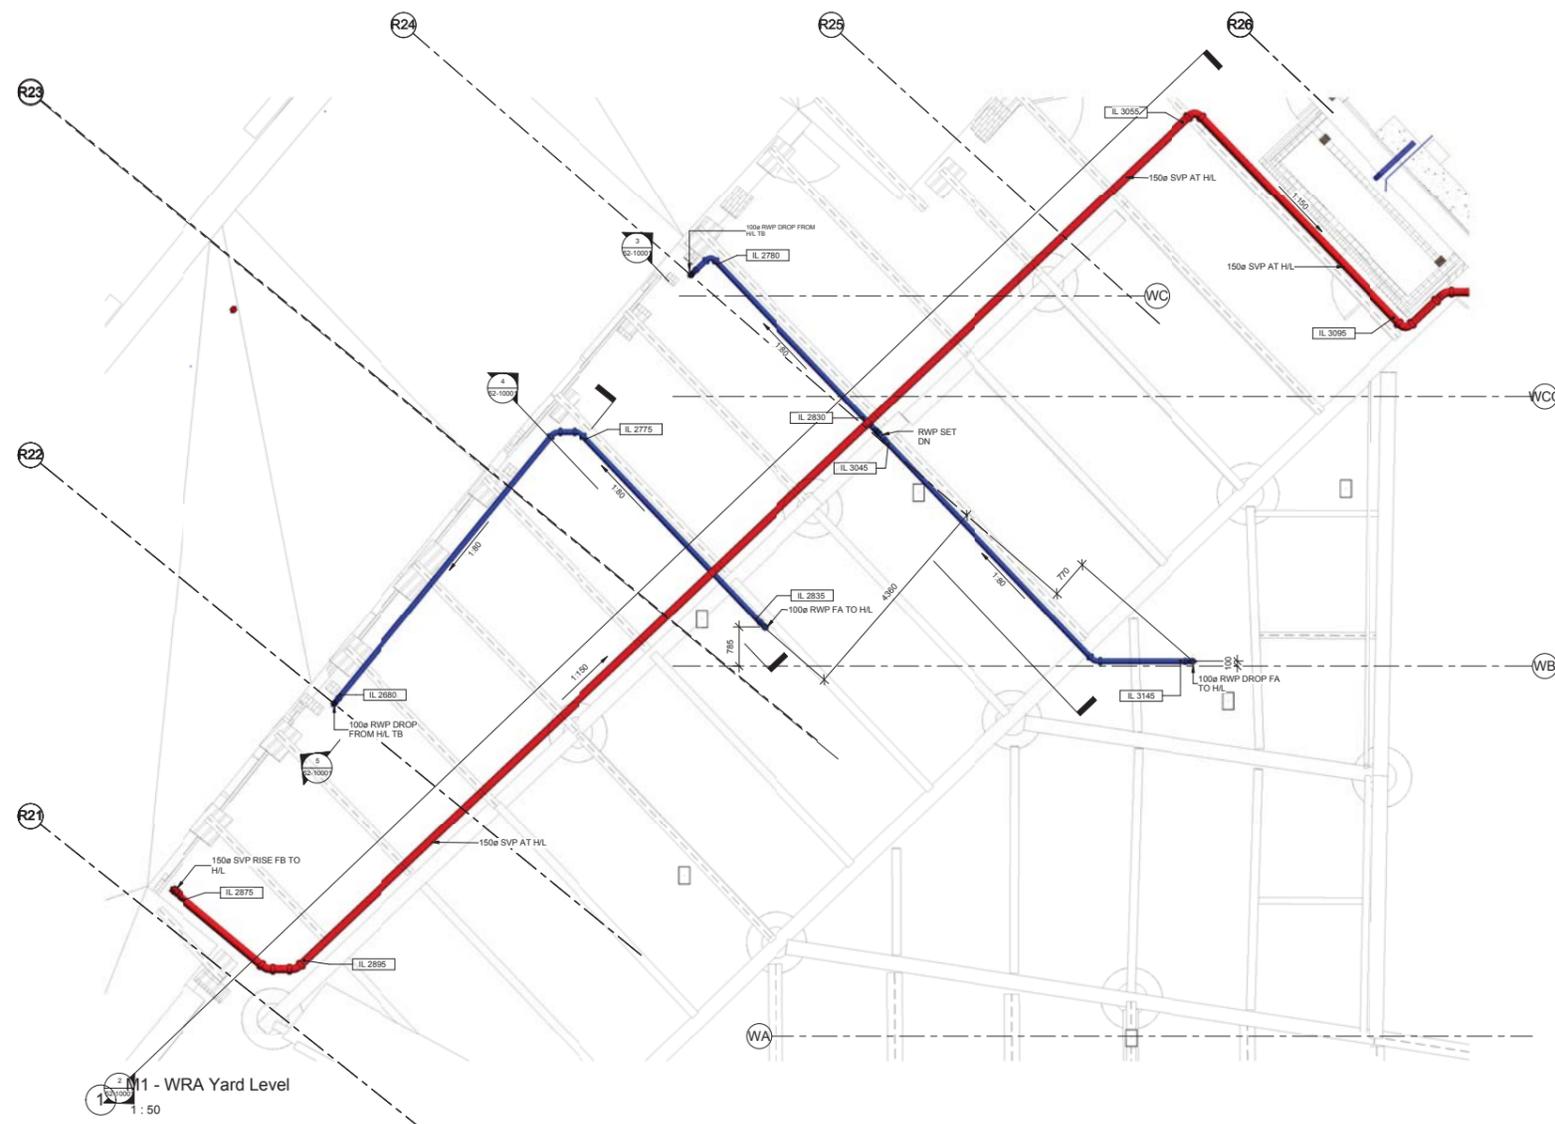


SOFFIT LEVEL	23675
CEILING LEVEL	-
DATUM LEVEL	22020
FINISHED FLOOR LEVEL	21400
STRUCTURAL SLAB LEVEL	21020

SERVICES DATUM LEVELS
 ALL SERVICES ABOVE DATUM DENOTED THUS:
 [Symbol] DISTANCE IN mm TO US OF RECTANGULAR &
 FLAT DUAL DUCTS, ELECTRICAL BUSBARS, CABLE
 LADDERS, TRAYS, TRUNING & CENTRE LINE OF CRC
 DUCTS & PIPEWORK LEVELS PREFIXED IL INDICATES
 INVERT LEVEL OF SOIL, GRAVITY RAINWATER &
 CONDENSATE PIPE ABOVE DATUM LEVEL.
 LEVELS PREFIXED TO P INDICATES LEVEL TO TOP OF
 PIPE FOR SPRINKLING RAINWATER ABOVE DATUM.

- NOTES:
- FOR SYMBOLS LEGEND AND ABBREVIATIONS REFER TO DRAWING BSE4389-M-58-0001
 - THIS DRAWING IS TO BE READ IN CONJUNCTION WITH THE ARCHITECTS AND STRUCTURAL ENGINEERS DRAWINGS AND WITH THE PROJECTS SCHEDULES AND SPECIFICATIONS.
 - THIS DRAWING IS TO BE READ IN CONJUNCTION WITH THE RELEVANT DETAILS AND SCHEMATICS.

ISS	AGB	07/08/17	ISSUED FOR APPROVAL	
REV	BY	DATE	CHG	AMENDMENTS

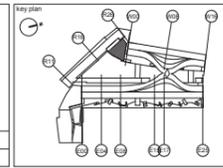

Coal Drops Yard
 Western Coal Drops

YARD LEVEL PUBLIC HEALTH SERVICES GRIDS R21 TO R26 TO WA

APPROVAL			
4389	1:50 @ A0		
KXC-M1-001	09/01/17		
AGB	SKS		
BSE4389 P	52-10001	000	