
	1	2	3	4	5
A					
					6 WHITTLEBURY MEW WEST
В					
	_				
С					
D					FLAT GRP ROOF
E					
					PROPOSED ROOF PLAN
F					1 Scale: 1:50 0 2 3 4 5 M
G					
				ELECTRICAL & LIGHTING KEY	
Н	SITE KEY:			CATE CONNECTION CAT - 6 BT PHONE LINE BT SMOP CONNECTION SKY+ PIR VIRGIN TV VIRGIN SKY+ CONNECTION TV AERIAL TV INT MAGIC EYE ME SHO	COMMUNICATIONS/ DATA SOCKET       C       LIGHT SWITCH       MAINS WATER S         KE / HEAT DETECTOR       S/HD       DULL CORD       P       DIGITAL TV AERIAL         MOVEMENT SENSOR       FIR       LOW VOLTAGE       DOWNLIGHTER       ROOFLIGHT O         SECURITY TERMINAL       ST       DOWNLIGHTER       STRIPLIGHT       STRIPLIGHT         SECURITY SOUNDER       ((is)       PENDANT LAMP       WALL         DOCK DOOR CONTACT       DOORBELL PUSH       SINGLE SWITCH SOCKET
	1	2	3	(/W = WIRELESS)	

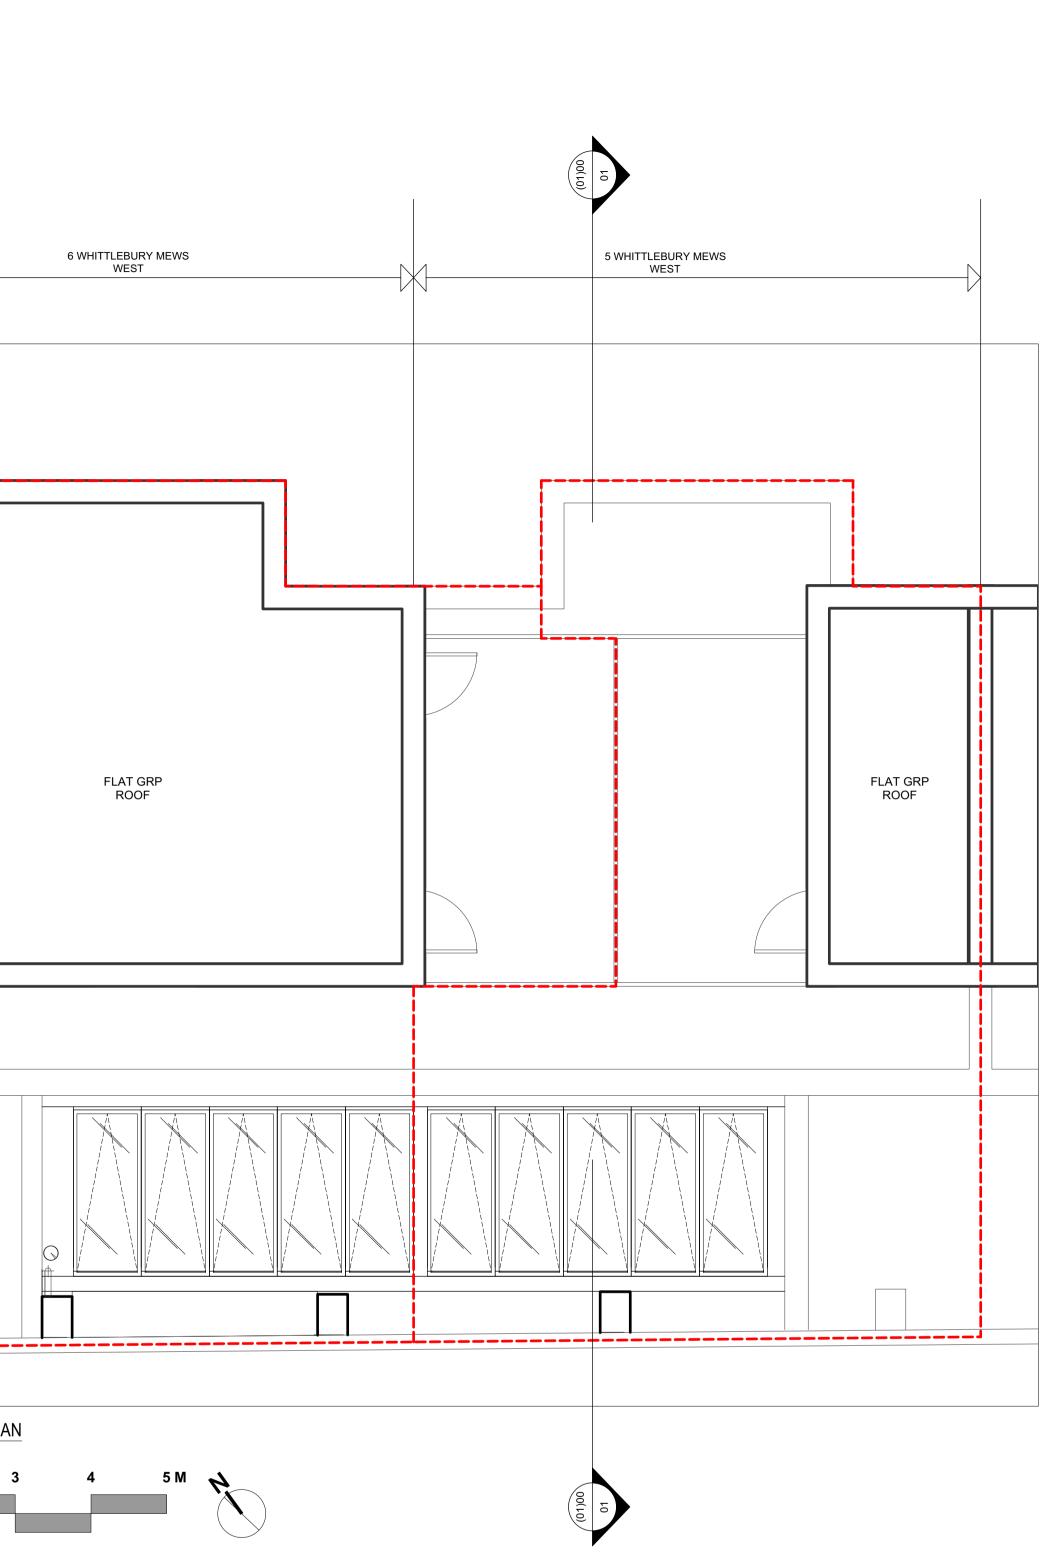

5		6		7	8		9	
PER (( ⊕	TWIN SWITCHED SOCKET	$\overline{\nabla}$				B@XAMI.CO.UK MOBILE +44 (0)7952965033	© 2017 XAMI	
ISH (	SOCKET	~ ~						No
	SINGLE SWITCHED	$\nabla$		3) Bernard Zammit trading as XAMI, All rights are done with a copyrighted work without explicit per			_	A
		V		BY THE CONTRACTOR.				
мр 🕂		SHAVER SOCKET	$\bigtriangledown$	RESPONSIBILITY FOR OBTAINING ALL APPRO	,			
L $\bigoplus$				PARTY WALLS AND WATER BOARD) PRIOR T NO CHECKS HAVE BEEN MADE ON RESTRIC	O COMMENCING WORK.			
05	ROOFLIGHT OPENER	DOOR RELEASE /	DOOR	SURVEY, DESIGN AND STATUTORY APPROV NOT LIMITED TO PLANNING PERMISSION, BU				
	DIGITAL IV AERIAL POINT	TWIN SWITCHED OUTDOOR SOCKET -	IP 66	SERVICES AND FINISHES ARE SHOWN FOR ONLY FOR PLANNING AND ARE SUBJECT TO	CONTRACTOR'S OWN			
	DIGITAL TV AERIAL POINT	TV		GLAZING, GROUND AND OVERHEAD WATERI	PROOFING, M&E			
сн 🖯	MAINS WATER SUPPLY	W TWIN SWITCHED SOCKET WITH USB	USB	<ol> <li>THESE DRAWINGS ARE FOR PLANNING OI CONSTRUCTION.</li> <li>ALL DETAILS INCLUDING EARTH CONDITIC</li> </ol>				

				1811	-	
				1:50@A1 1:100@A3		
A No.	20/09/18 Date			(00)13		
			Date	Date 20 / 09 / 2018		
10			11	12	_	

Α

В

С

D

Е

F

G