


0m 1m 2m 3m 4m 5m  
1:50 scale

KEY

-  Overhead flow and return pipework
-  Underground pipework externally
-  Extract ductwork and air brick
-  FCU
-  Service Riser

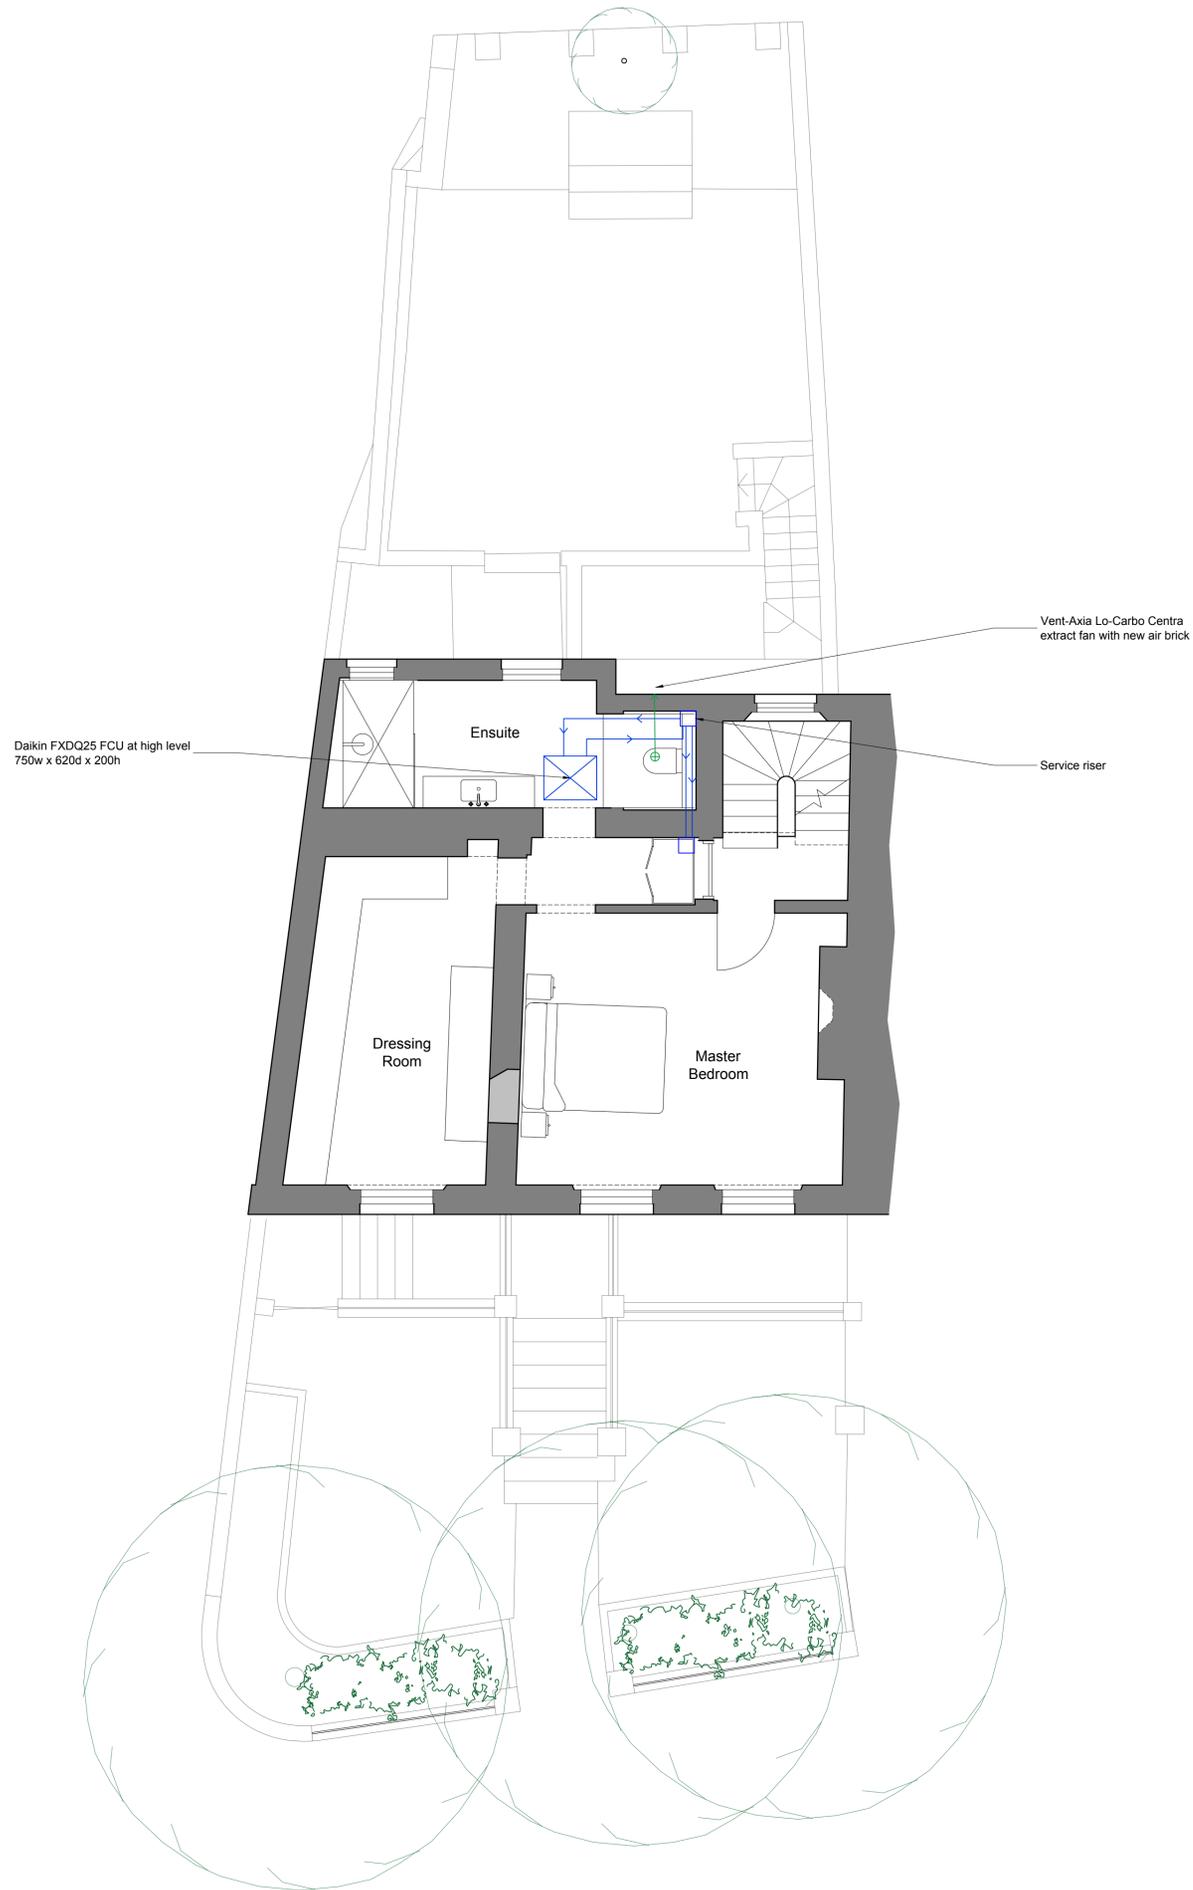

Alterations to room layouts already approved under 2018/1897/P and 2018/2525/L



ALL DIMENSIONS APPROXIMATE

SCHEME DESIGN SUBJECT TO STRUCTURAL ENGINEER / SERVICES ENGINEER, & PLANNERS COMMENT

FOR PLANNING

Client Description | By

**BB PARTNERSHIP** LTD  
CHARTERED ARCHITECTS

Studios 33-34, 10 Hornsey St, London, N7 8EL  
Tel 020 7336 8555 - e-mail - architect@bbpartnership.co.uk

client  
Andrew and Michaela Saffrin

project  
1 The Mount  
Hampstead  
NW3 6SZ

drawing  
Proposed First Floor Plan

date	scale	drawn by
Dec 18	1:50@A1/1:100@A3	MC

drg.no.	revision
FWG_1021	-

© 2018 BB PARTNERSHIP LIMITED - ALL RIGHTS RESERVED  
DO NOT SCALE - CHECK ALL DIMENSIONS ON SITE

Proposed First Floor Plan

1:50