


FOR CONTINUATION SEE DRAWING No. 5557-JSH-XX-ZZ-DR-M-0201

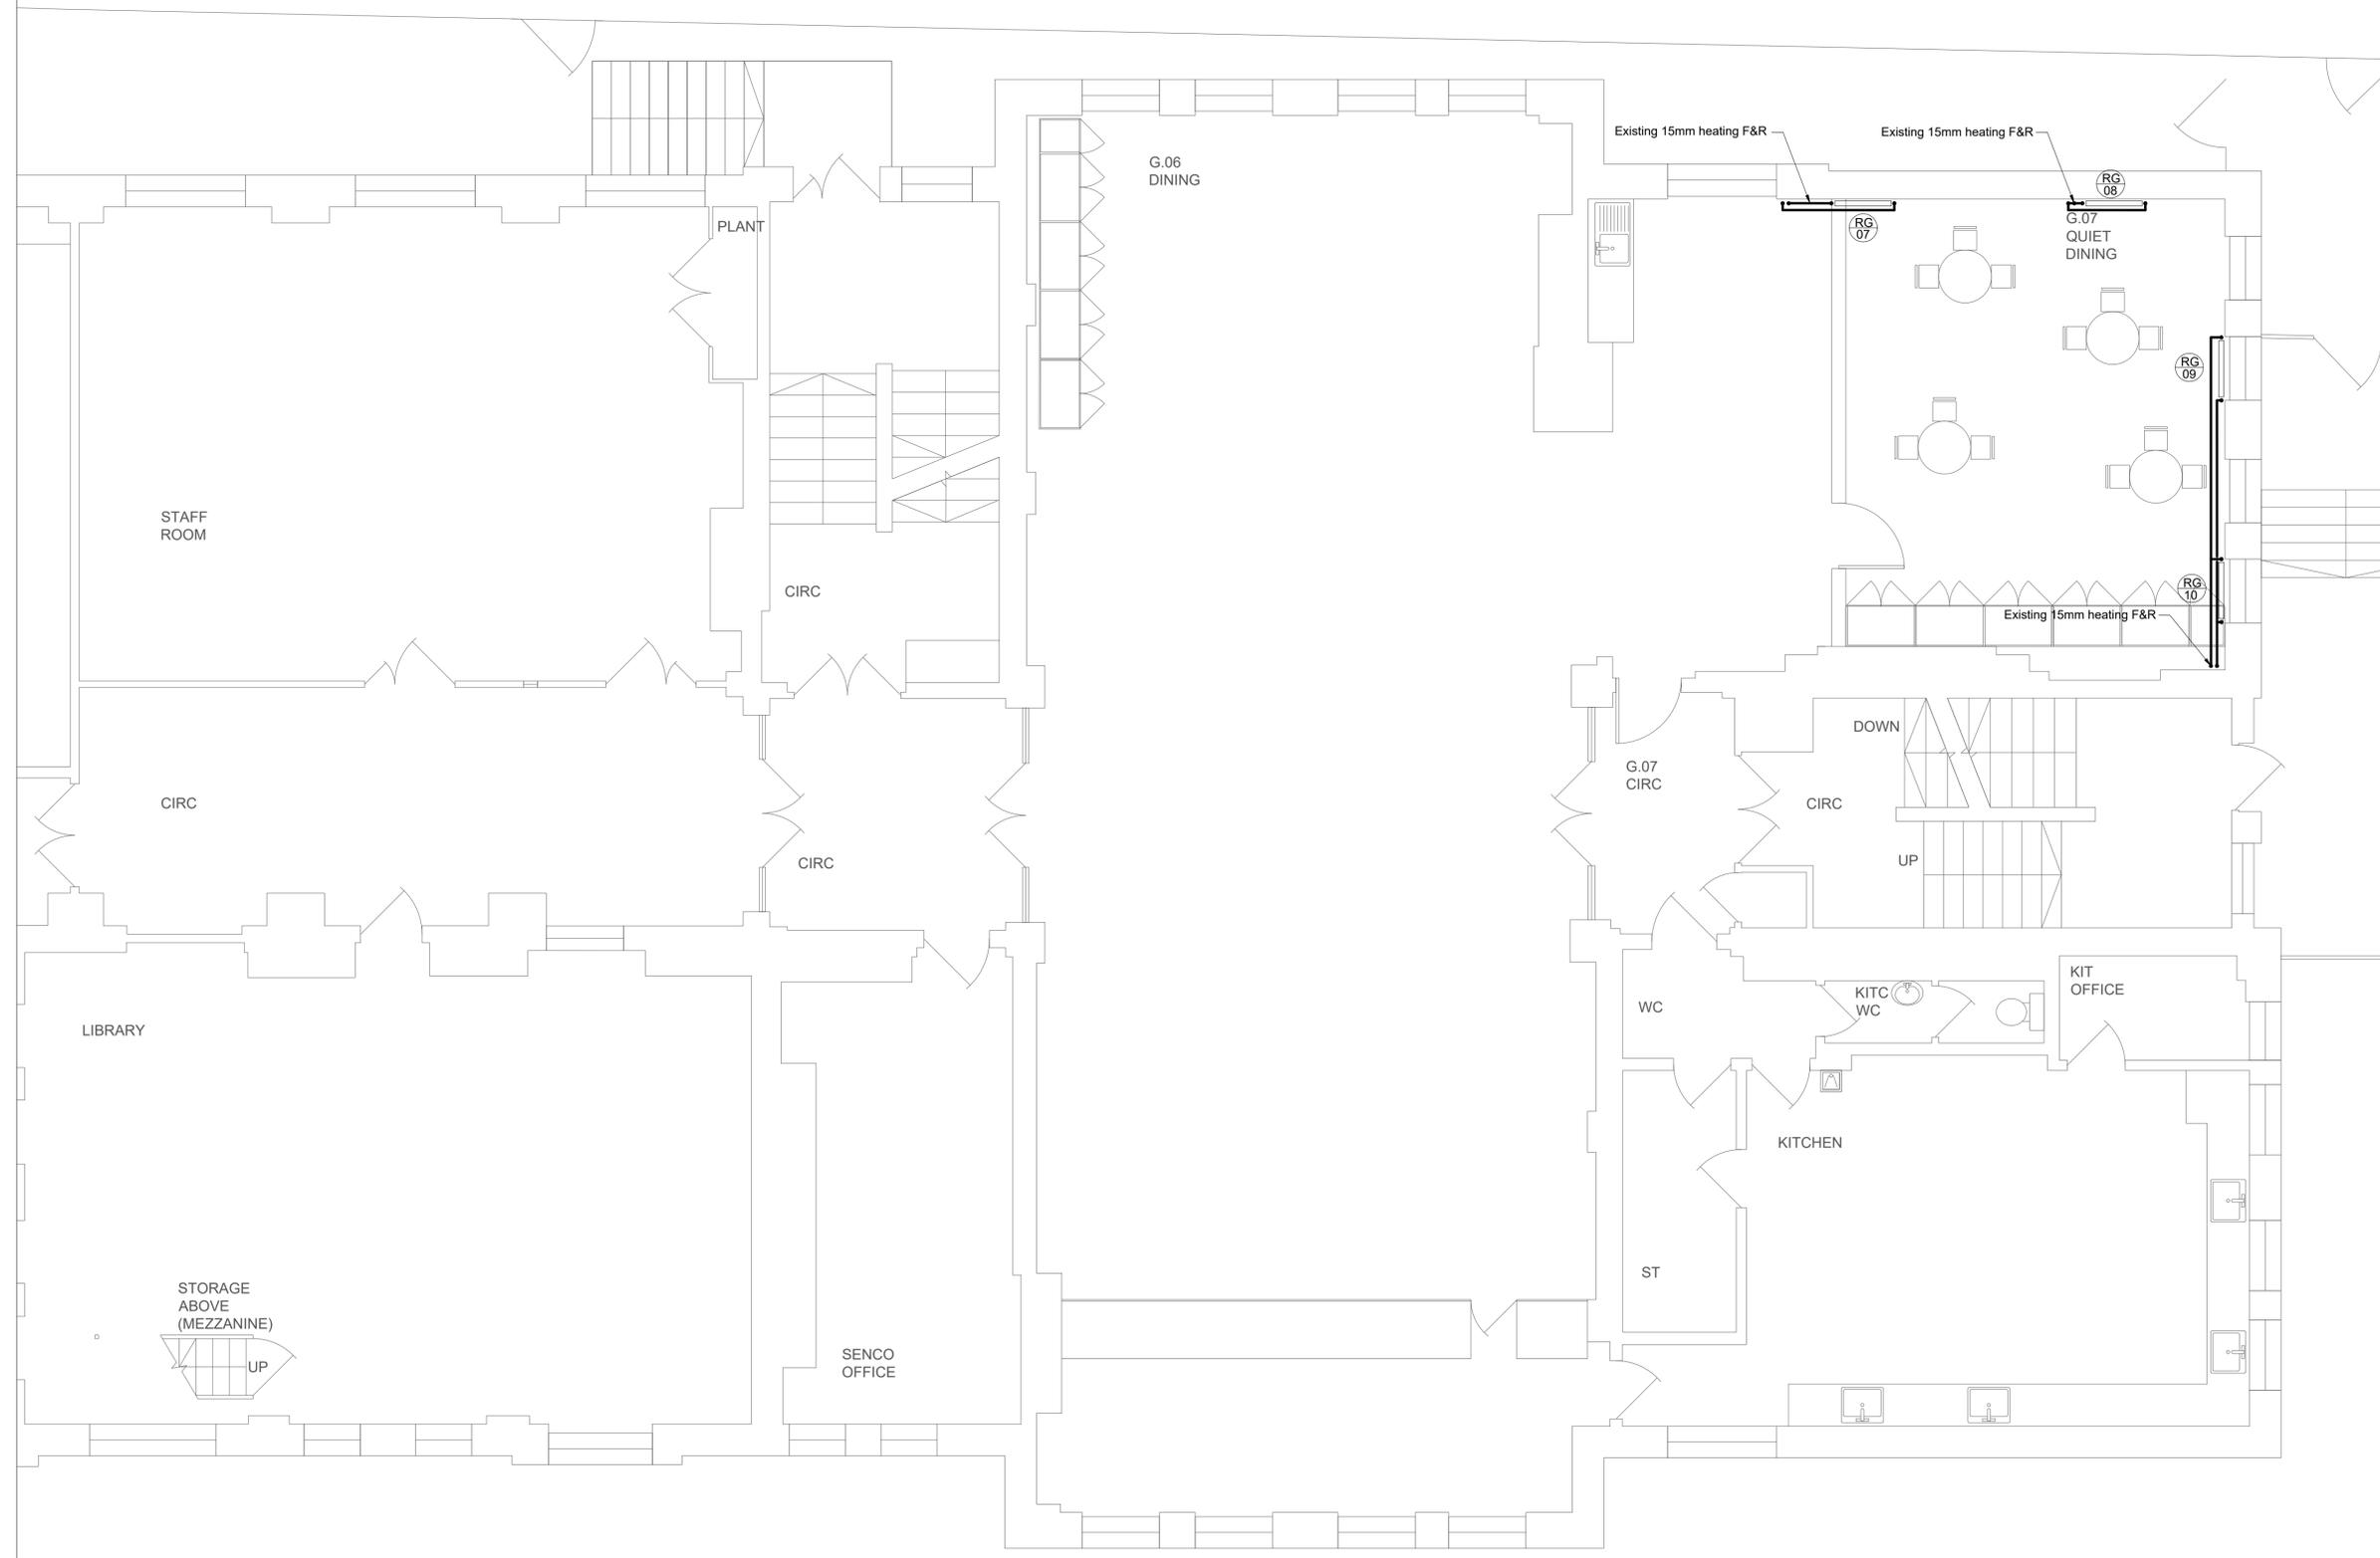

COPYRIGHT
 This drawing is copyright and may not be altered, reproduced or used other than for the Contract Works for which it is issued without written permission.
 © : Johns Slater and Haward Ltd.

- Notes:**
1. This drawing should be read in conjunction with JSH mechanical services specification ref: EB/CR/5557/M.
 2. The School has advised that there is asbestos products in the working areas. The Contractor shall communicate with the Main Contractor and the School prior to any works being undertaken.

- Legend:**
- Pipework run in ceiling void (CV)
 - Pipework run at high level (HL)
 - Pipework run at low level (LL)
 - Pipework run below ground level (UG)
 - Pipework drop / rise
 - Existing Pipework run in ceiling void (CV)
 - Existing Pipework run at high level (HL)
 - Existing Pipework run at low level (LL)
 - Existing Pipework run below ground level (UG)
 - Existing Pipework drop / rise
 - ⊘ Isolating valve (IV)
 - ⊘ Commissioning set (CS)
 - ⊘ Radiator

Radiators Schedule									
RAD REF	LOCATION	MANUFACTURER	MODEL	TYPE	HEIGHT (mm)	LENGTH (mm)	OUTPUT (W)	VALVES	NOTES
RG7	ARP/Quiet Dining	-	-	-	-	-	1672	-	Existing
RG8	ARP/Quiet Dining	-	-	-	-	-	1672	-	Existing
RG9	ARP/Quiet Dining	-	-	-	-	-	1672	-	Existing
RG10	ARP/Quiet Dining	-	-	-	-	-	1672	-	Existing

P01	Tender Issue	CR	EB	05/19
REV	DESCRIPTION	DR'WN	CHK'D	DATE

Johns Slater and Haward
 Chartered Building Services Consultants
Ardennais House, 6 Sorrel Horse Mews, Grimwade St, Ipswich IP4 1LN
 01473 255965, engineers@jshipswich.co.uk, www.jshipswich.co.uk



CLIENT:

PROJECT:
 Primrose Hill Primary School ARP

DRG TITLE:
 Ground Floor
 Proposed Heating Layout
 Sheet 2 of 2

SCALE: 1:50 @ A1	STATUS: D2 - Tender	PROJECT: 5557.00	ORIGINATOR: JSH
ZONE: XX	LEVEL: 00	TYPE: DR	DRG No. REV M-0202 P01