

NOTES

- DO NOT SCALE FROM THIS DRAWING.
- ALL SETTING OUT TO BE AGREED WITH ARCHITECT.
- TO BE READ IN CONJUNCTION WITH ALL LAYOUTS, DETAILS, SCHEDULES AND SPECIFICATIONS.
- NOTE THAT THIS DRAWING REPRESENTS A VIEW INTO A 3D MODEL. NOT ALL COMPONENTS ARE VISIBLE IN ALL VIEWS AND ONE COMPONENT MAY BE CONCEALED BELOW ANOTHER COMPONENT. IF IN DOUBT REFER TO THE 3D MODEL AND SCHEMATIC AS WELL AS ALL ACCOMPANYING DRAWINGS.
- ALL DUCTWORK TO BE GALVANIZED STEEL SHEET METAL AND SPIRAL IN ACCORDANCE WITH DW144.
- ALL DUCTWORK ABOVE BAFFLE TYPE CEILING TO BE BLACK FINISH.
- VENTILATION IN WCs AND SANITARY AREAS IS TO BE CONTROLLED IN TRICKLE AND BOOST MODE BY LOCAL PIRs SHARED WITH THE LIGHTING.
- GRILLE ON ALL BULKHEADS TO HAVE CONTINUOUS FACING GRILLE AS INDICATED IN ARCHITECTS DRAWINGS. WHERE NO ACTIVE GRILLE IS SPECIFIED IN ILES CONSULTING GRILLE SCHEDULE ASSUME BULKHEAD TO BE AS EG05. GRILLES TO BE FULL LENGTH OF BULKHEAD AND TO BE CO-ORDINATED WITH INTERIORS AND SITE MEASURED.
- ALL AHU SUPPLY AND EXTRACT DUCTWORK TO BE THERMALLY INSULATED.
- THIS DRAWING DOES NOT SHOW SMOKE EXTRACT SYSTEM OR ASSOCIATED COMPONENTS.
- FIRE & FIRE SMOKE DAMPERS TO BE INSTALLED IN ACCORDANCE WITH THE FIRE STRATEGY.
- MOTORISED VOLUME CONTROL DAMPERS TO BE INSTALLED IN ACCORDANCE WITH THE BMS CONTROLS STRATEGY.

LEGEND

- AHU 1 SUPPLY AIR
  - AHU 1 EXTRACT AIR
  - AHU 2 SUPPLY AIR
  - AHU 2 EXTRACT AIR
  - AHU 3 SUPPLY AIR
  - AHU 3 EXTRACT AIR
  - AHU 4 SUPPLY AIR
  - AHU 4 EXTRACT AIR
  - AHU 5 SUPPLY AIR
  - AHU 5 EXTRACT AIR
  - FCU SUPPLY AIR
  - EXHAUST AIR
  - FRESH AIR
  - SMOKE EXTRACT
- SD-SUPPLY VALVE  
 SG-SUPPLY GRILLE  
 EG-EXTRACT GRILLE  
 ED-EXTRACT VALVE  
 FD-FIRE DAMPER  
 FSD-FIRE AND SMOKE DAMPER  
 VAV-VAV VOLUME CONTROL DAMPER  
 BD-BALANCING DAMPER  
 CTA-CROSS TALK ATTENUATOR  
 ATT-ATTENUATOR  
 FCU-FAN COIL UNIT  
 Pxx-PLENUM REF  
 Gxx-GRILLE REF

C3	ISSUED FOR CONSTRUCTION	SRW	MI	11.02.20
C2	ISSUED FOR CONSTRUCTION	SRW	DB	31.01.20
C1	ISSUED FOR CONSTRUCTION	SRW	MI	13.01.20

Rev.	Description	Drawn	Chkd	Date
------	-------------	-------	------	------

For Construction

Architect  
**GIBBERD**  
 Client  
**ELEMENTS M&E CONTRACTING LTD**

Project  
**CAMBRIDGE HOUSE, BIRKBECK COLLEGE**


Drawing Title:  
**BASEMENT FLOOR VENTILATION LAYOUT**

**iles consulting** IC  
 ENGINEERING EXCELLENCE  
 ILES Consulting Ltd  
 Metropolitan House, Longrigg Road, Swilwell, Gateshead NE16 3AS  
 t: 0191 4966250 f: 0191 4967500 e: mail@ilesconsulting.co.uk www.ilesconsulting.co.uk

REVIT Directory: I:\Projects\19-000\19-011\Drawings\

Drawing Size: A1 Scale: 1 : 50

Dwg No: 19-011-M-57-99-001 Rev: C3

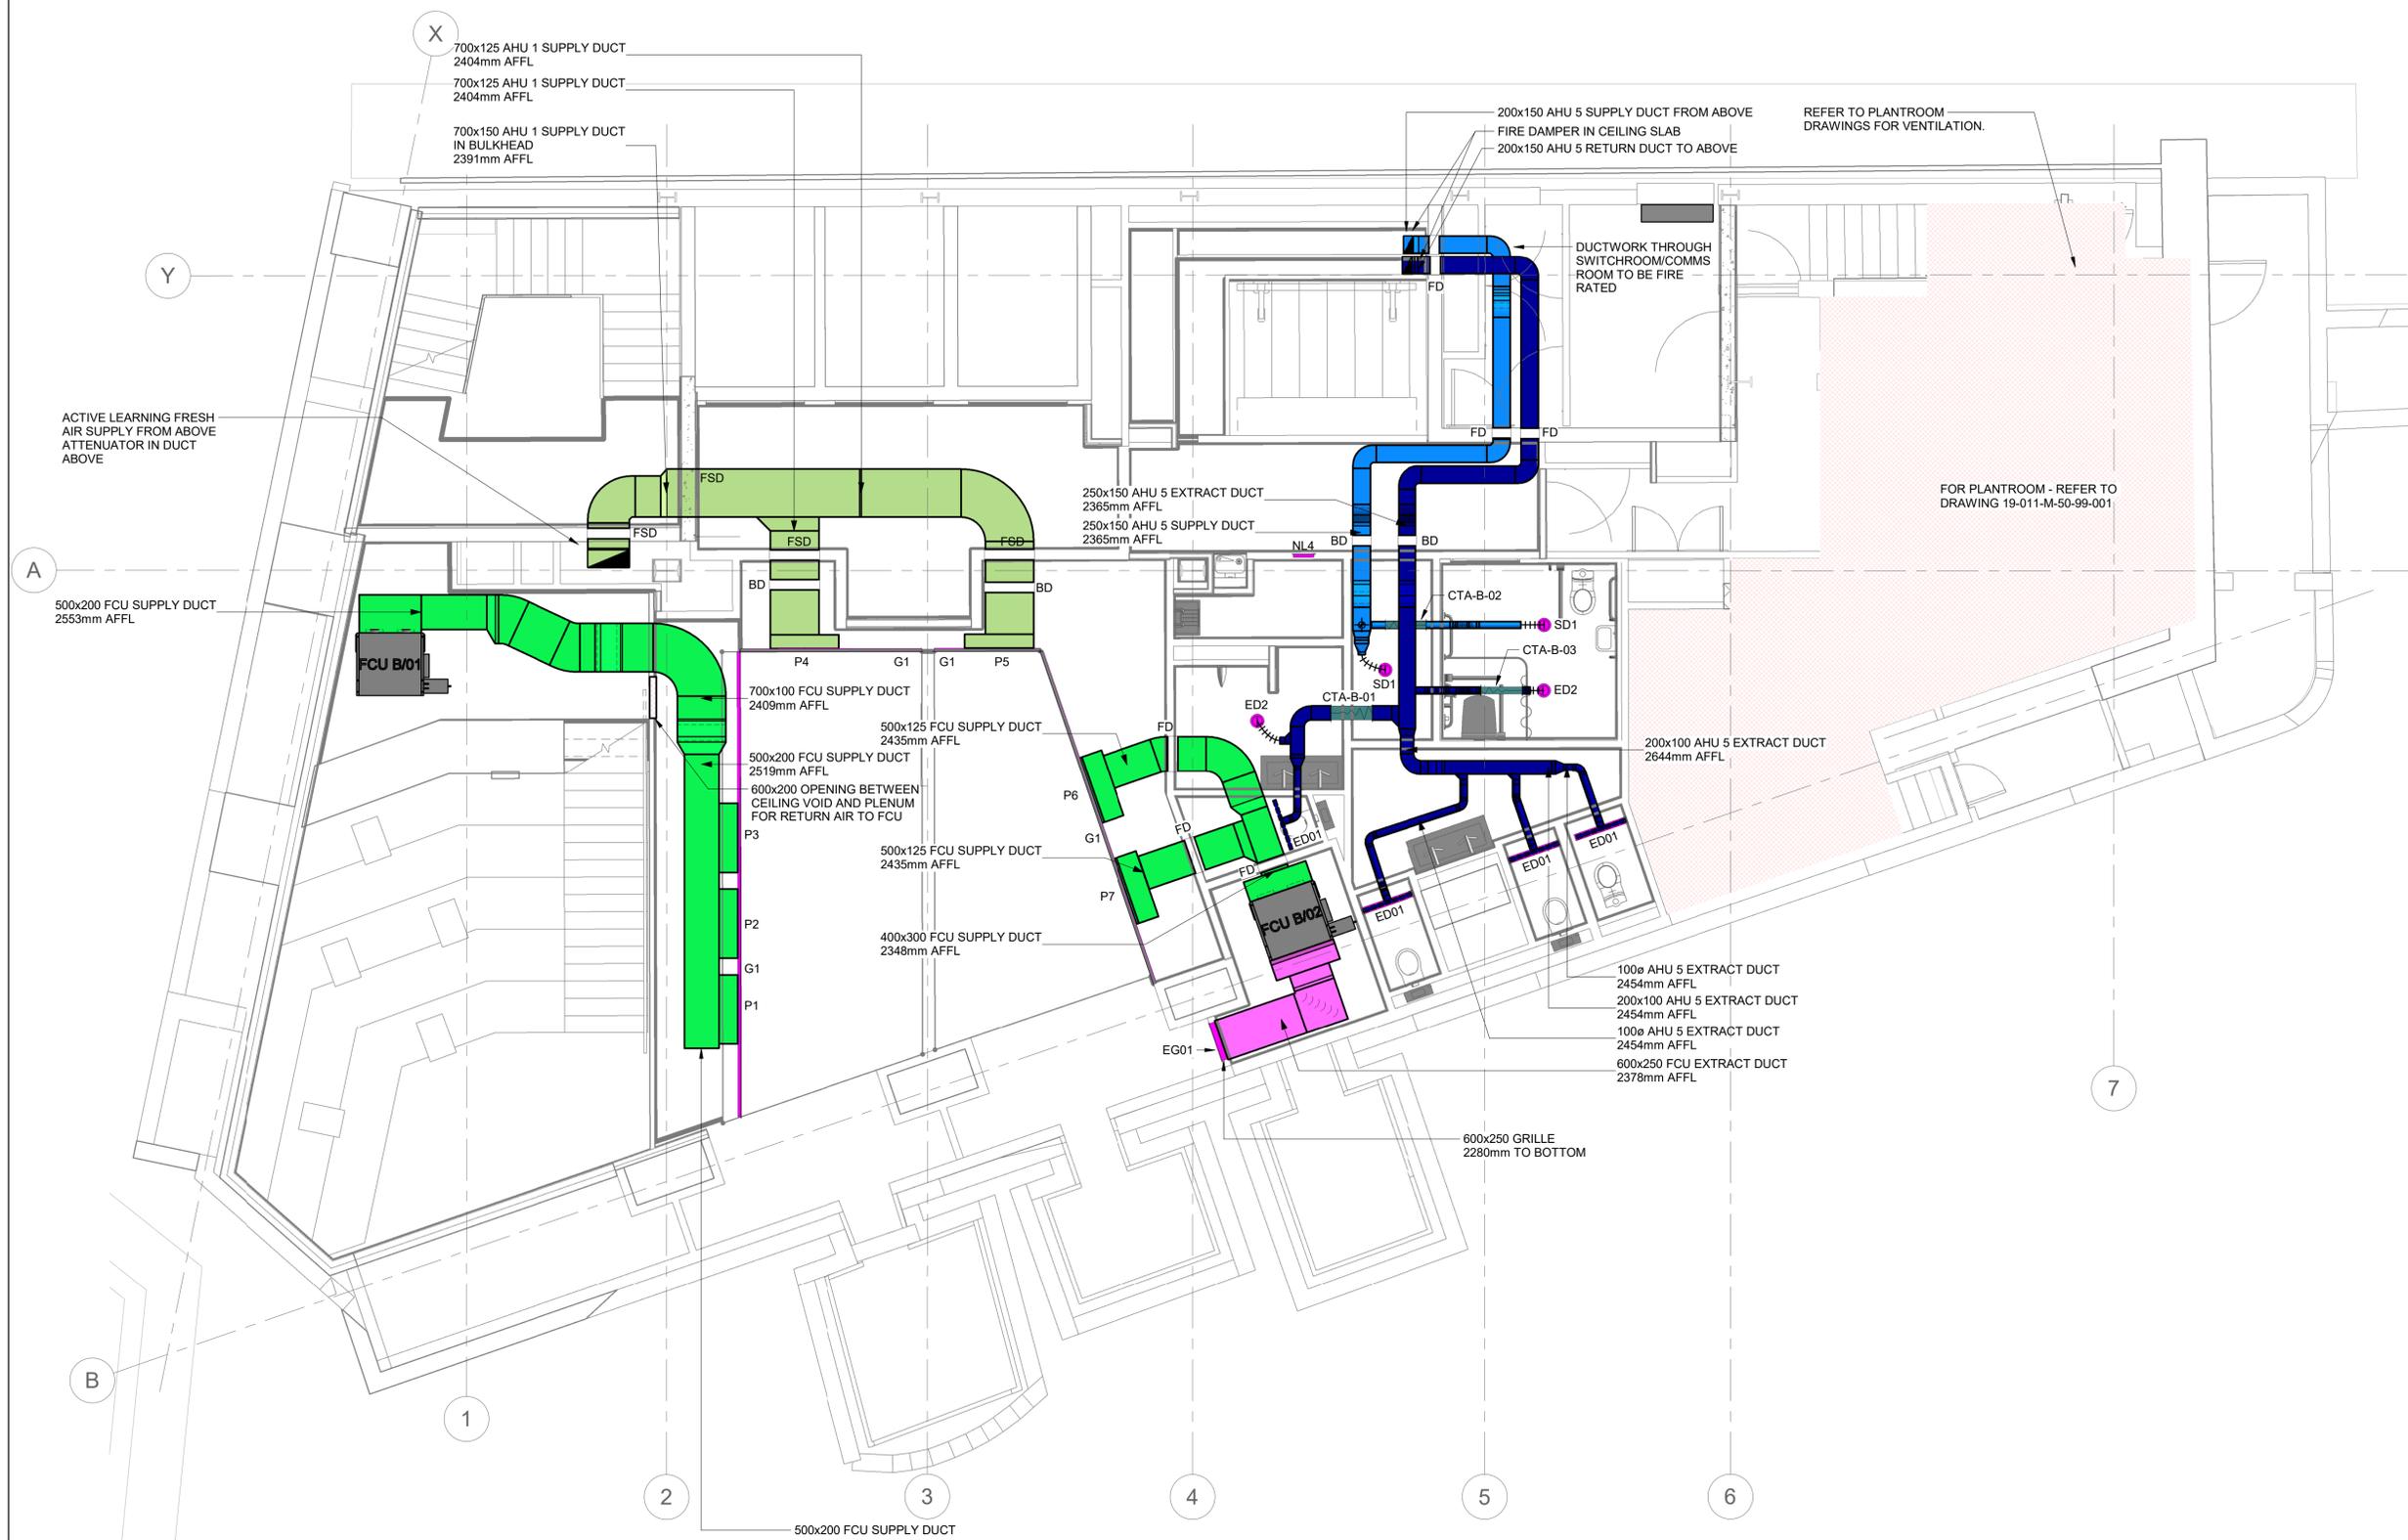

NOTES

- DO NOT SCALE FROM THIS DRAWING.
- ALL SETTING OUT TO BE AGREED WITH ARCHITECT.
- TO BE READ IN CONJUNCTION WITH ALL LAYOUTS, DETAILS, SCHEDULES AND SPECIFICATIONS.
- NOTE THAT THIS DRAWING REPRESENTS A VIEW INTO A 3D MODEL. NOT ALL COMPONENTS ARE VISIBLE IN ALL VIEWS AND ONE COMPONENT MAY BE CONCEALED BELOW ANOTHER COMPONENT. IF IN DOUBT REFER TO THE 3D MODEL AND SCHEMATIC AS WELL AS ALL ACCOMPANYING DRAWINGS.
- ALL DUCTWORK TO BE GALVANIZED STEEL SHEET METAL AND SPIRAL IN ACCORDANCE WITH DW144.
- ALL DUCTWORK ABOVE BAFFLE TYPE CEILINGS TO BE BLACK FINISH.
- VENTILATION IN WCs AND SANITARY AREAS IS TO BE CONTROLLED IN TRICKLE AND BOOST MODE BY LOCAL PIRs SHARED WITH THE LIGHTING.
- GRILLE ON ALL BULKHEADS TO HAVE CONTINUOUS FACING GRILLE AS INDICATED IN ARCHITECTS DRAWINGS, WHERE NO ACTIVE GRILLE IS SPECIFIED IN ILES CONSULTING GRILLE SCHEDULE ASSUME BULKHEAD TO BE AS EG05. GRILLES TO BE FULL LENGTH OF BULKHEAD AND TO BE CO-ORDINATED WITH INTERIORS AND SITE MEASURED.
- ALL AHU SUPPLY AND EXTRACT DUCTWORK TO BE THERMALLY INSULATED.
- THIS DRAWING DOES NOT SHOW SMOKE EXTRACT SYSTEM OR ASSOCIATED COMPONENTS.
- FIRE & FIRE SMOKE DAMPERS TO BE INSTALLED IN ACCORDANCE WITH THE FIRE STRATEGY.
- MOTORIZED VOLUME CONTROL DAMPERS TO BE INSTALLED IN ACCORDANCE WITH THE BMS CONTROLS STRATEGY.

LEGEND

- AHU 1 SUPPLY AIR
- AHU 1 EXTRACT AIR
- AHU 2 SUPPLY AIR
- AHU 2 EXTRACT AIR
- AHU 3 SUPPLY AIR
- AHU 3 EXTRACT AIR
- AHU 4 SUPPLY AIR
- AHU 4 EXTRACT AIR
- AHU 5 SUPPLY AIR
- AHU 5 EXTRACT AIR
- FCU SUPPLY AIR
- EXHAUST AIR
- FRESH AIR
- SMOKE EXTRACT
- SD-SUPPLY VALVE
- SG-SUPPLY GRILLE
- EG-EXTRACT GRILLE
- ED-EXTRACT VALVE
- FD-FIRE DAMPER
- FSD-FIRE AND SMOKE DAMPER
- VAV-VAV VOLUME CONTROL DAMPER
- BD-BALANCING DAMPER
- CTA-CROSS TALK ATTENUATOR
- ATT-ATTENUATOR
- FCU-FAN COIL UNIT
- Pxx-PLENUM REF
- Gxx-GRILLE REF

C3	ISSUED FOR CONSTRUCTION	SRW	MI	11.02.20
C2	ISSUED FOR CONSTRUCTION	SRW	DB	31.01.20
C1	ISSUED FOR CONSTRUCTION	SRW	MI	13.01.20

Rev.	Description	Drawn	Chkd	Date

For Construction

Architect  
**GIBBERD**  
Client  
**ELEMENTS M&E CONTRACTING LTD**

Project  
**CAMBRIDGE HOUSE, BIRKBECK COLLEGE**


Drawing Title:  
**GROUND FLOOR VENTILATION LAYOUT**



REVISION Directory: I:\Projects\19-000\19-011\Drawings\

Drawing Size: A1 Scale: 1 : 50

Dwg No: 19-011-M-57-00-001 Rev: C3

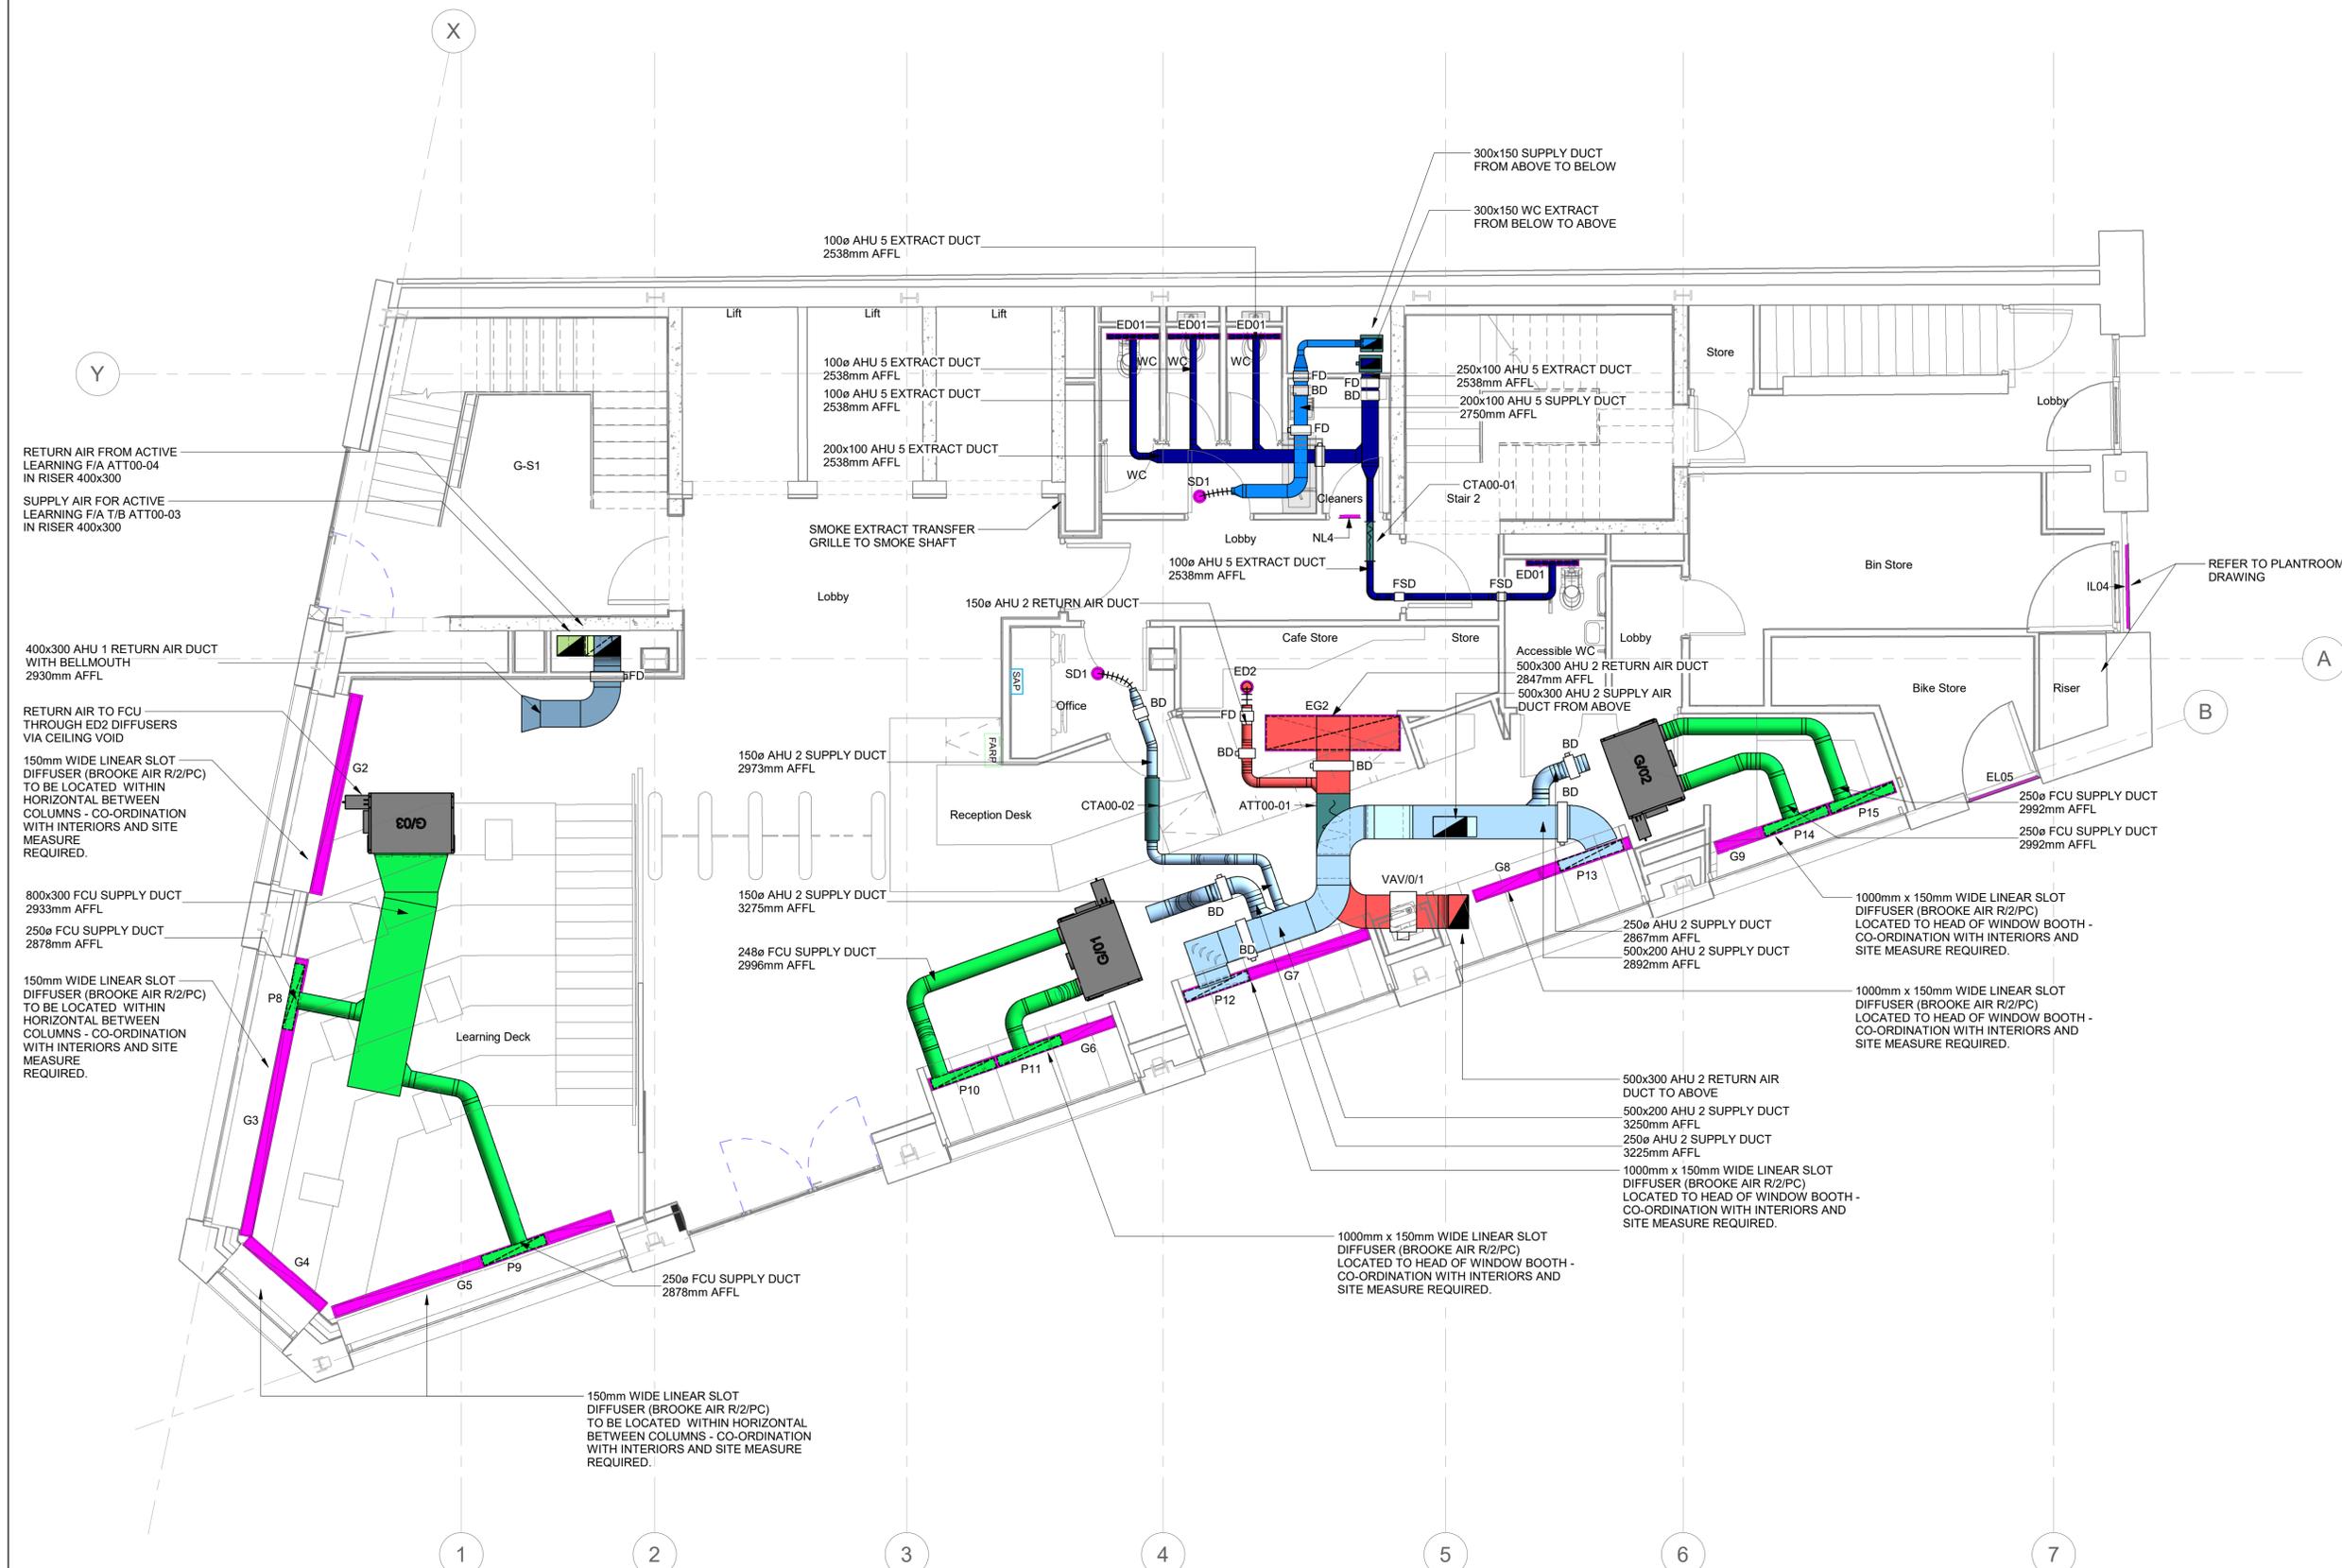

NOTES

- DO NOT SCALE FROM THIS DRAWING.
- ALL SETTING OUT TO BE AGREED WITH ARCHITECT.
- TO BE READ IN CONJUNCTION WITH ALL LAYOUTS, DETAILS, SCHEDULES AND SPECIFICATIONS.
- NOTE THAT THIS DRAWING REPRESENTS A VIEW INTO A 3D MODEL. NOT ALL COMPONENTS ARE VISIBLE IN ALL VIEWS AND ONE COMPONENT MAY BE CONCEALED BELOW ANOTHER COMPONENT. IF IN DOUBT REFER TO THE 3D MODEL AND SCHEMATIC AS WELL AS ALL ACCOMPANYING DRAWINGS.
- ALL DUCTWORK TO BE GALVANIZED STEEL SHEET METAL AND SPIRAL IN ACCORDANCE WITH DW144.
- ALL DUCTWORK ABOVE BAFFLE TYPE CEILING TO BE BLACK FINISH.
- VENTILATION IN WCs AND SANITARY AREAS IS TO BE CONTROLLED IN TRICKLE AND BOOST MODE BY LOCAL PIRs SHARED WITH THE LIGHTING.
- GRILLE ON ALL BULKHEADS TO HAVE CONTINUOUS FACING GRILLE AS INDICATED IN ARCHITECTS DRAWINGS, WHERE NO ACTIVE GRILLE IS SPECIFIED IN ILES CONSULTING GRILLE SCHEDULE ASSUME BULKHEAD TO BE AS EG05. GRILLES TO BE FULL LENGTH OF BULKHEAD AND TO BE CO-ORDINATED WITH INTERIORS AND SITE MEASURED.
- ALL AHU SUPPLY AND EXTRACT DUCTWORK TO BE THERMALLY INSULATED.
- THIS DRAWING DOES NOT SHOW SMOKE EXTRACT SYSTEM OR ASSOCIATED COMPONENTS.
- FIRE & FIRE SMOKE DAMPERS TO BE INSTALLED IN ACCORDANCE WITH THE FIRE STRATEGY.
- MOTORIZED VOLUME CONTROL DAMPERS TO BE INSTALLED IN ACCORDANCE WITH THE BMS CONTROLS STRATEGY.

LEGEND

- AHU 1 SUPPLY AIR
  - AHU 1 EXTRACT AIR
  - AHU 2 SUPPLY AIR
  - AHU 2 EXTRACT AIR
  - AHU 3 SUPPLY AIR
  - AHU 3 EXTRACT AIR
  - AHU 4 SUPPLY AIR
  - AHU 4 EXTRACT AIR
  - AHU 5 SUPPLY AIR
  - AHU 5 EXTRACT AIR
  - FCU SUPPLY AIR
  - EXHAUST AIR
  - FRESH AIR
  - SMOKE EXTRACT
- SD-SUPPLY VALVE  
SG-SUPPLY GRILLE  
EG-EXTRACT GRILLE  
ED-EXTRACT VALVE  
FD-FIRE DAMPER  
FSD-FIRE AND SMOKE DAMPER  
VAV-VAV VOLUME CONTROL DAMPER  
BD-BALANCING DAMPER  
CTA-CROSS TALK ATTENUATOR  
ATT-ATTENUATOR  
FCU-FAN COIL UNIT  
Px-PLENUM REF  
Gxx-GRILLE REF

C3	ISSUED FOR CONSTRUCTION	SRW	MI	11.02.20
C2	ISSUED FOR CONSTRUCTION	SRW	DB	31.01.20
C1	ISSUED FOR CONSTRUCTION	SRW	MI	13.01.20
Rev.	Description	Drawn	Chkd	Date

For Construction

Architect  
**GIBBERD**  
Client  
**ELEMENTS M&E CONTRACTING LTD**

Project  
**CAMBRIDGE HOUSE, BIRKBECK COLLEGE**


Drawing Title:  
**FIRST FLOOR VENTILATION LAYOUT**



REVISIT Directory: I:\Projects\19-000\19-011\Drawings\

Drawing Size: A1 Scale: 1 : 50

Dwg No: 19-011-M-57-01-001 Rev: C3

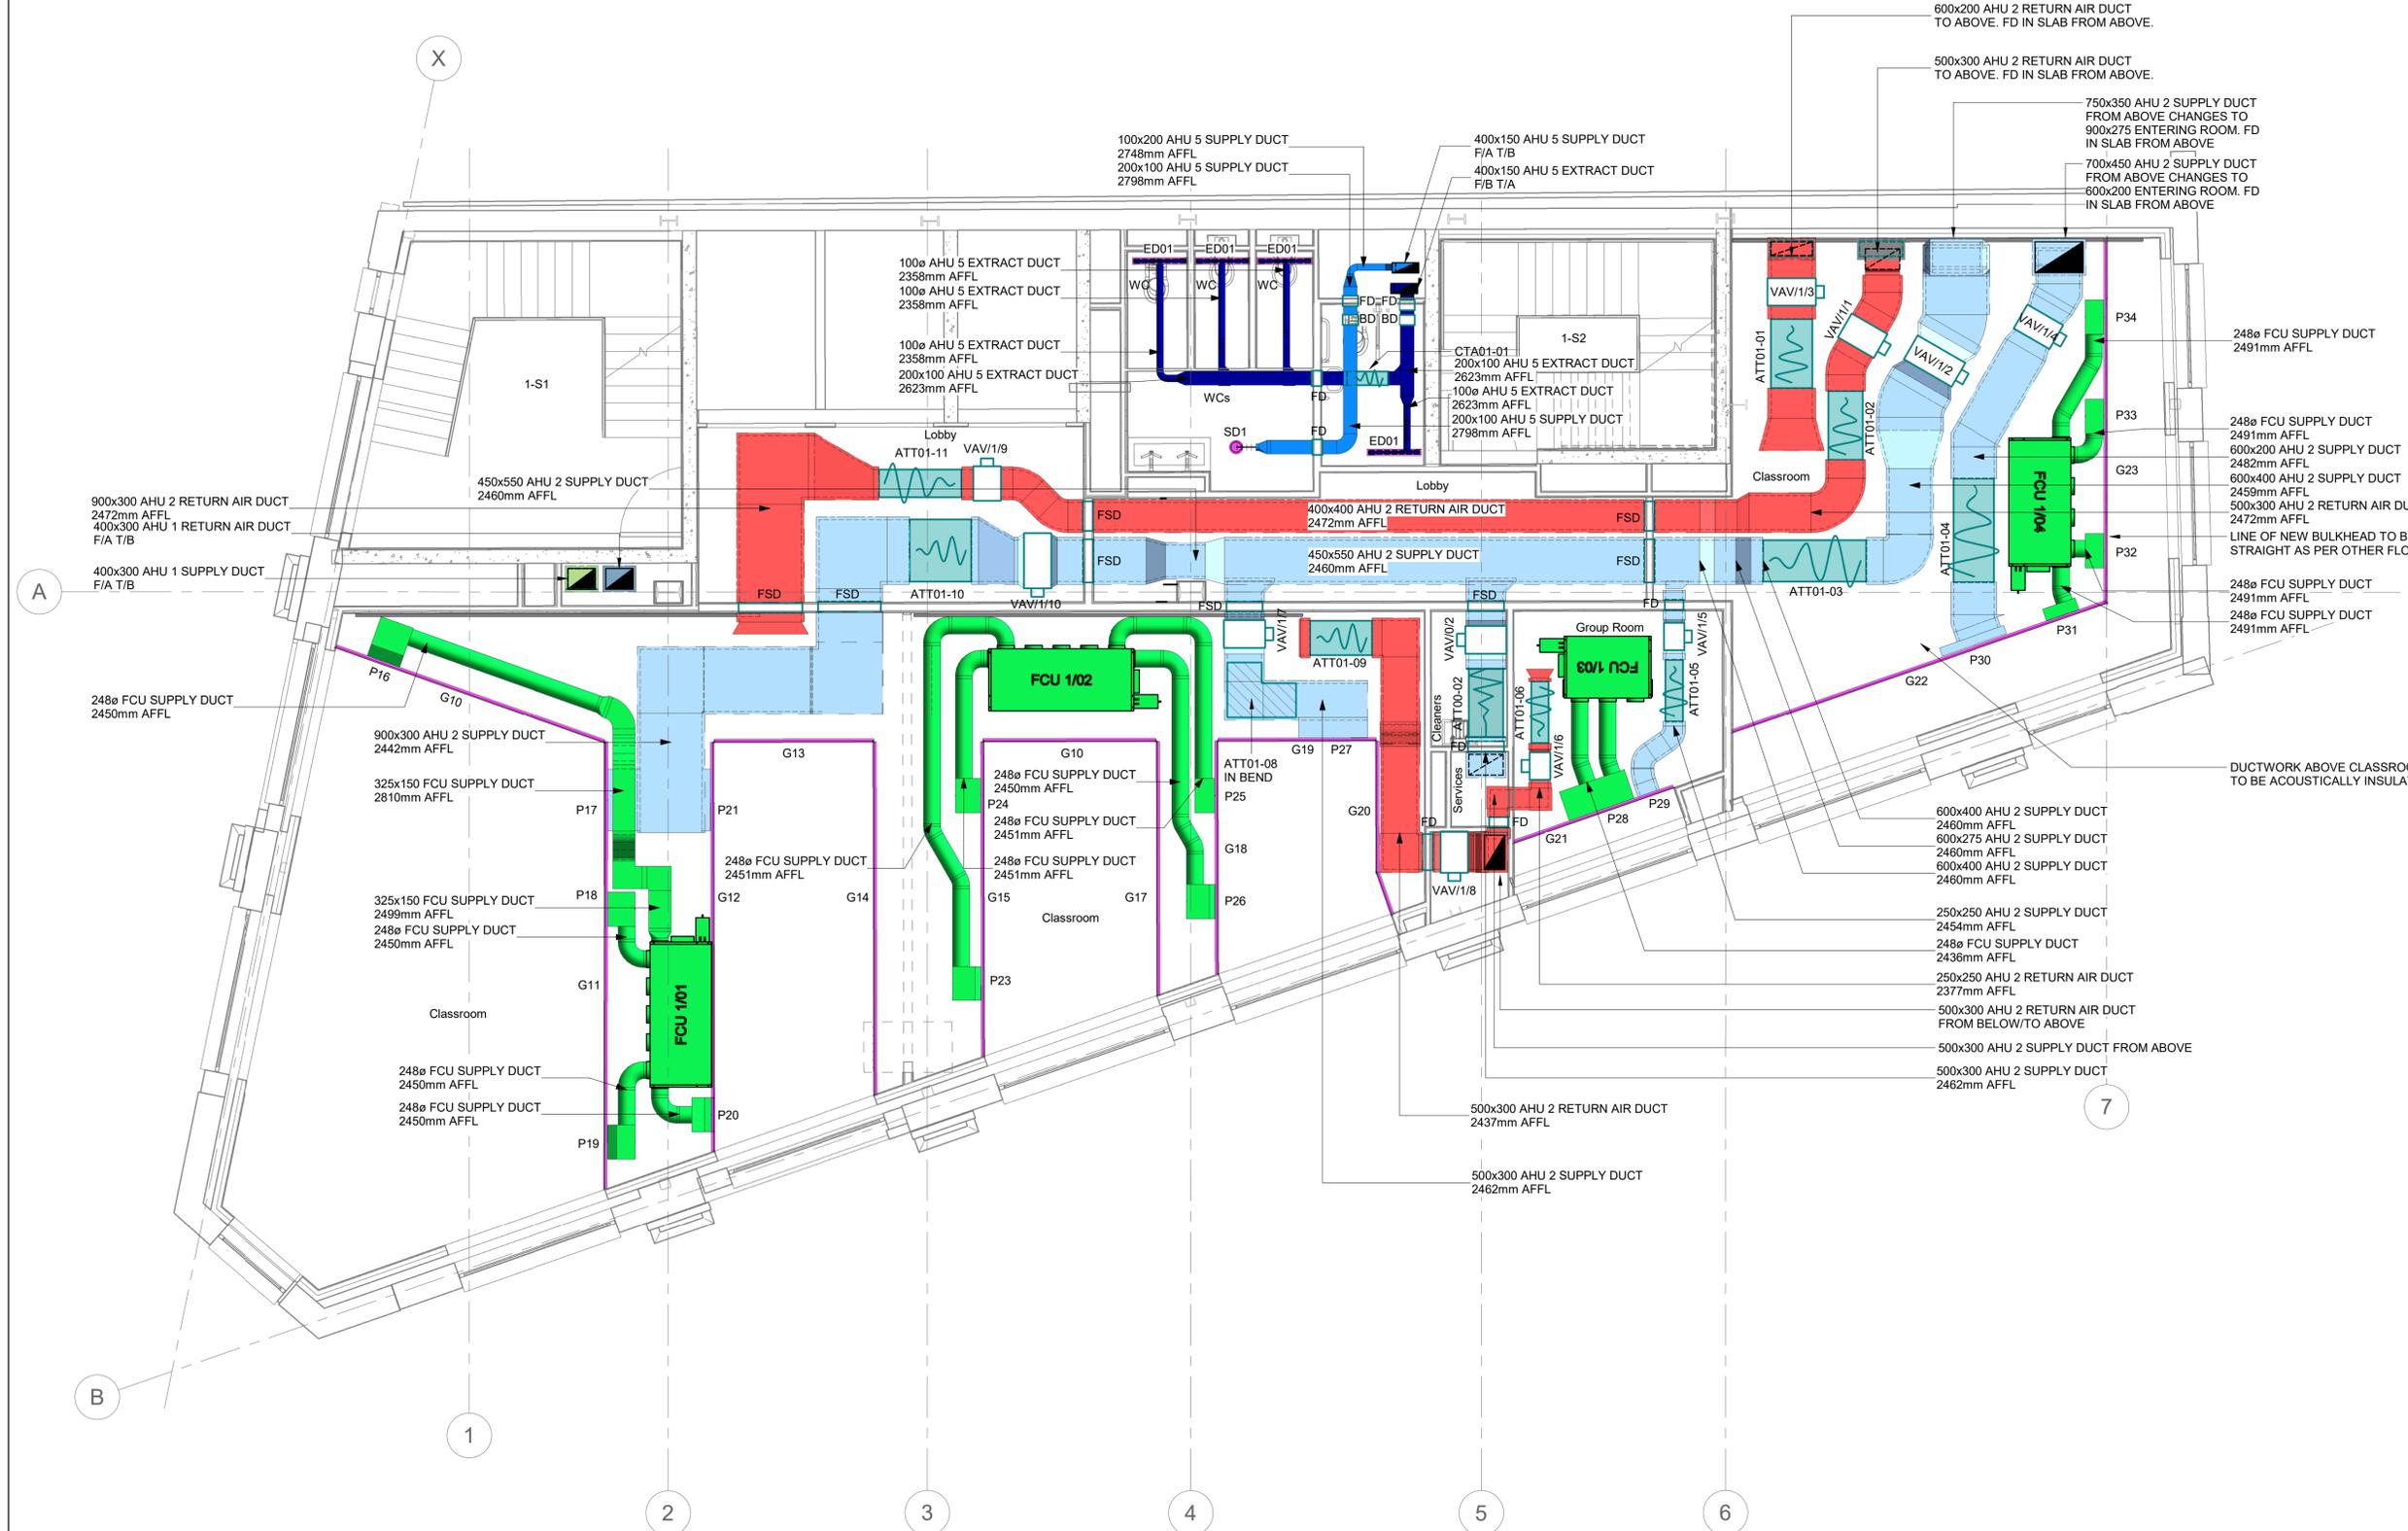



NOTES

- DO NOT SCALE FROM THIS DRAWING.
- ALL SETTING OUT TO BE AGREED WITH ARCHITECT.
- TO BE READ IN CONJUNCTION WITH ALL LAYOUTS, DETAILS, SCHEDULES AND SPECIFICATIONS.
- NOTE THAT THIS DRAWING REPRESENTS A VIEW INTO A 3D MODEL. NOT ALL COMPONENTS ARE VISIBLE IN ALL VIEWS AND ONE COMPONENT MAY BE CONCEALED BELOW ANOTHER COMPONENT. IF IN DOUBT REFER TO THE 3D MODEL AND SCHEMATIC AS WELL AS ALL ACCOMPANYING DRAWINGS.
- ALL DUCTWORK TO BE GALVALIZED STEEL SHEET METAL AND SPIRAL IN ACCORDANCE WITH DW144.
- ALL DUCTWORK ABOVE BAFFLE TYPE CEILINGS TO BE BLACK FINISH.
- VENTILATION IN WCs AND SANITARY AREAS IS TO BE CONTROLLED IN TRICKLE AND BOOST MODE BY LOCAL PIRs SHARED WITH THE LIGHTING.
- GRILLE ON ALL BULKHEADS TO HAVE CONTINUOUS FACING GRILLE AS INDICATED IN ARCHITECTS DRAWINGS, WHERE NO ACTIVE GRILLE IS SPECIFIED IN ILES CONSULTING GRILLE SCHEDULE ASSUME BULKHEAD TO BE AS EG05. GRILLES TO BE FULL LENGTH OF BULKHEAD AND TO BE CO-ORDINATED WITH INTERIORS AND SITE MEASURED.
- ALL AHU SUPPLY AND EXTRACT DUCTWORK TO BE THERMALLY INSULATED.
- THIS DRAWING DOES NOT SHOW SMOKE EXTRACT SYSTEM OR ASSOCIATED COMPONENTS.
- FIRE & FIRE SMOKE DAMPERS TO BE INSTALLED IN ACCORDANCE WITH THE FIRE STRATEGY.
- MOTORIZED VOLUME CONTROL DAMPERS TO BE INSTALLED IN ACCORDANCE WITH THE BMS CONTROLS STRATEGY.

LEGEND

- AHU 1 SUPPLY AIR
  - AHU 1 EXTRACT AIR
  - AHU 2 SUPPLY AIR
  - AHU 2 EXTRACT AIR
  - AHU 3 SUPPLY AIR
  - AHU 3 EXTRACT AIR
  - AHU 4 SUPPLY AIR
  - AHU 4 EXTRACT AIR
  - AHU 5 SUPPLY AIR
  - AHU 5 EXTRACT AIR
  - FCU SUPPLY AIR
  - EXHAUST AIR
  - FRESH AIR
  - SMOKE EXTRACT
- SD-SUPPLY VALVE  
 SG-SUPPLY GRILLE  
 EG-EXTRACT GRILLE  
 ED-EXTRACT VALVE  
 FD-FIRE DAMPER  
 FSD-FIRE AND SMOKE DAMPER  
 VAV-VAV VOLUME CONTROL DAMPER  
 BD-BALANCING DAMPER  
 CTA-CROSS TALK ATTENUATOR  
 ATT-ATTENUATOR  
 FCU-FAN COIL UNIT  
 Pxx-PLENUM REF  
 Gxx-GRILLE REF

C3	ISSUED FOR CONSTRUCTION	SRW	MI	11.02.20
C2	ISSUED FOR CONSTRUCTION	SRW	DB	31.01.20
C1	ISSUED FOR CONSTRUCTION	SRW	MI	13.01.20

Rev.	Description	Drawn	Chkd	Date
------	-------------	-------	------	------

For Construction

Architect  
**GIBBERD**  
 Client  
**ELEMENTS M&E CONTRACTING LTD**

Project  
**CAMBRIDGE HOUSE, BIRKBECK COLLEGE**


Drawing Title:  
**THIRD FLOOR VENTILATION LAYOUT**



REVIT Directory: I:\Projects\19-000\19-011\Drawings\

Drawing Size: A1 Scale: 1 : 50

Dwg No: 19-011-M-57-03-001 Rev: C3

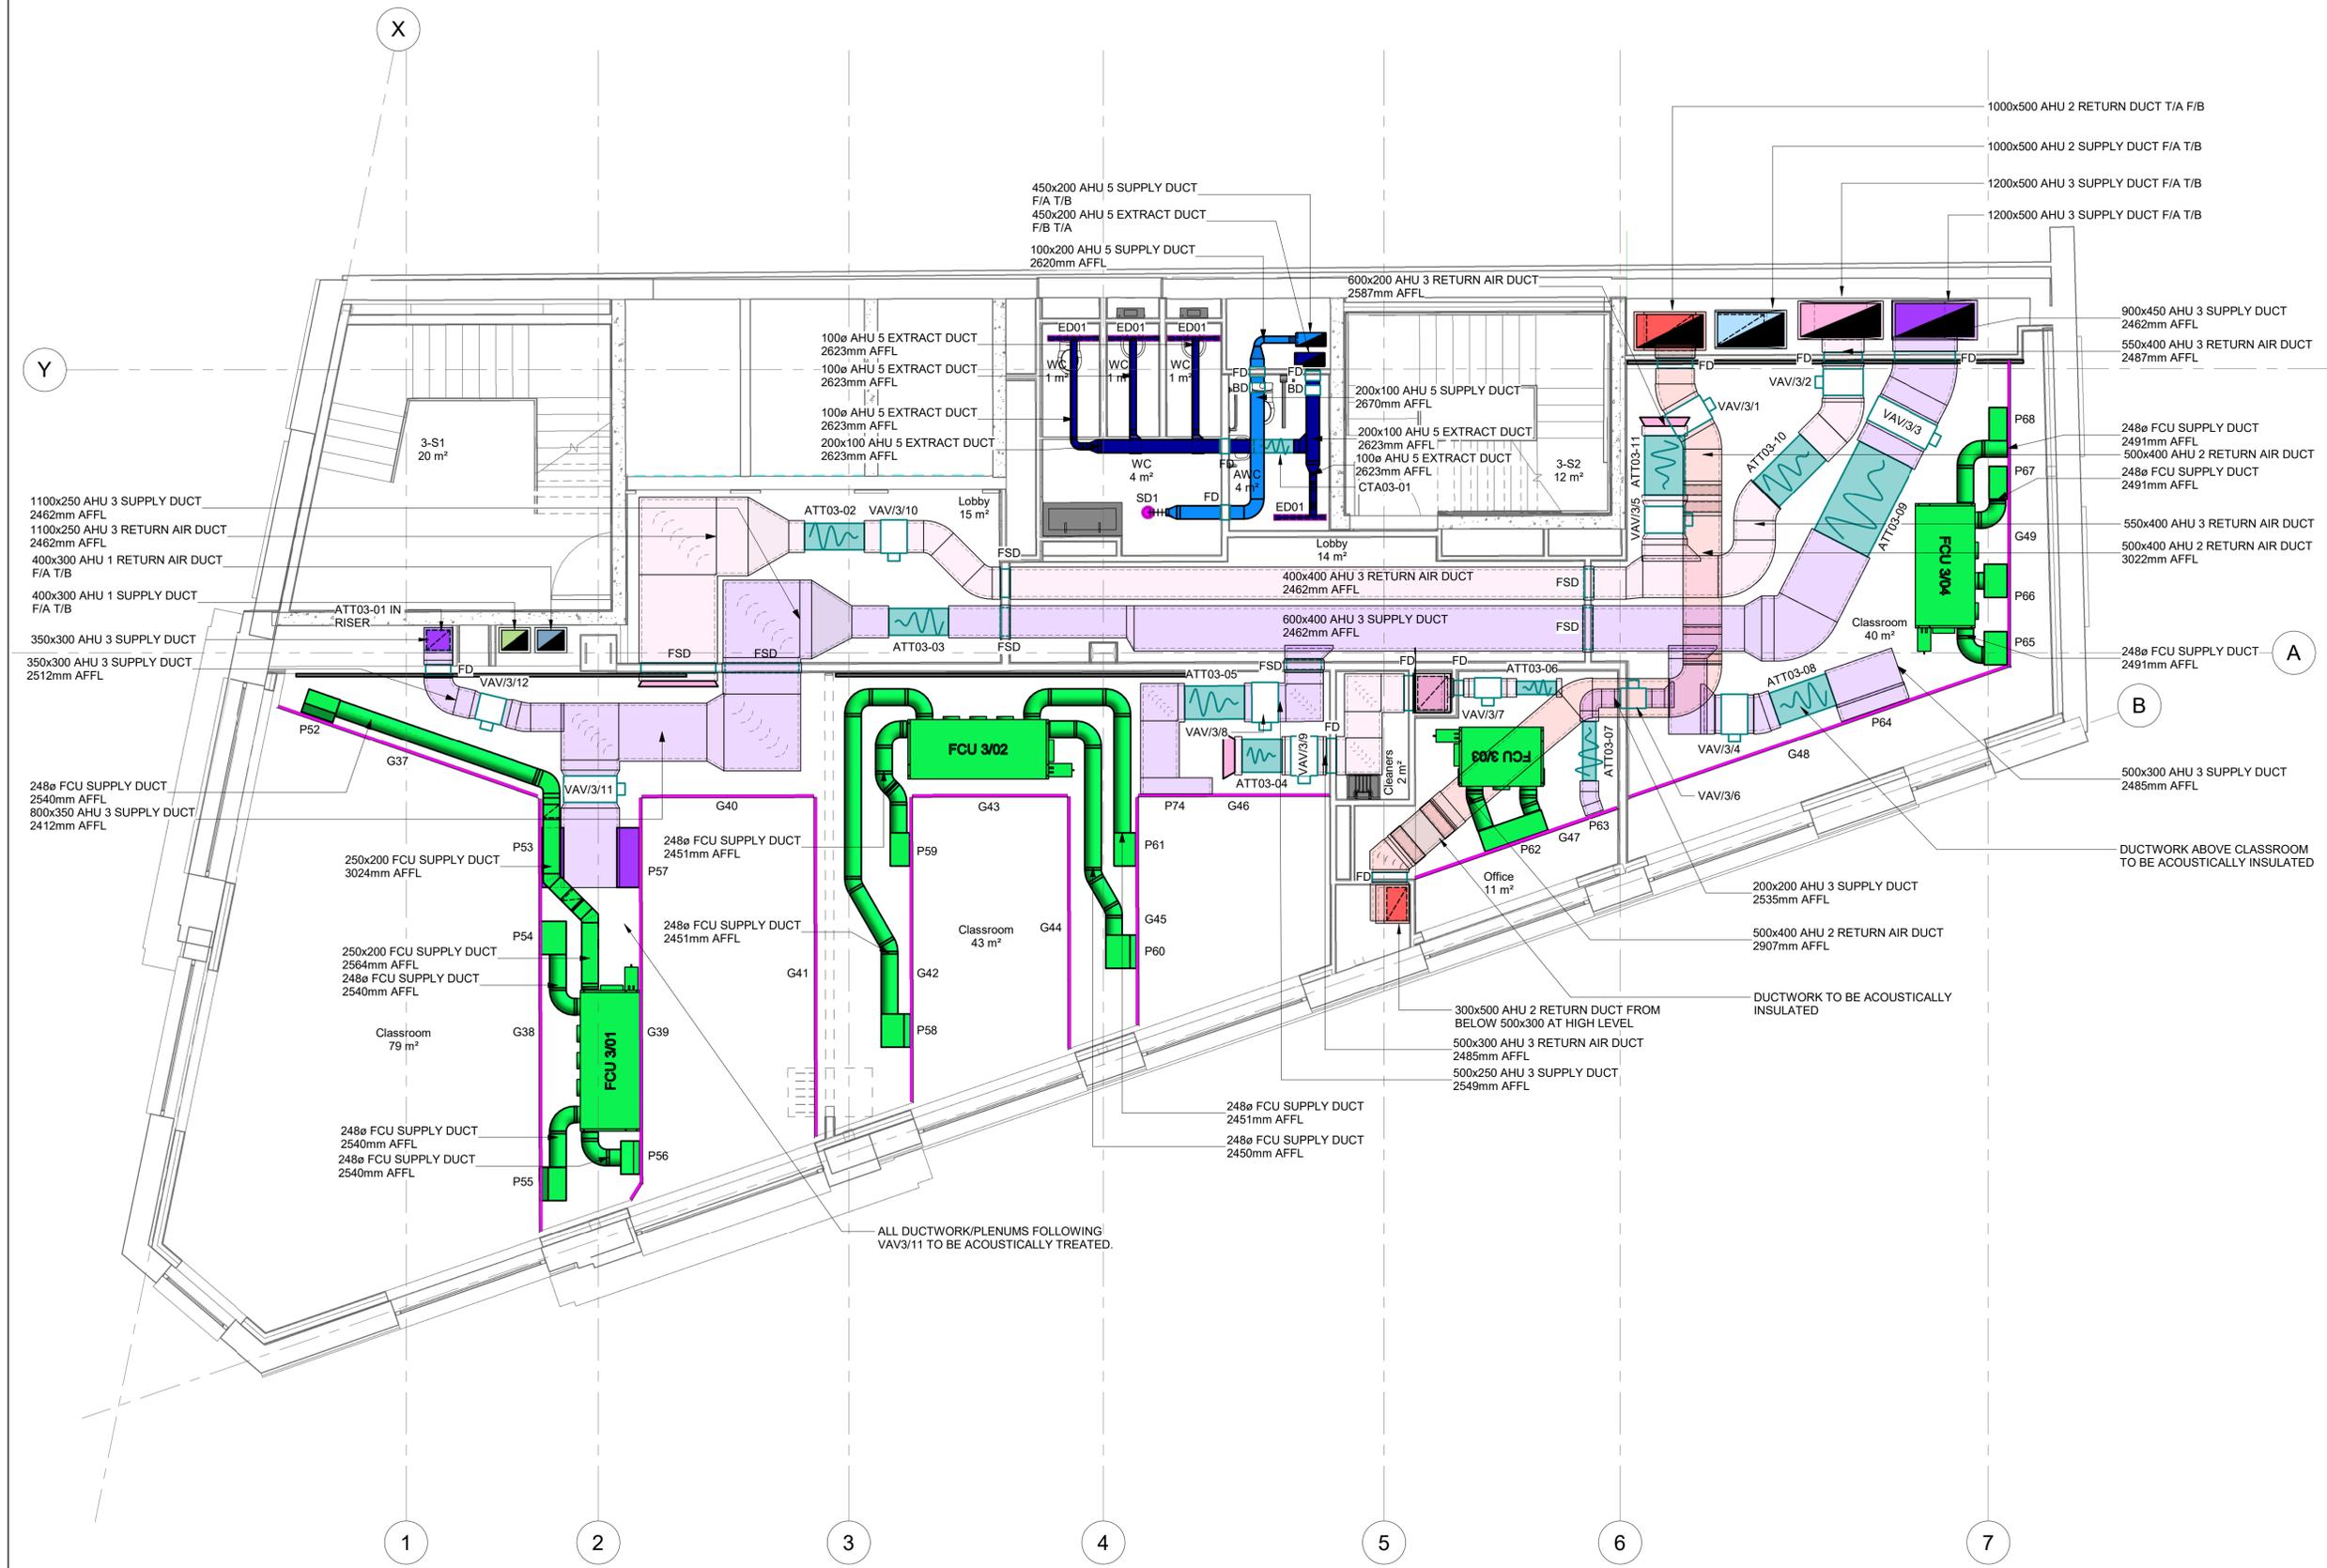

NOTES

- DO NOT SCALE FROM THIS DRAWING.
- ALL SETTING OUT TO BE AGREED WITH ARCHITECT.
- TO BE READ IN CONJUNCTION WITH ALL LAYOUTS, DETAILS, SCHEDULES AND SPECIFICATIONS.
- NOTE THAT THIS DRAWING REPRESENTS A VIEW INTO A 3D MODEL. NOT ALL COMPONENTS ARE VISIBLE IN ALL VIEWS AND ONE COMPONENT MAY BE CONCEALED BELOW ANOTHER COMPONENT. IF IN DOUBT REFER TO THE 3D MODEL AND SCHEMATIC AS WELL AS ALL ACCOMPANYING DRAWINGS.
- ALL DUCTWORK TO BE GALVANIZED STEEL SHEET METAL AND SPIRAL IN ACCORDANCE WITH DW144.
- ALL DUCTWORK ABOVE BAFFLE TYPE CEILINGS TO BE BLACK FINISH.
- VENTILATION IN WCs AND SANITARY AREAS IS TO BE CONTROLLED IN TRICKLE AND BOOST MODE BY LOCAL PIRs SHARED WITH THE LIGHTING.
- GRILLE ON ALL BULKHEADS TO HAVE CONTINUOUS FACING GRILLE AS INDICATED IN ARCHITECTS DRAWINGS, WHERE NO ACTIVE GRILLE IS SPECIFIED IN ILES CONSULTING GRILLE SCHEDULE ASSUME BULKHEAD TO BE AS EG05. GRILLES TO BE FULL LENGTH OF BULKHEAD AND TO BE CO-ORDINATED WITH INTERIORS AND SITE MEASURED.
- ALL AHU SUPPLY AND EXTRACT DUCTWORK TO BE THERMALLY INSULATED.
- THIS DRAWING DOES NOT SHOW SMOKE EXTRACT SYSTEM OR ASSOCIATED COMPONENTS.
- FIRE & FIRE SMOKE DAMPERS TO BE INSTALLED IN ACCORDANCE WITH THE FIRE STRATEGY.
- MOTORIZED VOLUME CONTROL DAMPERS TO BE INSTALLED IN ACCORDANCE WITH THE BMS CONTROLS STRATEGY.

LEGEND

- AHU 1 SUPPLY AIR
  - AHU 1 EXTRACT AIR
  - AHU 2 SUPPLY AIR
  - AHU 2 EXTRACT AIR
  - AHU 3 SUPPLY AIR
  - AHU 3 EXTRACT AIR
  - AHU 4 SUPPLY AIR
  - AHU 4 EXTRACT AIR
  - AHU 5 SUPPLY AIR
  - AHU 5 EXTRACT AIR
  - FCU SUPPLY AIR
  - EXHAUST AIR
  - FRESH AIR
  - SMOKE EXTRACT
- SD-SUPPLY VALVE  
 SG-SUPPLY GRILLE  
 EG-EXTRACT GRILLE  
 ED-EXTRACT VALVE  
 FD-FIRE DAMPER  
 FSD-FIRE AND SMOKE DAMPER  
 VAV-VAV VOLUME CONTROL DAMPER  
 BD-BALANCING DAMPER  
 CTA-CROSS TALK ATTENUATOR  
 ATT-ATTENUATOR  
 FCU-FAN COIL UNIT  
 Pxx-PLENUM REF  
 Gxx-GRILLE REF

C3	ISSUED FOR CONSTRUCTION	SRW	MI	11.02.20
C2	ISSUED FOR CONSTRUCTION	SRW	DB	31.01.20
C1	ISSUED FOR CONSTRUCTION	SRW	MI	13.01.20

Rev.	Description	Drawn	Chkd	Date
------	-------------	-------	------	------

For Construction

Architect  
**GIBBERD**  
 Client  
**ELEMENTS M&E CONTRACTING LTD**

Project  
**CAMBRIDGE HOUSE, BIRKBECK COLLEGE**


Drawing Title:  
**FOURTH FLOOR VENTILATION LAYOUT**



REVIT Directory: I:\Projects\19-000\19-011\Drawings\

Drawing Size: A1 Scale: 1 : 50

Dwg No: 19-011-M-57-04-001 Rev: C3

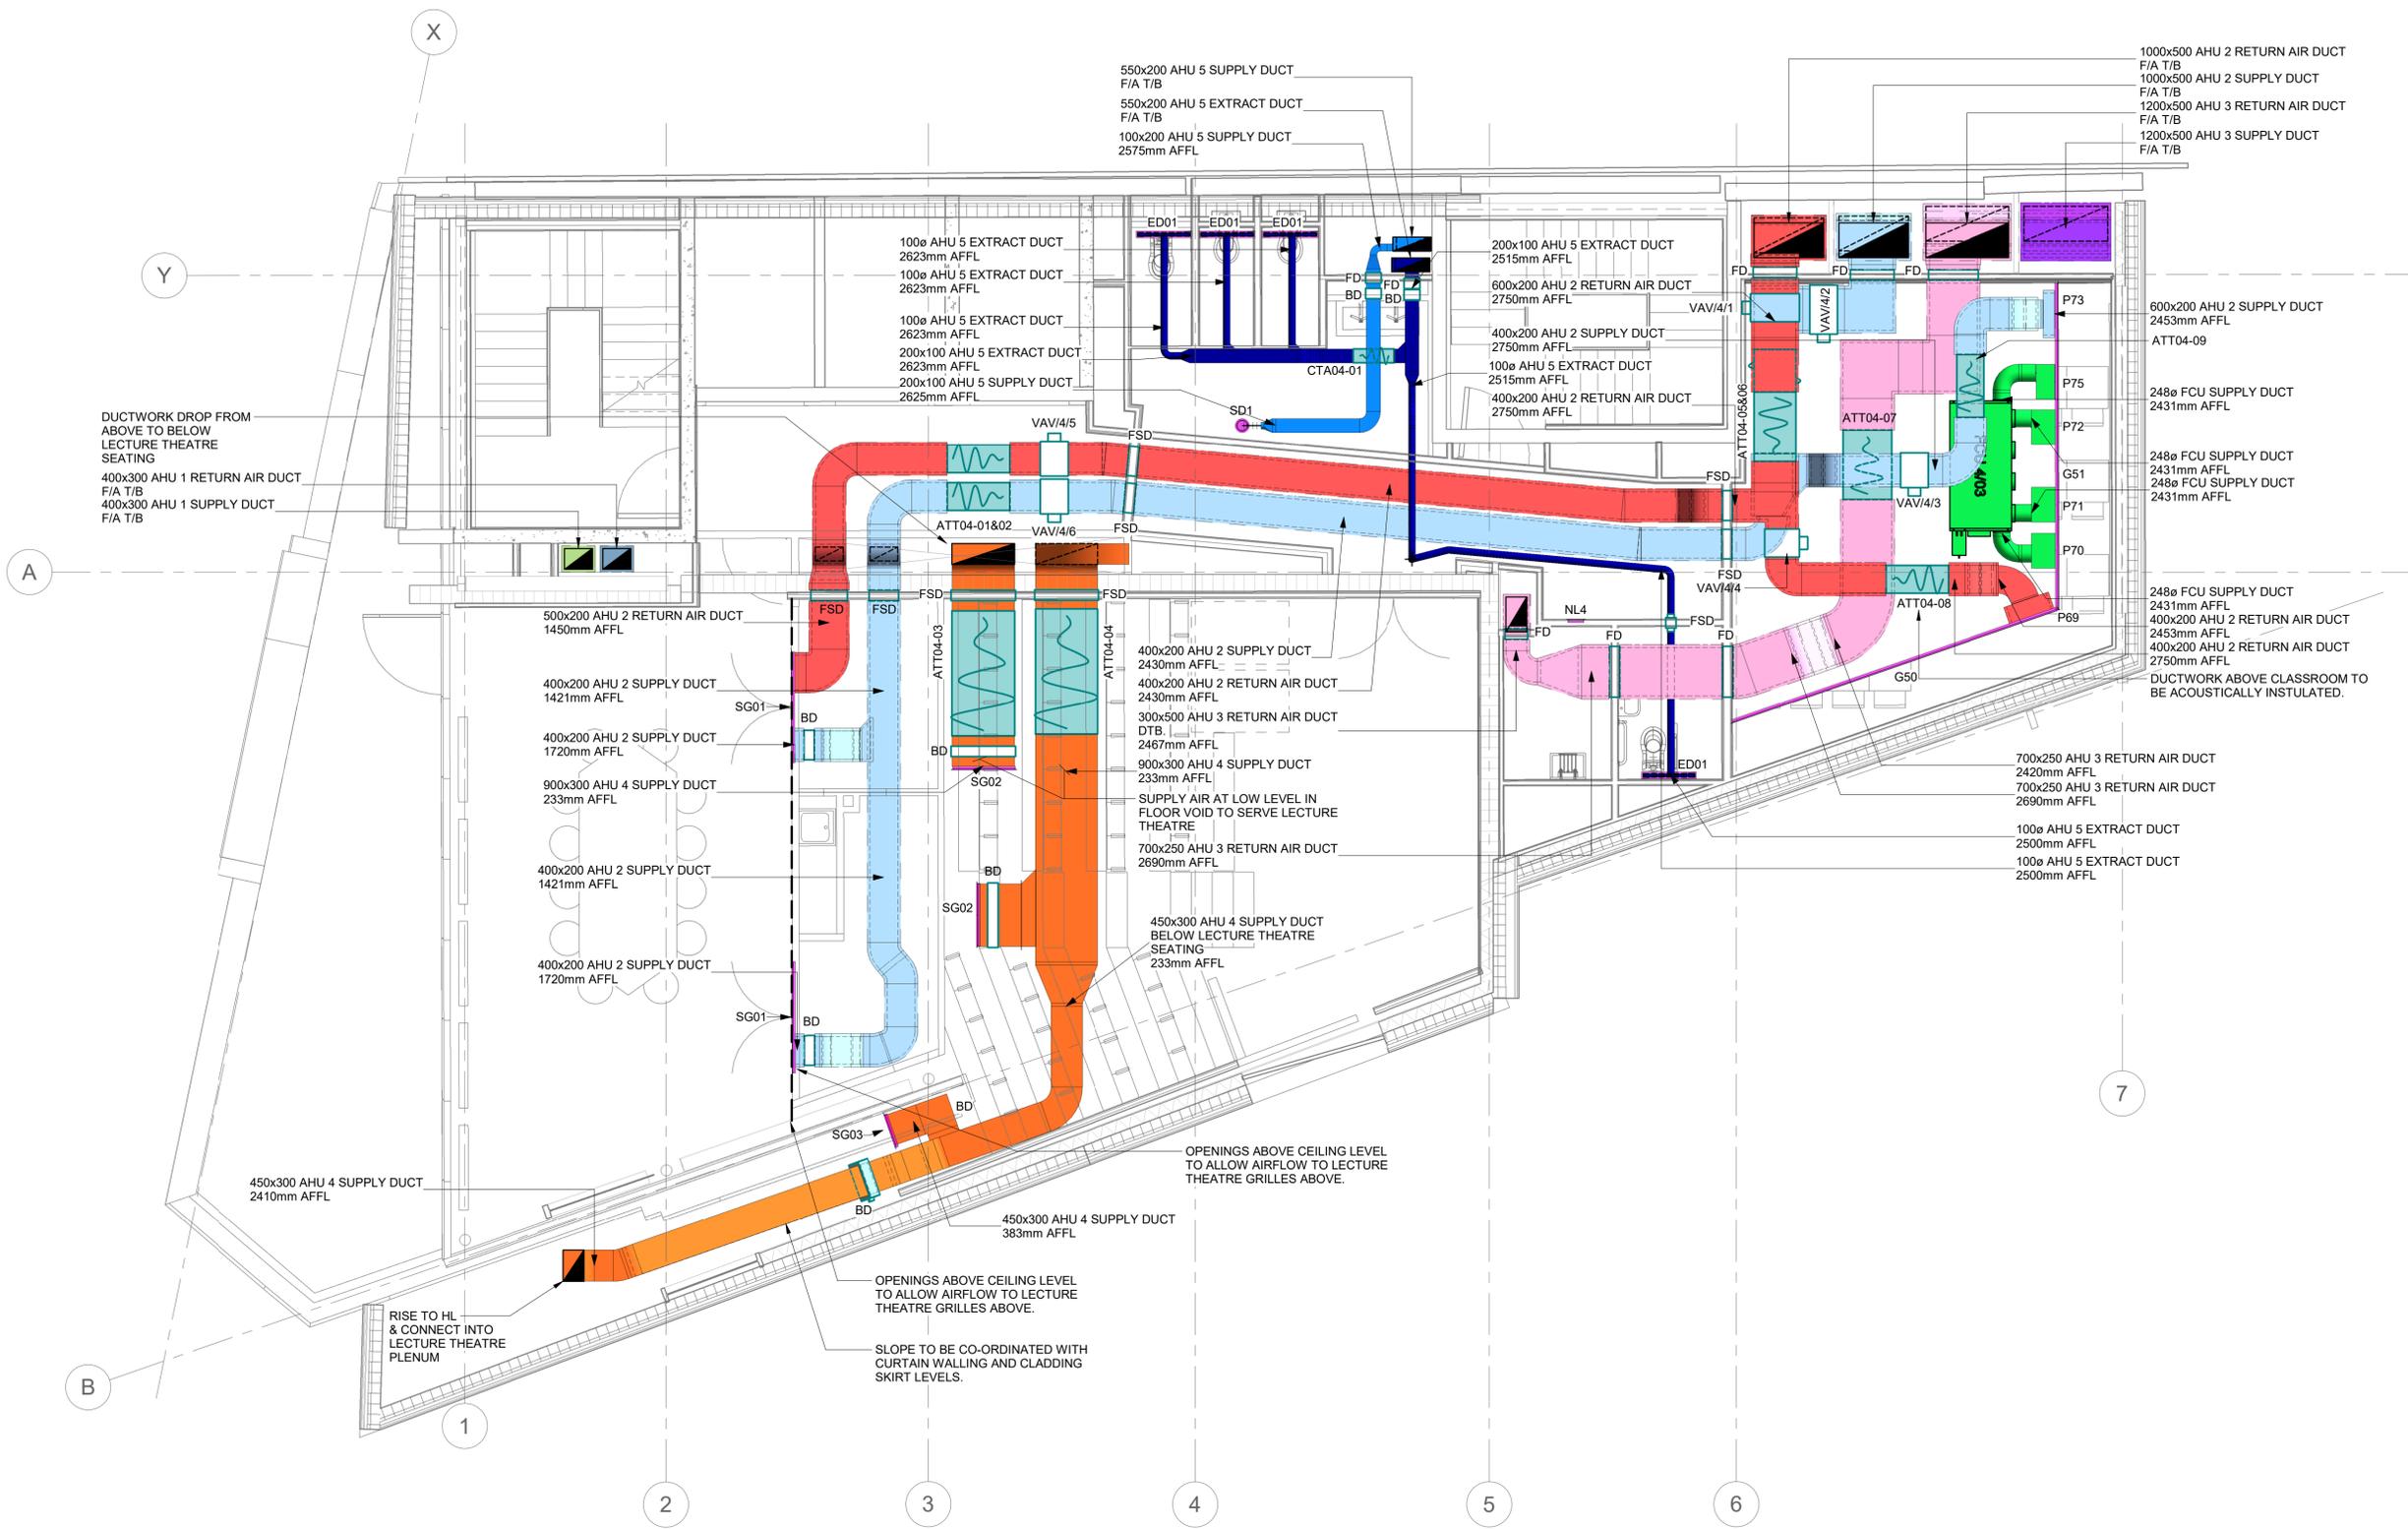

NOTES

- DO NOT SCALE FROM THIS DRAWING.
- ALL SETTING OUT TO BE AGREED WITH ARCHITECT.
- TO BE READ IN CONJUNCTION WITH ALL LAYOUTS, DETAILS, SCHEDULES AND SPECIFICATIONS.
- NOTE THAT THIS DRAWING REPRESENTS A VIEW INTO A 3D MODEL. NOT ALL COMPONENTS ARE VISIBLE IN ALL VIEWS AND ONE COMPONENT MAY BE CONCEALED BELOW ANOTHER COMPONENT. IF IN DOUBT REFER TO THE 3D MODEL AND SCHEMATIC AS WELL AS ALL ACCOMPANYING DRAWINGS.
- ALL DUCTWORK TO BE GALVANIZED STEEL SHEET METAL AND SPIRAL IN ACCORDANCE WITH DW144.
- ALL DUCTWORK ABOVE BAFFLE TYPE CEILINGS TO BE BLACK FINISH.
- VENTILATION IN WCs AND SANITARY AREAS IS TO BE CONTROLLED IN TRICKLE AND BOOST MODE BY LOCAL PIRs SHARED WITH THE LIGHTING.
- GRILLE ON ALL BULKHEADS TO HAVE CONTINUOUS FACING GRILLE AS INDICATED IN ARCHITECTS DRAWINGS, WHERE NO ACTIVE GRILLE IS SPECIFIED IN ILES CONSULTING GRILLE SCHEDULE ASSUME BULKHEAD TO BE AS EG05. GRILLES TO BE FULL LENGTH OF BULKHEAD AND TO BE CO-ORDINATED WITH INTERIORS AND SITE MEASURED.
- ALL AHU SUPPLY AND EXTRACT DUCTWORK TO BE THERMALLY INSULATED.
- THIS DRAWING DOES NOT SHOW SMOKE EXTRACT SYSTEM OR ASSOCIATED COMPONENTS.
- FIRE & FIRE SMOKE DAMPERS TO BE INSTALLED IN ACCORDANCE WITH THE FIRE STRATEGY.
- MOTORIZED VOLUME CONTROL DAMPERS TO BE INSTALLED IN ACCORDANCE WITH THE BMS CONTROLS STRATEGY.

LEGEND

- AHU 1 SUPPLY AIR
- AHU 1 EXTRACT AIR
- AHU 2 SUPPLY AIR
- AHU 2 EXTRACT AIR
- AHU 3 SUPPLY AIR
- AHU 3 EXTRACT AIR
- AHU 4 SUPPLY AIR
- AHU 4 EXTRACT AIR
- AHU 5 SUPPLY AIR
- AHU 5 EXTRACT AIR
- FCU SUPPLY AIR
- EXHAUST AIR
- FRESH AIR
- SMOKE EXTRACT

- SD-SUPPLY VALVE
- SG-SUPPLY GRILLE
- EG-EXTRACT GRILLE
- ED-EXTRACT VALVE
- FD-FIRE DAMPER
- FSD-FIRE AND SMOKE DAMPER
- VAV-VAV VOLUME CONTROL DAMPER
- BD-BALANCING DAMPER
- CTA-CROSS TALK ATTENUATOR
- ATT-ATTENUATOR
- FCU-FAN COIL UNIT
- Pxx-PLENUM REF
- Gxx-GRILLE REF

C3	ISSUED FOR CONSTRUCTION	SRW	MI	11.02.20
C2	ISSUED FOR CONSTRUCTION	SRW	DB	31.01.20
C1	ISSUED FOR CONSTRUCTION	SRW	MI	13.01.20

Rev.	Description	Drawn	Chkd	Date

For Construction

Architect  
**GIBBERD**  
Client  
**ELEMENTS M&E CONTRACTING LTD**

Project  
**CAMBRIDGE HOUSE, BIRKBECK COLLEGE**

Drawing Title:  
**FIFTH FLOOR VENTILATION LAYOUT**

**iles consulting**   
ENGINEERING EXCELLENCE  
ILES Consulting Ltd  
Metropolitan House, Longrigg Road, Swilwell, Gateshead NE16 3AS  
t: 0191 496250 f: 0191 496750 e: mail@ilesconsulting.co.uk www.ilesconsulting.co.uk

REVIT Directory: I:\Projects\19-000\19-011\Drawings\

Drawing Size: A1 Scale: As indicated

Dwg No: 19-011-M-57-05-001 Rev: C3



NOTES

- DO NOT SCALE FROM THIS DRAWING.
- ALL SETTING OUT TO BE AGREED WITH ARCHITECT.
- TO BE READ IN CONJUNCTION WITH ALL LAYOUTS, DETAILS, SCHEDULES AND SPECIFICATIONS.
- NOTE THAT THIS DRAWING REPRESENTS A VIEW INTO A 3D MODEL. NOT ALL COMPONENTS ARE VISIBLE IN ALL VIEWS AND ONE COMPONENT MAY BE CONCEALED BELOW ANOTHER COMPONENT. IF IN DOUBT REFER TO THE 3D MODEL AND SCHEMATIC AS WELL AS ALL ACCOMPANYING DRAWINGS.
- ALL DUCTWORK TO BE GALVANIZED STEEL SHEET METAL AND SPIRAL IN ACCORDANCE WITH DW144.
- ALL DUCTWORK ABOVE BAFFLE TYPE CEILING TO BE BLACK FINISH.
- VENTILATION IN WCs AND SANITARY AREAS IS TO BE CONTROLLED IN TRICKLE AND BOOST MODE BY LOCAL PIRs SHARED WITH THE LIGHTING.
- GRILLE ON ALL BULKHEADS TO HAVE CONTINUOUS FACING GRILLE AS INDICATED IN ARCHITECTS DRAWINGS, WHERE NO ACTIVE GRILLE IS SPECIFIED IN ILES CONSULTING GRILLE SCHEDULE ASSUME BULKHEAD TO BE AS EG05. GRILLES TO BE FULL LENGTH OF BULKHEAD AND TO BE CO-ORDINATED WITH INTERIORS AND SITE MEASURED.
- ALL AHU SUPPLY AND EXTRACT DUCTWORK TO BE THERMALLY INSULATED.
- THIS DRAWING DOES NOT SHOW SMOKE EXTRACT SYSTEM OR ASSOCIATED COMPONENTS.
- FIRE & FIRE SMOKE DAMPERS TO BE INSTALLED IN ACCORDANCE WITH THE FIRE STRATEGY.
- MOTORIZED VOLUME CONTROL DAMPERS TO BE INSTALLED IN ACCORDANCE WITH THE BMS CONTROLS STRATEGY.

LEGEND

- AHU 1 SUPPLY AIR
  - AHU 1 EXTRACT AIR
  - AHU 2 SUPPLY AIR
  - AHU 2 EXTRACT AIR
  - AHU 3 SUPPLY AIR
  - AHU 3 EXTRACT AIR
  - AHU 4 SUPPLY AIR
  - AHU 4 EXTRACT AIR
  - AHU 5 SUPPLY AIR
  - AHU 5 EXTRACT AIR
  - FCU SUPPLY AIR
  - EXHAUST AIR
  - FRESH AIR
  - SMOKE EXTRACT
- SD-SUPPLY VALVE  
 SC-SUPPLY GRILLE  
 EG-EXTRACT GRILLE  
 ED-EXTRACT VALVE  
 FD-FIRE DAMPER  
 FSD-FIRE AND SMOKE DAMPER  
 VAV-VAV VOLUME CONTROL DAMPER  
 BD-BALANCING DAMPER  
 CTA-CROSS TALK ATTENUATOR  
 ATT-ATTENUATOR  
 FCU-FAN COIL UNIT  
 Pxx-PLENUM REF  
 Gxx-GRILLE REF

C3	ISSUED FOR CONSTRUCTION	SRW	MI	11.02.20
C2	ISSUED FOR CONSTRUCTION	SRW	DB	31.01.20
C1	ISSUED FOR CONSTRUCTION	SRW	MI	13.01.20

Rev.	Description	Drawn	Chkd	Date

For Construction

Architect  
**GIBBERD**  
 Client  
**ELEMENTS M&E CONTRACTING LTD**

Project  
**CAMBRIDGE HOUSE, BIRKBECK COLLEGE**

Drawing Title:  
**FIFTH MEZZANINE FLOOR VENTILATION LAYOUT**

**iles consulting** IC  
 ENGINEERING EXCELLENCE  
 ILES Consulting Ltd  
 Metropolitan House, Longgong Road, Swatwell, Gateshead NE16 3AS  
 t: 0191 496250 f: 0191 496750 e: mail@ilesconsulting.co.uk www.ilesconsulting.co.uk

REVIT Directory: I:\Projects\19-000\19-011\Drawings\

Drawing Size: A1 Scale: As indicated

Dwg No: 19-011-M-57-05M-001 Rev: C3

