

Project Client:

## Argent

## 

- Michael Grubb Studio Ltd Bryanstone Road, Bournemouth, BH3 7JE t: +44 (0)1202 511 005 e: info@michaelgrubbstudio.com www.michaelgrubbstudio.com
- Drawing information:
   Notes:

   1.
   Do not scale from this drawing.
   1.

   2.
   This drawing should be read in conjunction with the current set of luminaire specification sheets and Schedules.
   1.

   3.
   Exact luminaire locations will be confirmed prior to the commencement of works on site.
   1.


   4.
   Luminaire lengths and dimensions should not be taken from this plan. Dimensions are for Michael Grubb Studio estimated pricing purposes only. It is the Contractor's responsibility to ensure the correct lengths are measured on site prior to ordering.

   5.
   The 'C?.?' number located within each reference represents the 'control circuit' only. This may not be the same as the actual wiring
- circuit. 6. If in doubt, ASK!

Notes:

1. Final lighting details to be agreed with Architect, Client and Contractor.

Revisions:	Кеу:	
01 - Revisions inline with Loggia Lighting Containment and Fabrication.	XG - Soffit recessed Downlight Luminaire.	

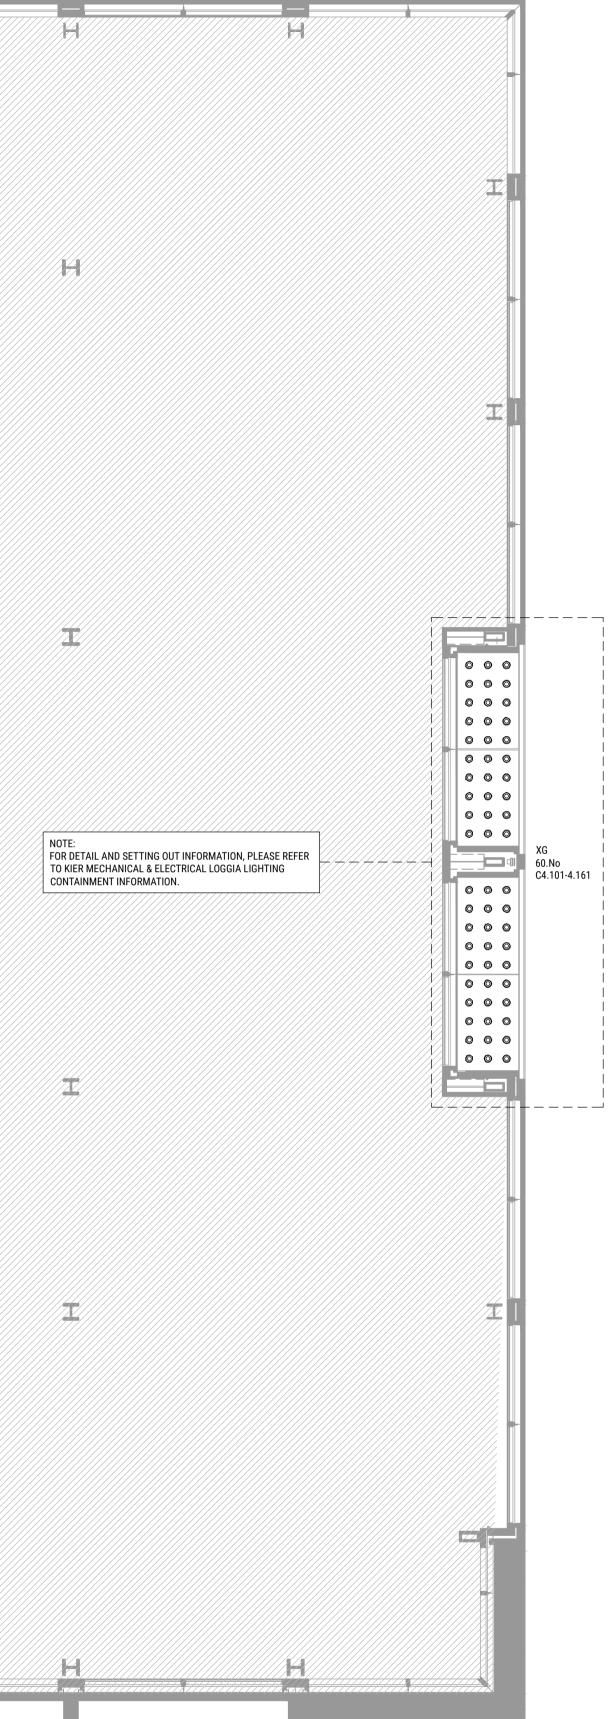

Project:		
Building	P2 Exterior Lighting, London,	UK
Drawing: Third Flo High Lev	oor vel Lighting Layout Plan	
Purpose of drawing:		Scale:
Stage 4		1:50 on A1 1:100 on A3
Drawn:	Checked:	Date:
SH	MW	17th April 2020
Drawing re	eference:	Rev:
KXC-P2-001-J-P0944-63-103		01