

PROJECT TITLE: 6 PRINCE ALBERT ROAD REGENTS PARK NW1	PROJECT CODE: 761		REV:	BY: DATE:	DESCRIPTION:	NOTES:
			A	KR 01.10.21	ISSUED FOR TENDER	1. ALL INFORMATION ISSUED IS NON-BINDING AND/OR SUBJECT TO CONTRACT. ALL DESIGNS, PROPOSAL
	DRAWN BY: KR	CHECKED BY: KR	В	KR 29.10.21	ISSUED FOR TENDER	DOCUMENTATION ARE INDICATIVE ONLY, THEY HAVE BEEN DEVELOPED IN ISOLATION AND REMAIN SUBJEC CONSULTANTS ON THE PROJECT AND APPROVAL BY THE CLIENT REPRESENTATIVE
	ISSUED FOR: TENDER					2. DO NOT SCALE OFF THIS DRAWING. USE FIGURED DIMENSIONS ONLY. ALL DIMENSIONS AND LEVELS TO BE ANY DISCREPANCIES. 3. DRAWINGS TO BE READ IN CONJUNCTION WITH FULL SET OF DRAWINGS, SCHEDULES, SPECIFICATION AND
DRAWING TITLE: THIRD FLOOR RCP AS PROPOSED	SCALE: 1:20 @ A0	DATE: 01.10.2021				4. CONTRACTOR TO CHECK ALL DIMENSIONS ON SITE PRIOR TO THE PRODUCTION OF ANY SHOP DRAWINGS, I 5. DRAWINGS ISSUED ONLY FOR THE PURPOSE INDICATED.
	DRAWING NO: 761_300_305	REVISION: B				6. ALL WORK TO COMPLY WITH CURRENT BUILDING REGULATIONS AND HEALTH AND SAFETY REGULATIONS. 7. THE DIMENSIONS SHOWN ON THIS DRAWING HAVE BEEN BASED ON MEASUREMENTS PROVIDED BY AN INDE

THIRD FLOOR RCP 1:20 @ A0

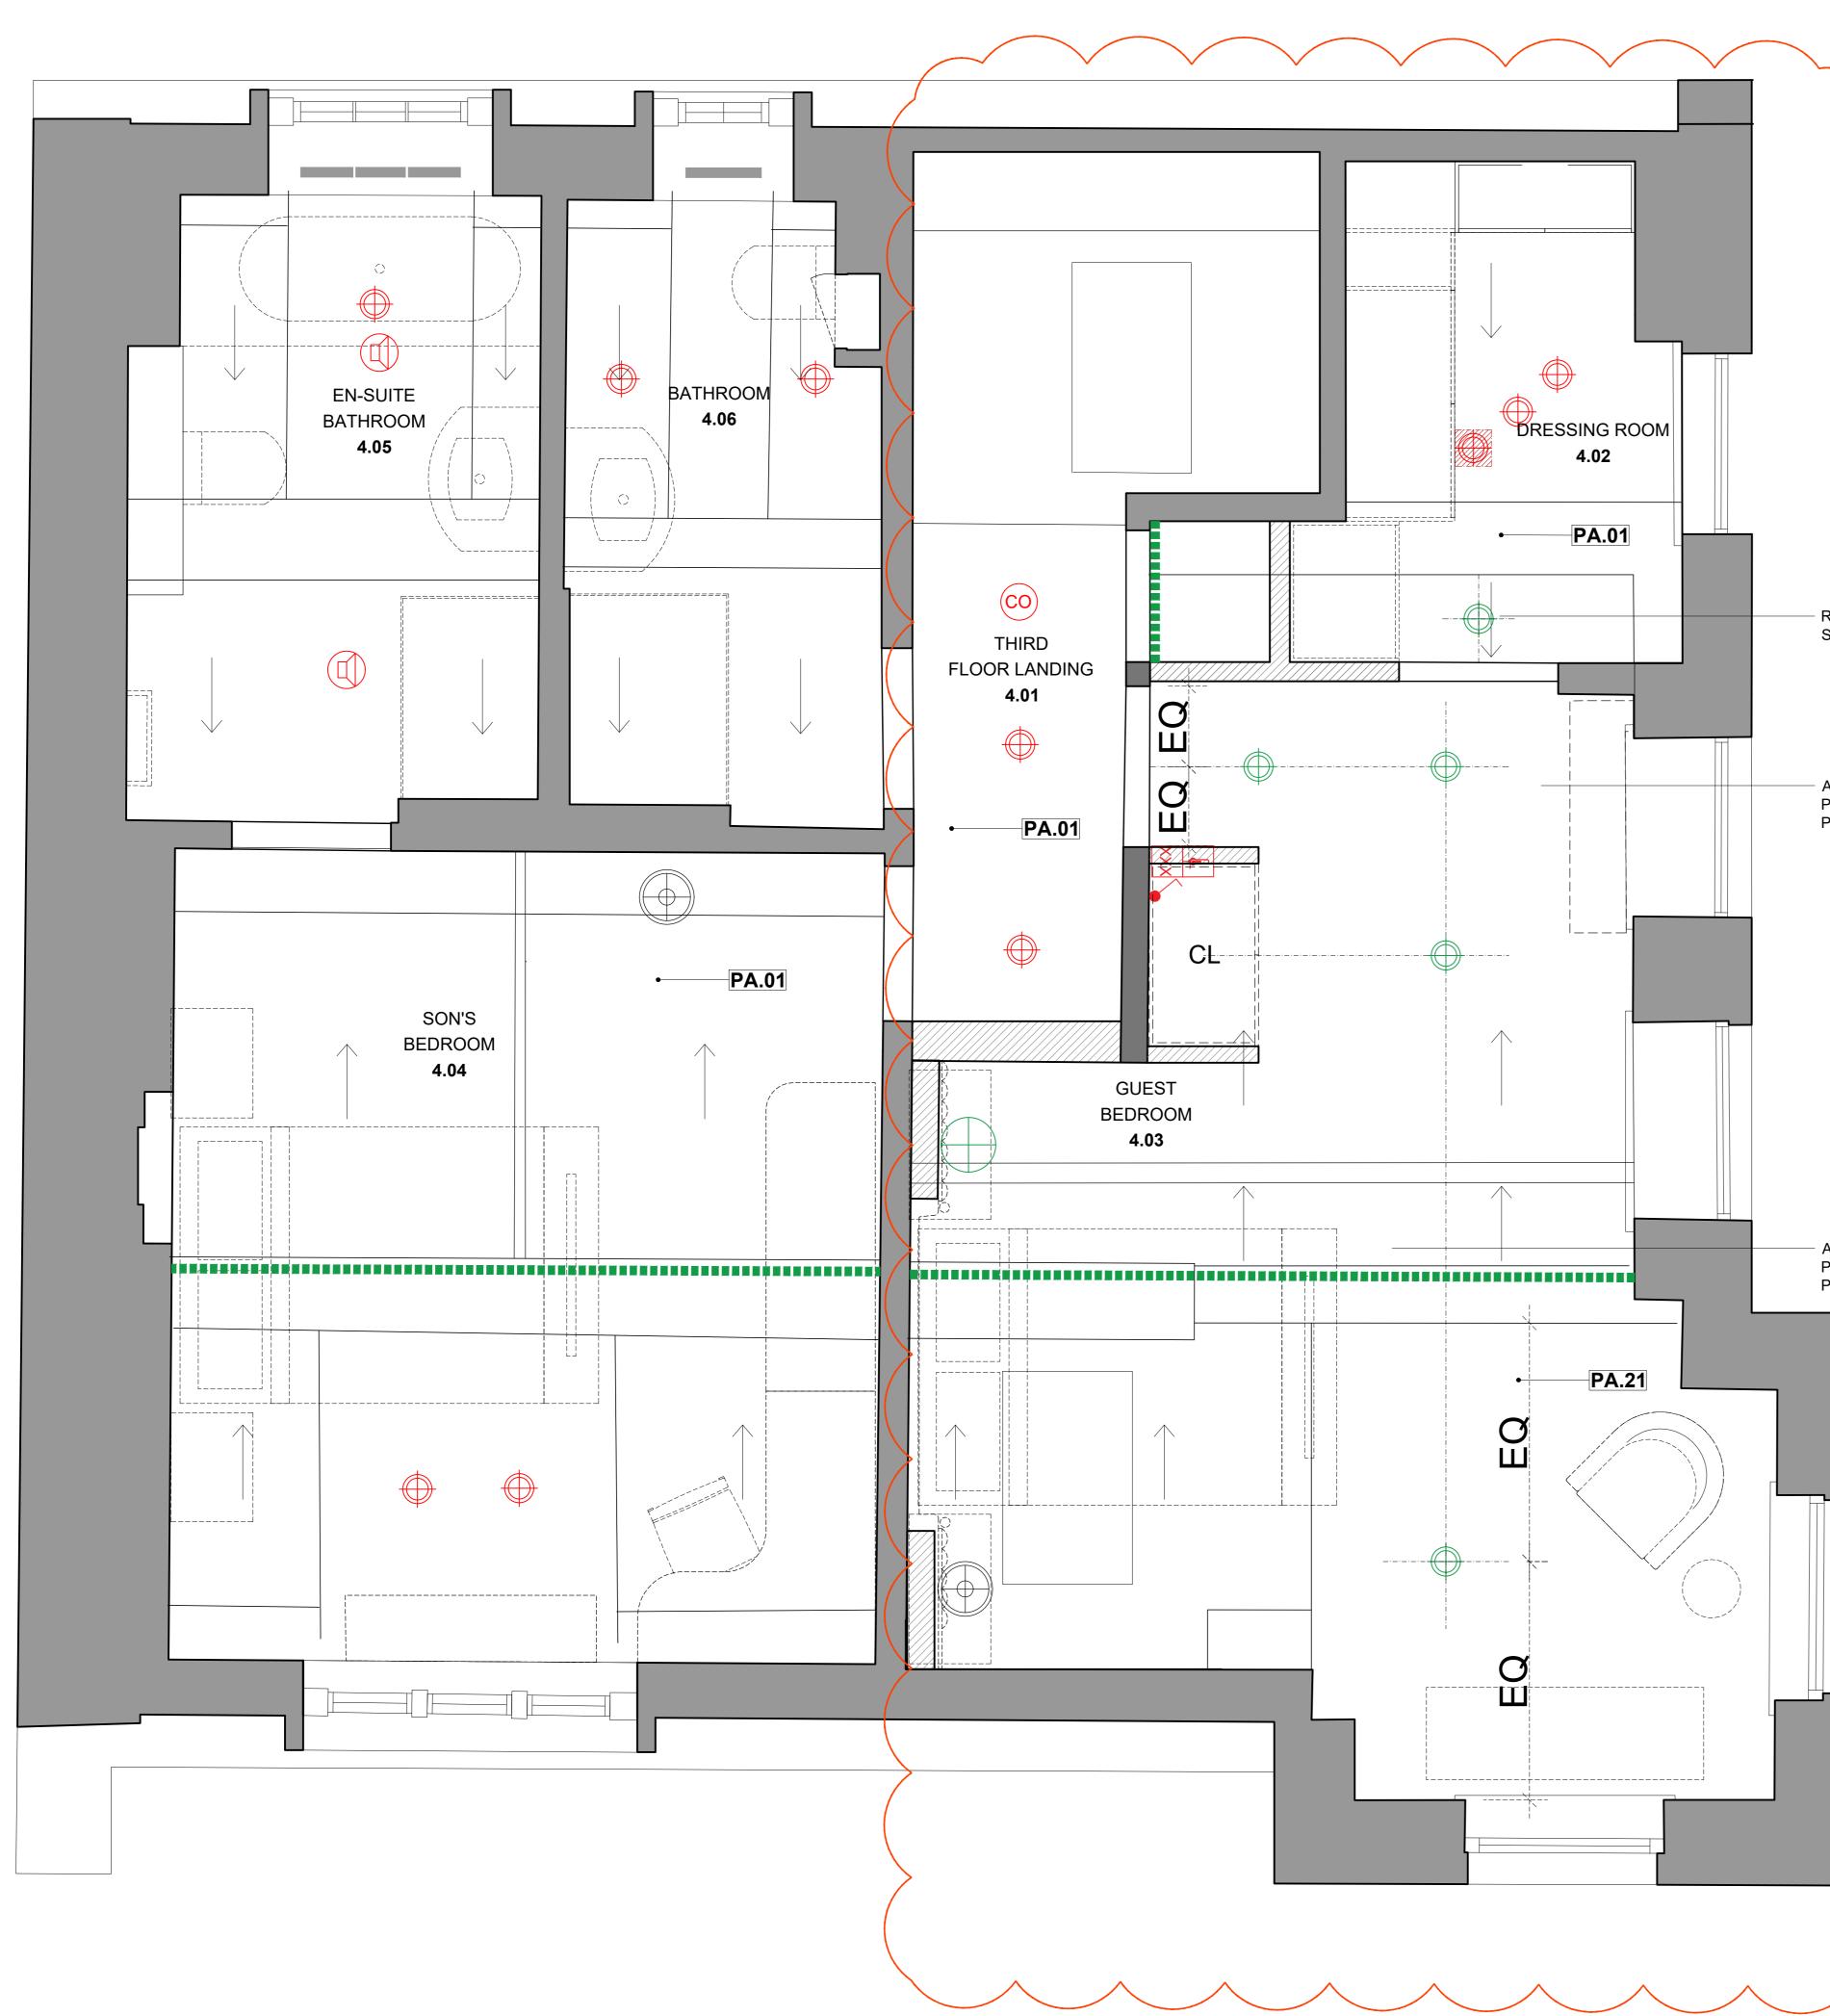

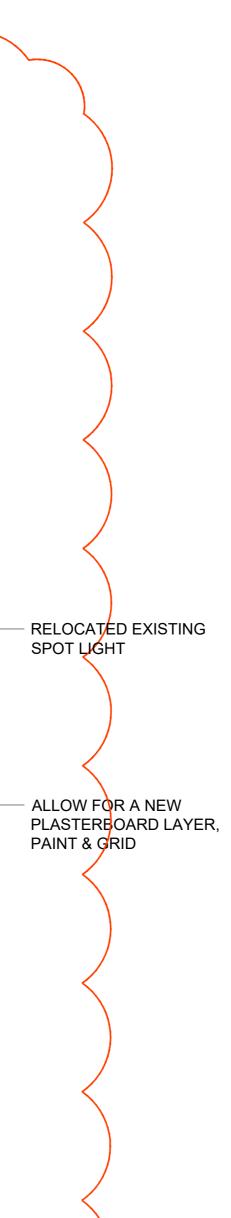

ALLOW FOR A NEW PLASTERBOARD LAYER, PAINT & GRID

LEGEND

	WINDOW TREATMENT		EL
M	CURTAINS		
	AV SYSTEM	✓✓	LIGHT CONTRO
	AV STSTEM		DOUBLE SWITC
Ø	FLUSHMOUNTED SPEAKER IN CEILING	Å	SINGLE SWITCH
	MOTION SENSOR DETECTOR		SWITCHED FUS
		À	FLOOR BOX
	LIGHTING		CONTINENTAL
•	FIXED SINGLE DOWNLIGHT	~~	TRIPLE SOCKE
\Delta \	DIRECTIONAL SINGLE DOWNLIGHT	IA	INTRUDER ALA
$\mathbf{\Phi}\mathbf{\Phi}\mathbf{\Phi}$	N3 RECESSED LED LIGHT		THERMOSTAT
\oplus	PENDANT		INTERCOM SYS
P	PICTURE LIGHT	\$ \$TV\$\$	WET ROOM TV
<u></u>	READING LIGHT	TV	TV POINT
\otimes	TABLE LIGHT	S :	OUTLET FOR TE
ያ	WALL LIGHT	Π	UNKNOWN OUT
	HIGH LEVEL LED STRIP	u	
	EXISTING LIGHT FIXTURES		FIF
出 一	RECESSED LOW LEVEL WALL LIGHT	0	CO ALARM
	PROPOSED & RELOCATED LIGHTING, AV & SECURITY FIXTURES		
	EXISTING LIGHTING & SECURITY FIXTU	JRES	
	RELOCATED/ OMITTED LIGHTING & SE	CURITY FI	XTURES

GENERAL NOTES:

- 1. ALL LIGHTS TO BE DIMMABLE AND WARM WHITE IN COLOUR AND TO BE APPROVED BY ELICYON PRIOR TO PURCHASE.
- 2. TO BE READ IN CONJUNCTION WITH '761_900_510_DECORATIVE LIGHTING SCHEDULE' BY ELICYON.
- 3. TO BE READ IN CONJUNCTION WITH '761_900_100_FINISHES SCHEDULE'
- 4. TO BE READ IN CONJUNCTION WITH '761_300_400_SMALL POWER & LOW LEVEL LIGHTING PLAN' BY ELICYON.
- 5. LIGHTING LUX LEVELS TO BE CHECKED AND CONFIRMED BY LIGHTING SPECIALIST/ELECTRICAL ENGINEER.
- 6. AV DESIGN TO CONTRACTOR SPECIFICATION AND DETAILS.
- 7. FURTHER INFORMATION ON JOINERY BUILT IN LED LIGHTING TO BE EXTRACTED FROM PERTINENT ROOM LAYOUT.
- 8. REFLECTIVE CEILING AND AV PLANS TAKE PRECEDENCE OVER PERTINENT ROOM LAYOUT DRAWINGS
- 9. INTERNAL HEIGHTS TO BE CONFIRMED ON SITE.

AL OR RECOMMENDATIONS SET OUT IN THE SUBJECT TO CHANGE DEPENDING ON INPUT FROM OTHER

TO BE CHECKED ONSITE AND ELICYON TO BE NOTIFIED ON

N AND INFORMATION FROM OTHER CONSULTANTS. VINGS, FABRICATION AND COMMENCEMENT ONSITE.

IONS. AN INDEPENDENT SURVEY COMPANY.

DISCLAIMER:

In accordance with our duties under the Misrepresentation Act 1967 and the Mis-description Act 1991, these details have been prepared in good faith but are not intended to constitute part of an offer of contract or create any contractual relationship. No description or information of any kind provided by Elicyon or its Agents, whether written or verbal, contained in these Particulars or elsewhere ("Information") may be relied upon as a statement of representation, warranty or fact. Neither Elicyon nor its Agents have any authority to make any representation or warranty and accordingly any Information is given entirely without responsibility on the part of Elicyon, its Agents or the seller. Any plans, photos, and computer generated images shown are indicative and cannot be guaranteed to represent the complete interiors/exteriors of a scheme. Any Areas, measurements or distances given are approximate only. Any products and materials shown or indicated are indicative only and may be subject to variations or change. It is not possible to scale from these drawings. Any reference to alterations to or use of any part of the property is not a statement that any necessary planning, building regulations or other consent has been obtained. These matters must be verified by any buyer/lessee. Any buyer/lessee must satisfy himself by inspection or otherwise as to the correctness of any Information given. © All rights reserved to Elicyon London.

ALL DIMENSIONS TO BE CONFIRMED ON SITE

ELECTRICAL

CONTROL

SWITCHED 5AMP SOCKET OUTLET E SWITCHED SOCKET OUTLET E SWITCHED 5AMP SOCKET OUTLET

HED FUSED CONNECTION UNIT

RBOX NENTAL SOCKET

E SOCKET

DER ALARM KEYPAD

*I*OSTAT

COM SYSTEM OOM TV POINT

NIT

T FOR TELEPHONE AND DATA

OWN OUTLET/EXISTING FACE PLATE

FIRE SYSTEM

Elicyon Limited First Floor, Avon House, Avonmore Road, Kensington Village London W14 8TS

Tel: +44 (0)203 772 0011

Web: www.elicyon.com E-mail: studio@elicyon.com