
 


- Key:
-  Hanging Lantern
 -  Ground Lantern
 -  Wall Mounted Lighting

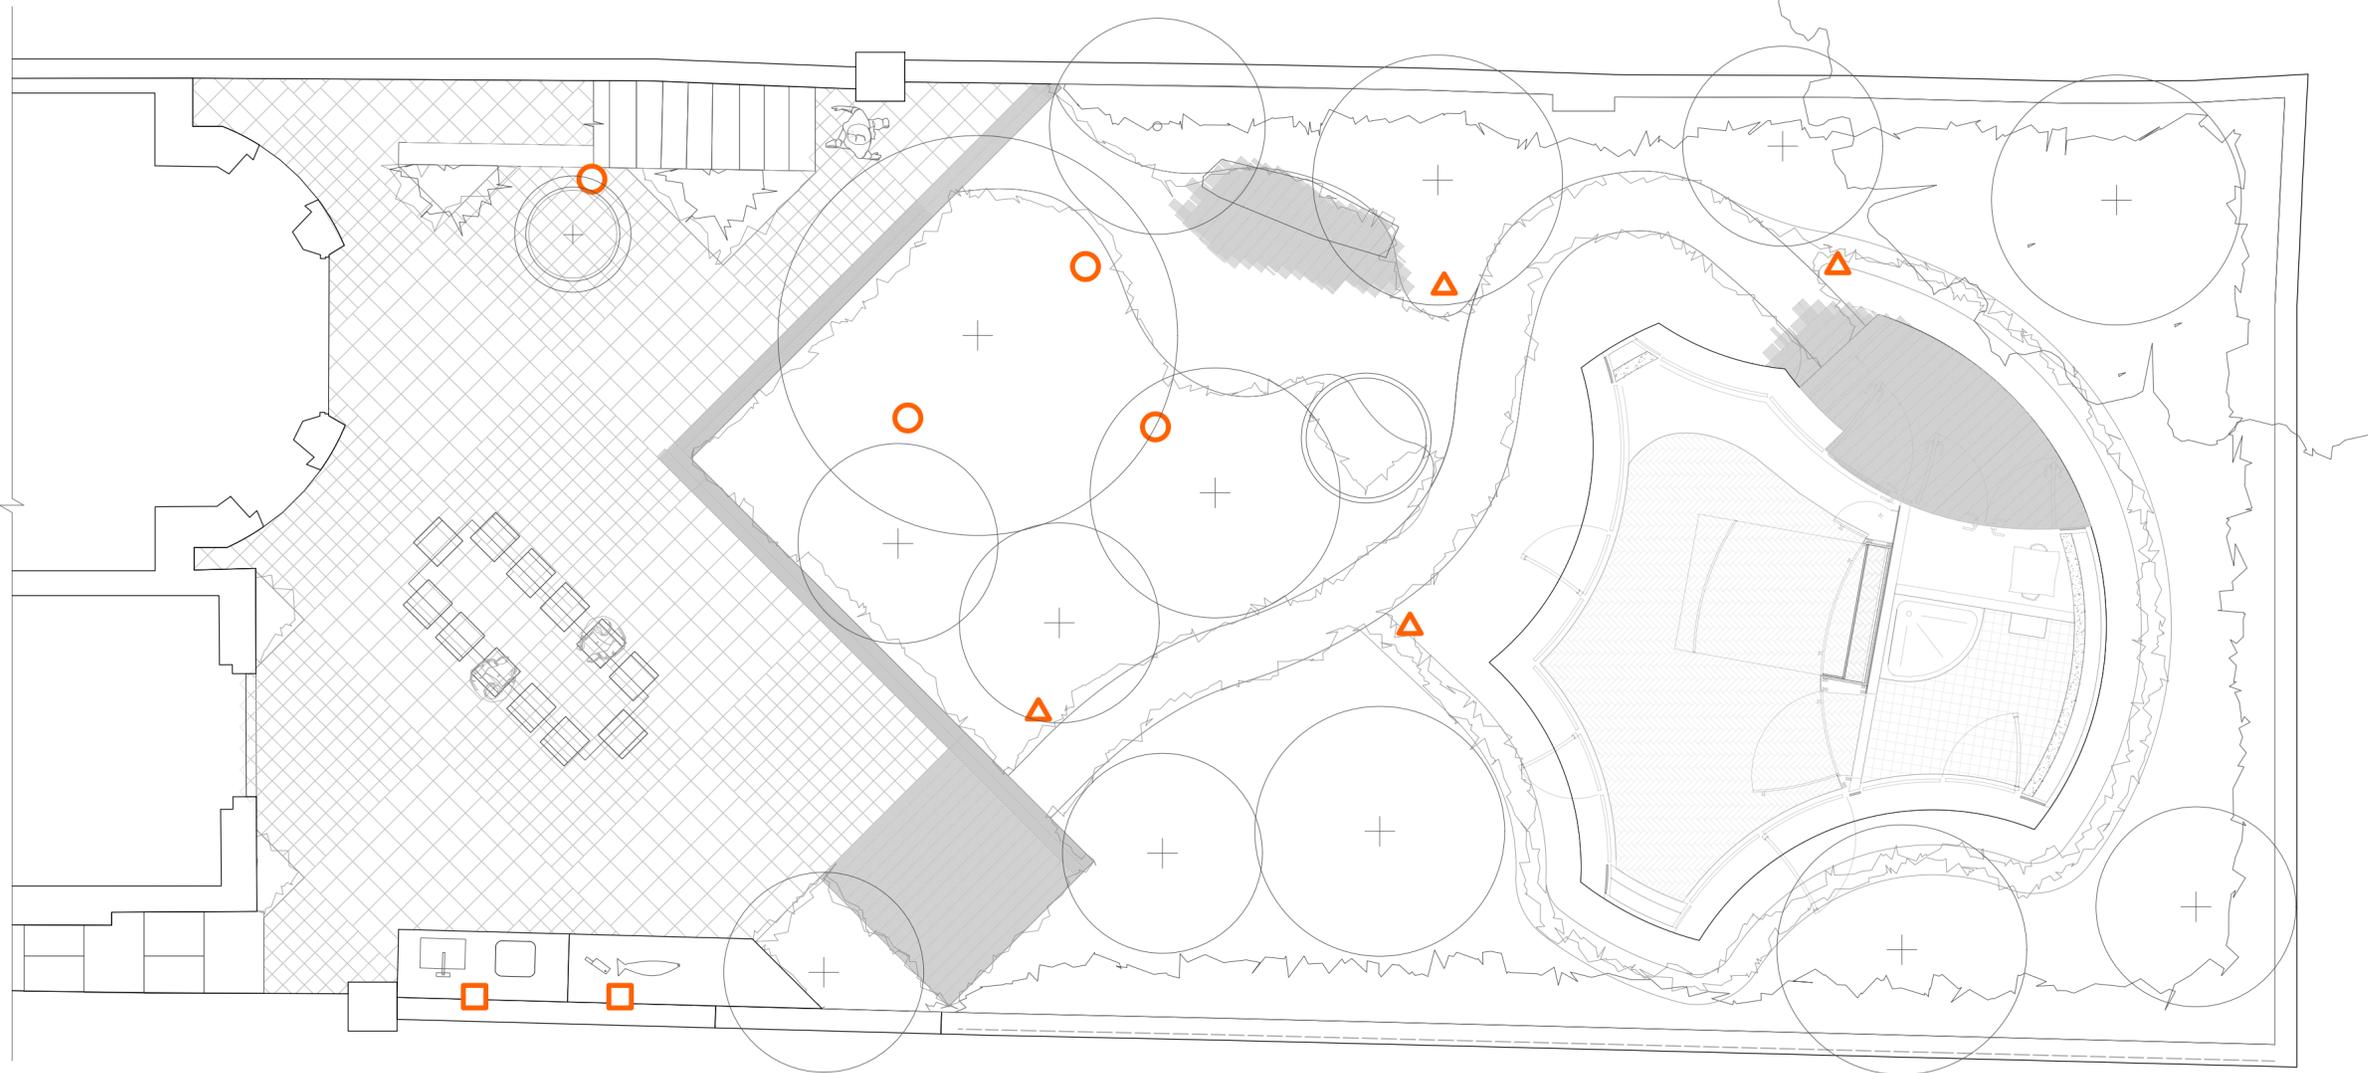

1 Rear Garden Lighting Plan
502 1:50 at A2



| | | | |
|----------------|-------|---------------------------|-----|
| Rev: | Date: | Description: | By: |
| Drawing Title: | | Rear Garden Lighting Plan | |
| Project: | | 19 Belsize Square | |
| Client: | | | |

Scale: 1:50 @ A2
Date: 14/10/2021
Drawn By: SG
Checked By: SL

Drawing Number:
BSQ-LD-502

Revision
Status
For Planning