
FOR APPROVAL/COMMENT ONLY - DO NOT CONSTRUCT FROM THIS DRAWING

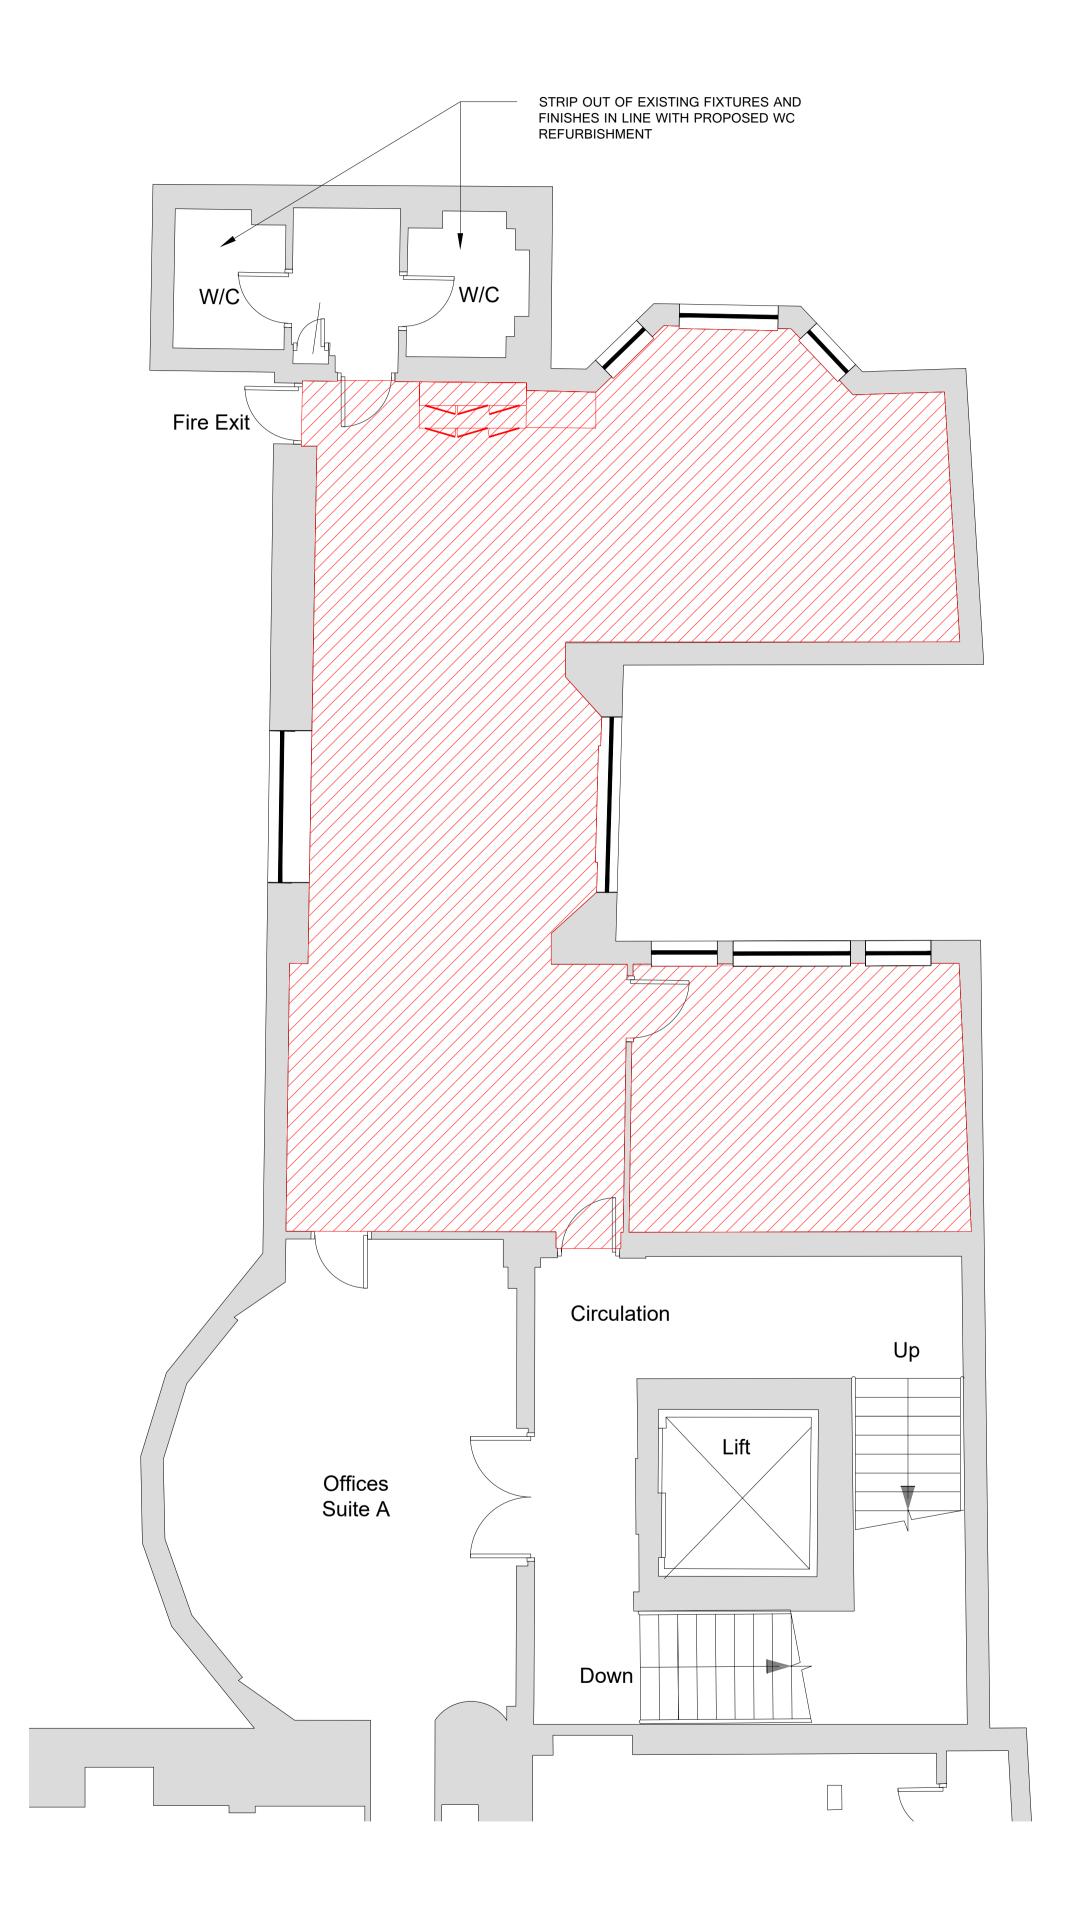



ITEMS TO BE REMOVED

FLOOR FINISH TO BE REMOVED

REMOVED.
ALL WALLS, FLOORS AND CEILINGS TO BE
MADE GOOD FOLLOWING DEMOLITIONS

ALL ITEMS SHOWN RED ARE TO BE

ANY SERVICES REMOVAL TO BE DISCUSSED ON SITE

DO NOT REMOVE (WITHOUT PRIOR

- APPROVAL)
 FIRE ALARM SYSTEM
 SECURITY ALARM SYSTEM
- SECURITY ALARM SYSTEM
 MECHANICAL SYSTEM
- MECHANICAL SYSTEM
 ACCESS CONTROL SYSTEM
 LIGHTING

(Dthree),

HELLO@DTHREESTUDIO.CO.UK DTHREESTUDIO.CO.UK 020 7096 9520

NOTES

DTHREE STUDIO DO NOT ACCEPT LIABILITY FOR ANY ERRORS AND OMISSIONS ARISING FROM THE PREPARATION OF BASE BUILD DRAWINGS WHICH ARE DERIVED FROM ORIGINAL MATERIAL PROVIDED BY OTHERS.

ALL DISCREPANCIES ARE TO BE REPORTED TO DTHREE STUDIO.
GRID LINES ARE FOR REFERENCE PURPOSES ONLY.
ALL DIMENSIONS TO BE VERIFIED BY CONTRACTOR ON SITE PRIOR TO ANY WORKS COMMENCING.
DO NOT SCALE FROM THIS DRAWING.
THIS DOCUMENT IS THE PROPERTY OF

THIS DOCUMENT IS THE PROPERTY OF DTHREE STUDIO.
COPYRIGHT IS RESERVED BY THEM, AND THE DRAWING IS ISSUED ON THE CONDITION THAT IT IS NOT COPIED, REPRODUCED OR RETAINED BY, NOR DISCLOSED TO ANY UNAUTHORISED PERSON, EITHER WHOLLY OR IN PART, WITHOUT THE CONSENT IN WRITING FROM DTHREE STUDIO.

© DTHREE STUDIO



STATUS

Approval / Comment

Building Control

Contract
Construction

As-Built

REVISION DETAIL

REV DETAIL

BY DATE

P1 FIRST DRAWING ISSUE JF 05.11.21

CLIENT

HARBO

PROJECT ADDRESS

HOLBORN TOWN HALL 193 - 197 HIGH HOLBORN LONDON WC1V 7BD

DRAWING TITLE

FOURTH FLOOR
DEMOLITION PLAN

FOR APPROVAL

 DWG NO:
 35048-04-DEMO

 REVISION:
 P1

SCALE @A1: 1:50 @ A3: 1:100

DATE: 01.11.21

DRAWN BY: JF

CHECKED BY: HM

C:\Users\james\Box\01. CURRENT PROJECTS\35048-HABRO-HOLBORN TOWN HALL\03. DESIGN\03 - WORKING DRAWINGS\35048.dwg

