## <u>NOTES</u>


 This drawing is for engineering services only and is to be read in conjunction with all relevant architectural, structural, mTT drawings

and the Contract specification.

2. THIS IS NOT AN INSTALLATION DRAWING.

 All services routes and equipment locations are indicative, actual location and configuration to be determined by contractor following completion of contractor design and coordination. 4. This drawing will only be issued in PDF format. (A)- \_\_\_\_ - \_ \_\_\_ - \_\_\_\_ - \_\_\_\_ - \_\_\_\_ -**C** ---- ---Typical TP&N isolator for – condenser units fed from tenant distribution boards 32A TP&N Isolator for -AHU-PH-06-01 DB:04:LL/12L123 32A TP&N Isolator for — AHU-PH-06-02 DB:04:LL/13L123 (F)— (G)— \_\_\_\_\_ \_ \_\_\_\_ 

Gray's Inn Road		r House			
Panther		Se .			
Copyright by mTT. No copy(ies) of this drawing, however produced and/or transmitted may be made or undertaken, without the express permission of mTT. This drawing should not be scaled. All dimensions to be checked on site any discrepancies to be notified to mTT.					
Based on architectural model: 14093-AHMM-ZZ-ZZ-M3-A-0001 Date: 2021-09-22 Based on structural model: PAH-EOC-XX-ZZ-M3-S-1000 Date: 2021-09-20	T2	16.06.2022	Stage 4 Issue addendum.	MC	LC
	TI	15.10.2021	Stage 4 Issue.	Ι	LC
	Rev.	Date	Description	Drawn	Checked

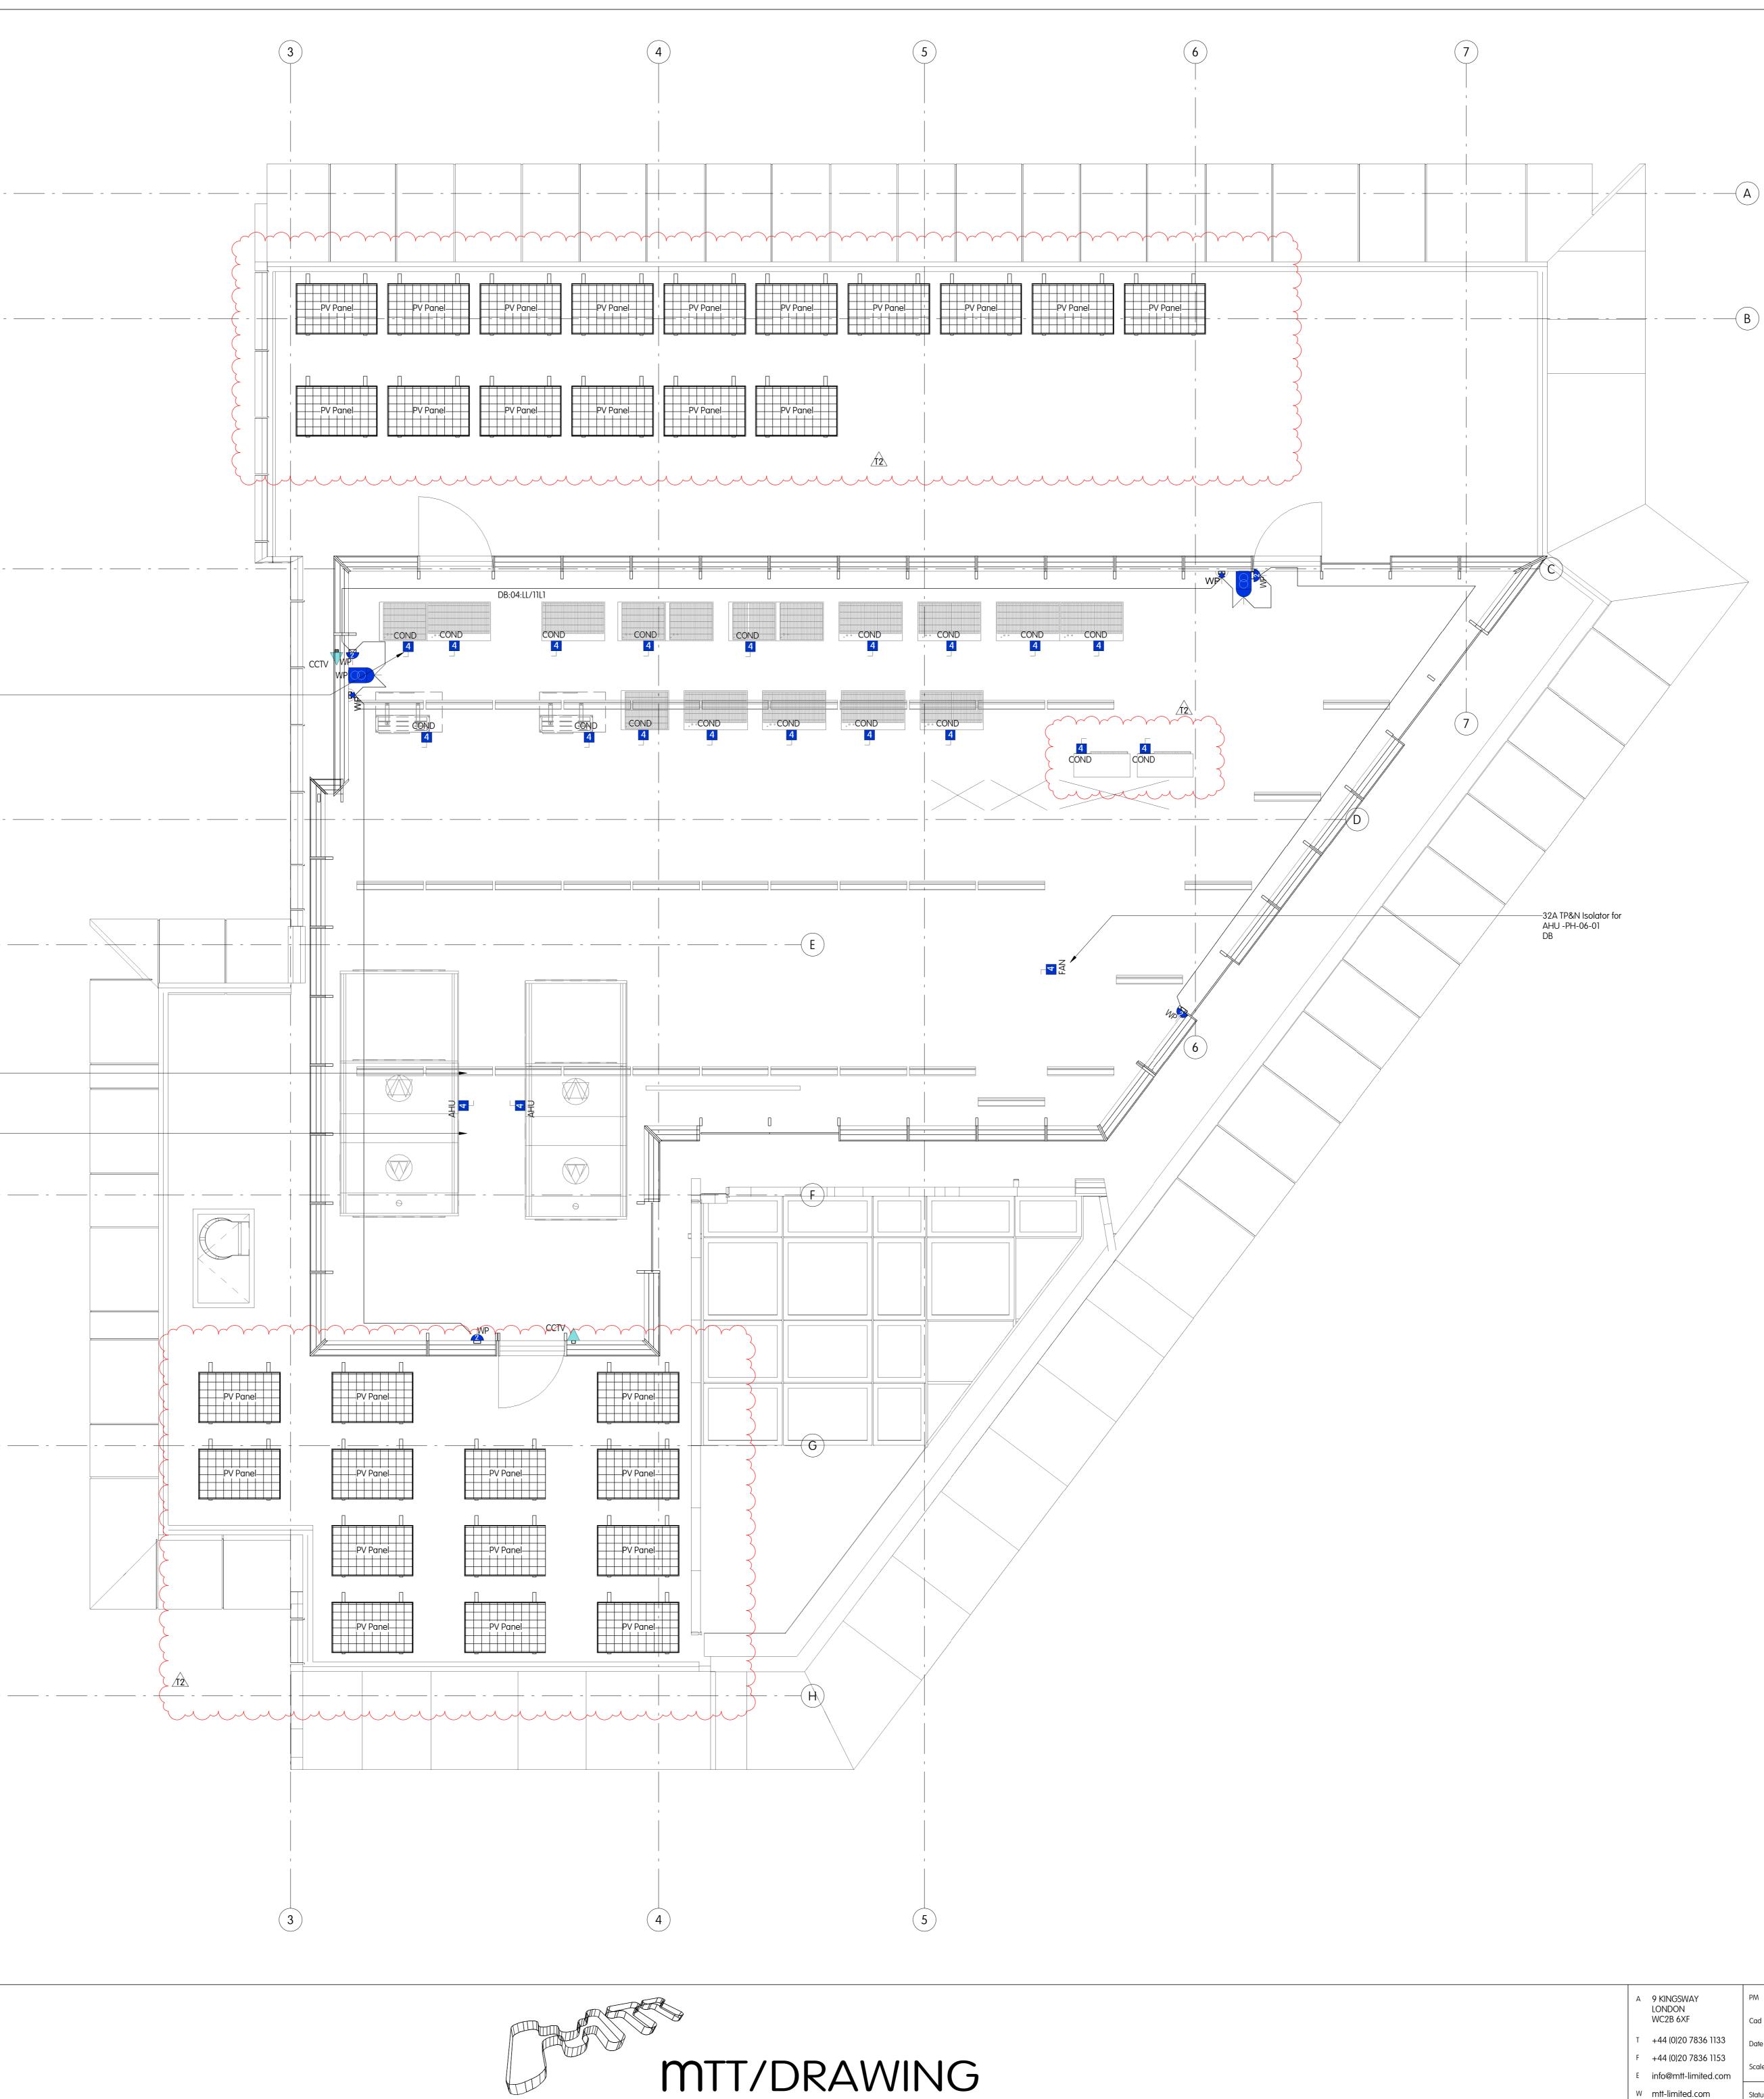

PM M Ruzickova Cad M Castaldo Date March 2021 Scale 1:50@A0 Panther House

Electrical Services Panther House - Sixth Floor Small Power Layout

Drg No. 7127-MTT-PH-06-DR-E-2300 Revision T2

