
FOR APPROVAL/COMMENT ONLY - DO NOT CONSTRUCT FROM THIS DRAWING

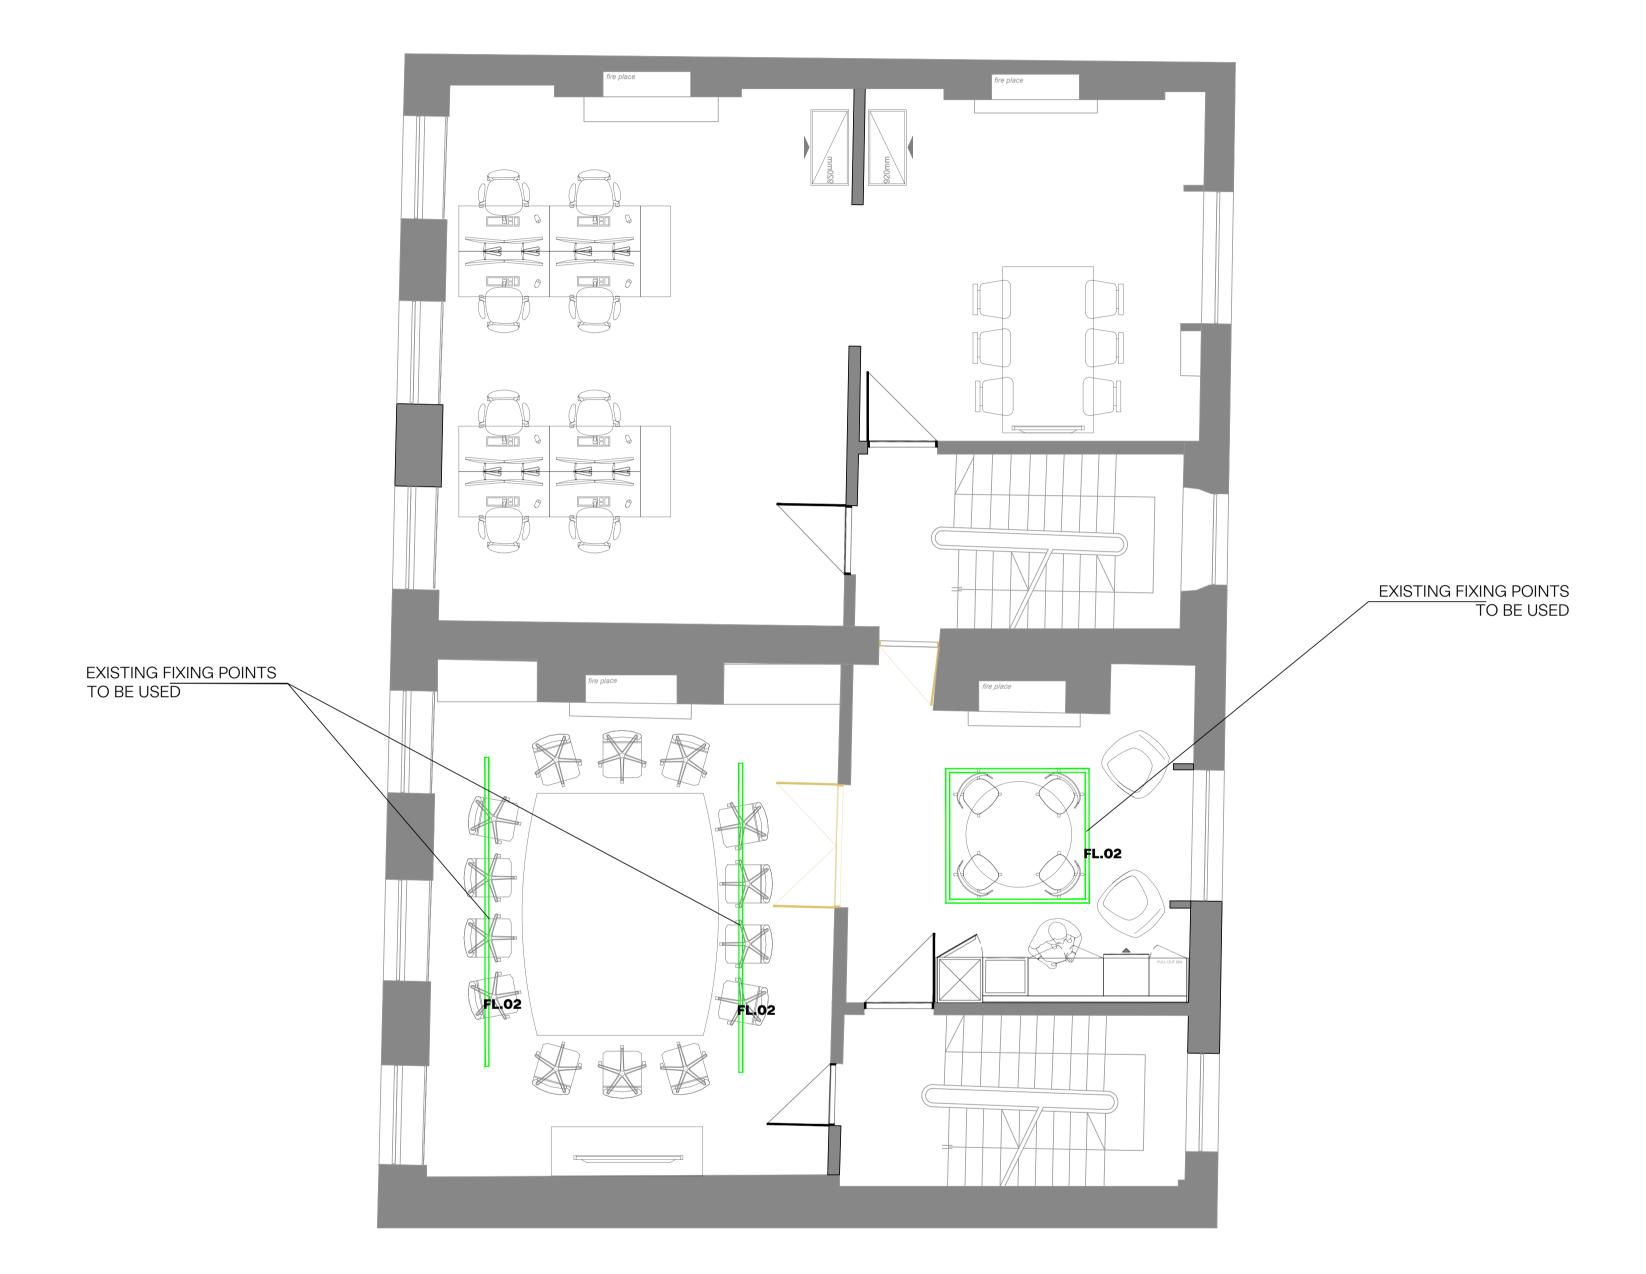

NOTES

THIRDWAY INTERIORS DO NOT ACCEPT LIABILITY FOR ANY ERRORS AND OMISSIONS ARISING FROM THE PREPARATION OF BASE BUILD DRAWINGS WHICH ARE DERIVED FROM ORIGINAL MATERIAL PROVIDED BY OTHERS.

ALL DISCREPANCIES ARE TO BE REPORTED TO THIRDWAY INTERIORS.

GRID LINES ARE FOR REFERENCE PURPOSES ONLY.

ALL DIMENSIONS TO BE VERIFIED BY CONTRACTOR ON SITE PRIOR TO ANY WORKS COMMENCING. DO NOT SCALE FROM THIS DRAWING.

THIS DOCUMENT IS THE PROPERTY OF THIRDWAY INTERIORS. COPYRIGHT IS RESERVED BY THEM, AND THE DRAWING IS ISSUED ON THE CONDITION THAT IT IS NOT COPIED, REPRODUCED OR RETAINED BY, NOR DISCLOSED TO ANY UNAUTHORISED PERSON, EITHER WHOLLY OR IN PART, WITHOUT THE CONSENT IN WRITING FROM CITHERWAXINTERIORS

FEATURE LIGHTING KEY:

FL.02 - QUAD 55
COMPONENTSARCHITECTURAL
BRONZE

NEW LIGHTS TO USE EXISTING ELECTRICAL POINTS

STATUS

Approval / Comment

Information Only **Building Control** Contract

Construction

As-Built

REVISION DETAIL P1 FIRST DRAWING ISSUE P2 ANNOTATIONS AMENDED OE 21.09.22 P3 ANNOTATIONS AMENDED OE 30.09.22

CLIENT

P4 FEATURE LIGHT KEY UPDATED

MENZIES AVIATION

PROJECT ADDRESS

21-22 BLOOMSBURY SQUARE

LONDON

DRAWING TITLE

FIRST FLOOR FEATURE LIGHTING PLAN FOR APPROVAL

41358-01-FL Р4 REVISION:

1:50 @ A3: 1:100 08.09.22

DRAWN BY: **OE**

CHECKED BY: **FS**

THIRDWAY